

INDEX OF PLANS

SHEET No.	DESCRIPTION
1	TITLE AND LOCATION MAP
2	TYPICAL CROSS SECTIONS
3	CONSTRUCTION DETAILS
4	CONSTRUCTION AREA SIGNS
5	PAVEMENT DELINEATION QUANTITIES
6	SUMMARY OF QUANTITIES
7-9	ELECTRICAL PLANS
10-17	REVISED STANDARD PLANS

THE STANDARD PLANS LIST APPLICABLE TO THIS CONTRACT IS INCLUDED IN THE NOTICE TO BIDDERS AND SPECIAL PROVISIONS BOOK.


STATE OF CALIFORNIA
DEPARTMENT OF TRANSPORTATION
PROJECT PLANS FOR CONSTRUCTION ON
STATE HIGHWAY
IN PLACER COUNTY
NEAR TAHOE CITY
FROM 0.5 MILE NORTH OF ROUTE 28
TO 0.1 MILE NORTH OF ALPINE MEADOWS ROAD

TO BE SUPPLEMENTED BY STANDARD PLANS DATED 2010

ACSTP-P089(117)

Dist	COUNTY	ROUTE	POST MILES TOTAL PROJECT	SHEET No.	TOTAL SHEETS
03	Pla	89	9.0/12.5	1	17

LOCATION MAP

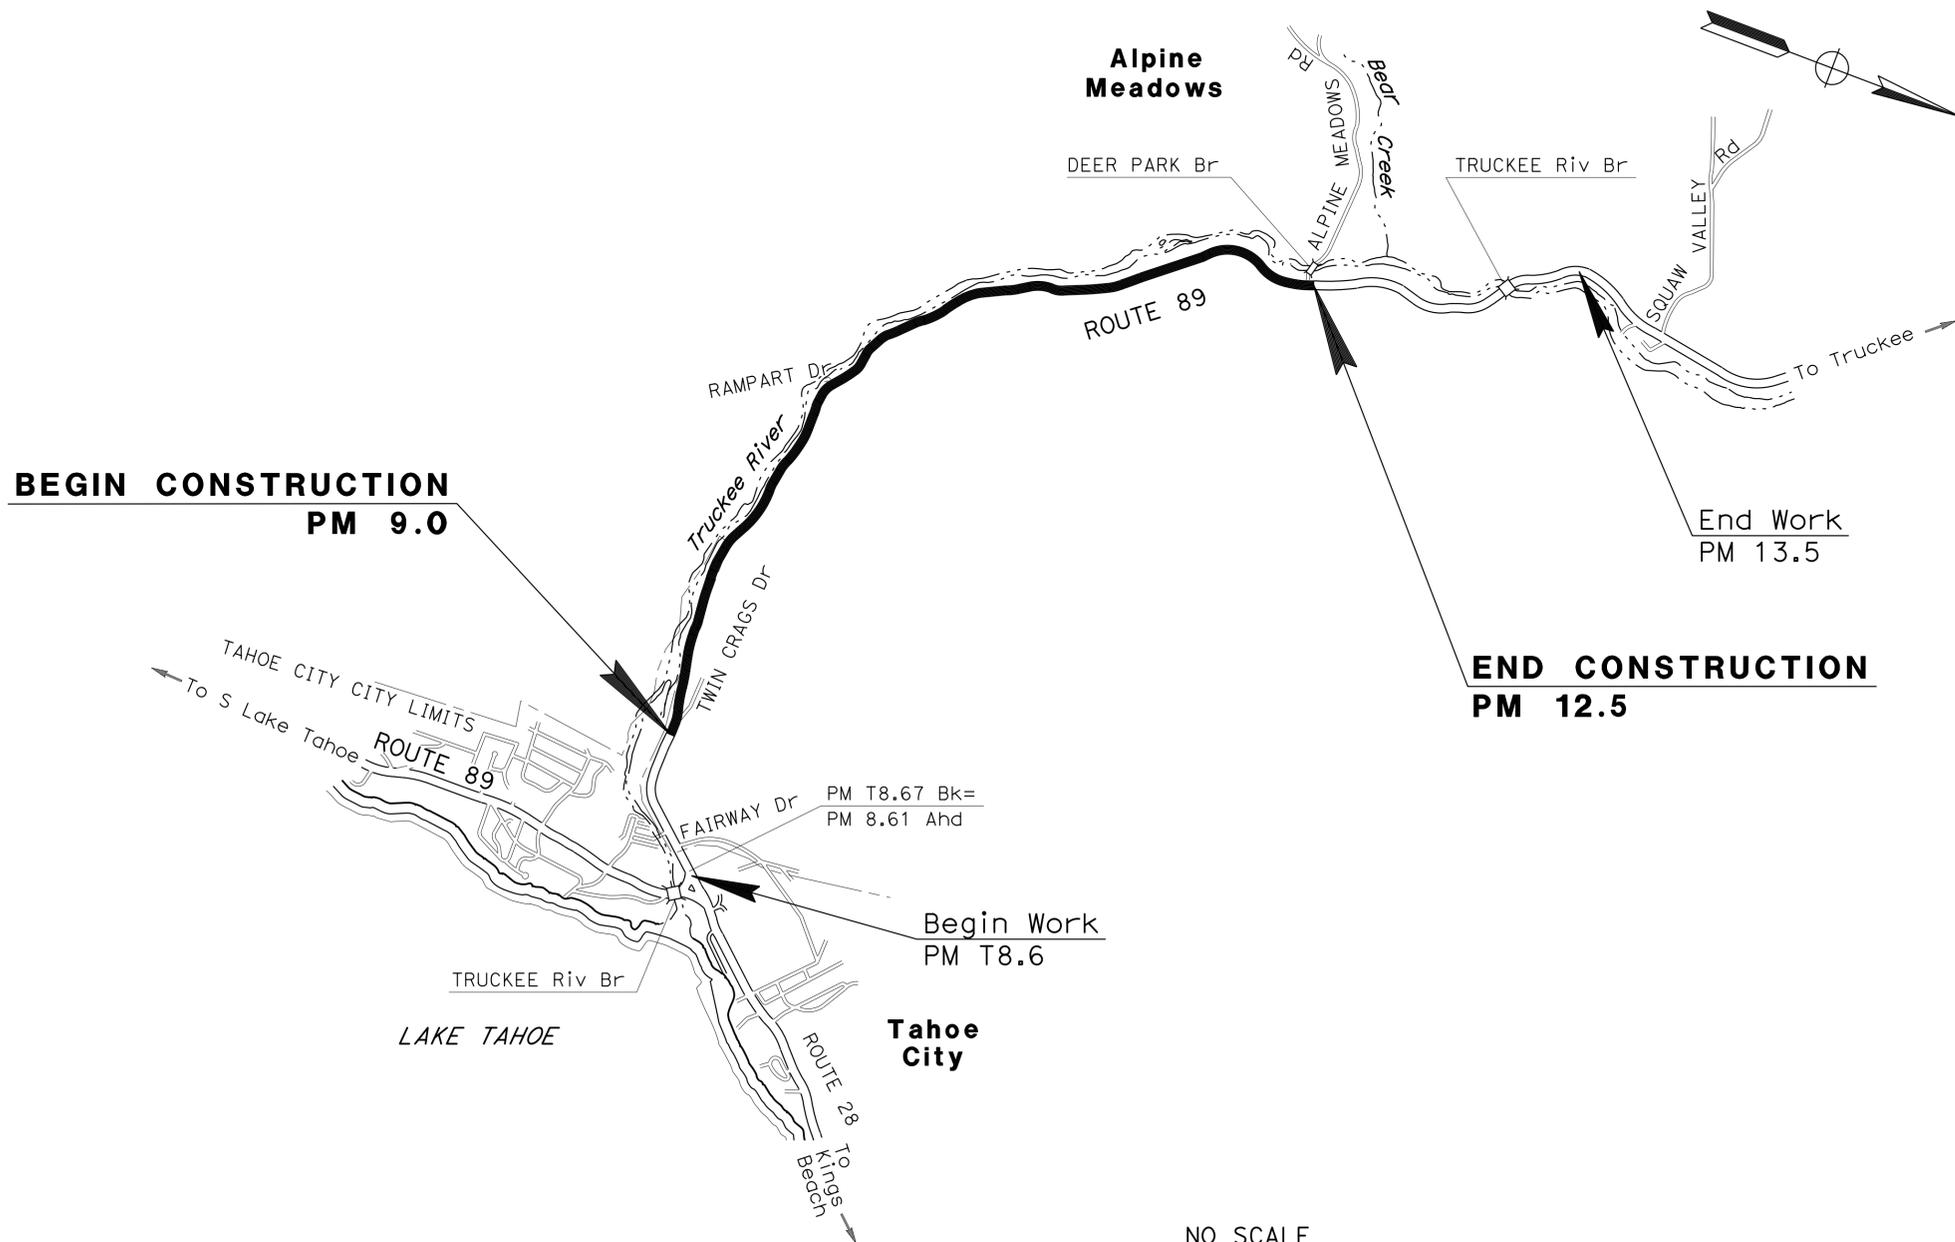


NO SCALE

PROJECT MANAGER
PATRICK D. BISHOP

DESIGN MANAGER
PATRICK D. BISHOP

THE CONTRACTOR SHALL POSSESS THE CLASS (OR CLASSES) OF LICENSE AS SPECIFIED IN THE "NOTICE TO BIDDERS."

Darju D. Patel 12-28-15
 PROJECT ENGINEER DATE
 REGISTERED CIVIL ENGINEER

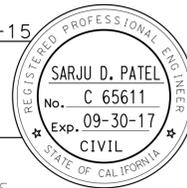

December 28, 2015
 PLANS APPROVAL DATE

THE STATE OF CALIFORNIA OR ITS OFFICERS OR AGENTS SHALL NOT BE RESPONSIBLE FOR THE ACCURACY OR COMPLETENESS OF SCANNED COPIES OF THIS PLAN SHEET.

CONTRACT No.	03-0G4504
PROJECT ID	0315000155

STATE OF CALIFORNIA - DEPARTMENT OF TRANSPORTATION
Caltrans MAINTENANCE DESIGN

FUNCTIONAL SUPERVISOR
 PATRICK D. BISHOP

CALCULATED/DESIGNED BY
 CHECKED BY

SARJU D. PATEL
 PATRICK D. BISHOP

REVISED BY
 DATE

NOTES:

- EXISTING UTILITY FACILITIES HAVE NOT BEEN PLOTTED ON THESE PLANS.
- GRIND EXISTING SURFACES TO ACCOMODATE A MINIMUM TAPER THICKNESS OF 0.10' WHEN EITHER:
 - HMA MATERIAL SUCH AS RUBBERIZED, POLYMER MODIFIED, OR OPEN GRADED IS UNSUITABLE FOR RAKING TO A MAXIMUM 0.02' THICKNESS AT THE CONFORM.
 - TEMPORARY TAPER WILL BE IN PLACE FOR MORE THAN 14 DAYS.
- PERMANENT SURFACE MAY BE EXISTING OR NEW PAVEMENT.
- ROADWAY SURFACE IS THE TOP OF EXISTING SURFACE OR THE TOP OF THE PLANED SURFACE.
- IF AUTHORIZED, YOU MAY USE ALTERNATIVE MATERIALS OR METHODS TO PRODUCE THE REQUIRED TAPER.

LEGEND:

-  HMA MATERIAL (TEMPORARY TAPER) (SEE NOTE 4)
-  IF NECESSARY, COLD PLANE ASPHALT CONCRETE PAVEMENT AND PLACE HMA MATERIAL (SEE NOTE 2)


Dist	COUNTY	ROUTE	POST MILES TOTAL PROJECT	SHEET No.	TOTAL SHEETS
03	Pla	89	9.0/12.5	3	17

SARJU D. PATEL 12-28-15
 REGISTERED CIVIL ENGINEER DATE


12-28-15
 PLANS APPROVAL DATE

SARJU D. PATEL
 No. C 65611
 Exp. 09-30-17
 CIVIL

THE STATE OF CALIFORNIA OR ITS OFFICERS OR AGENTS SHALL NOT BE RESPONSIBLE FOR THE ACCURACY OR COMPLETENESS OF SCANNED COPIES OF THIS PLAN SHEET.

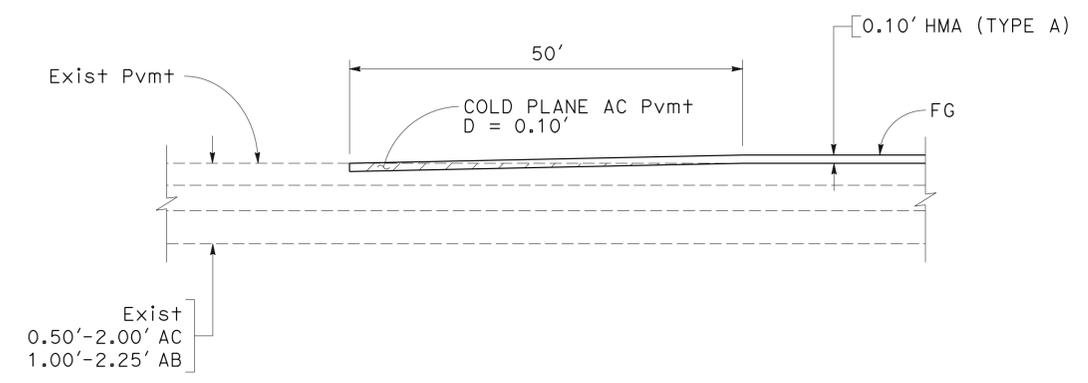


MAINLINE CONFORM

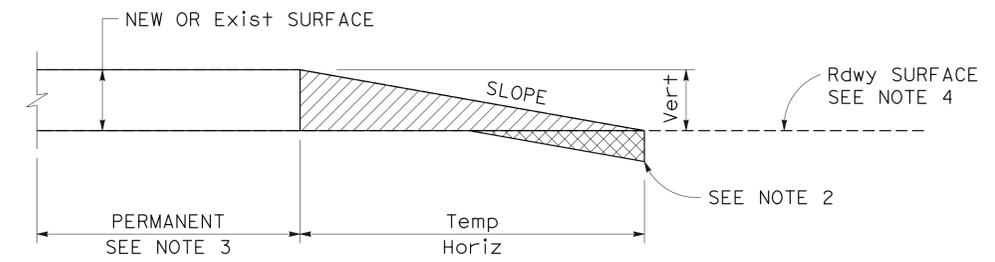

Vert	SLOPE RATIO Horiz/Vert
0-0.10'	70:1
GREATER THAN 0.10'	160:1

PAVING CONFORM FOR TEMPORARY CONSTRUCTION TAPERS

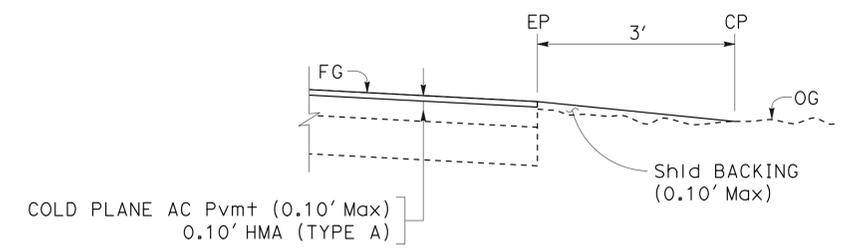

SHOULDER BACKING

CONSTRUCTION DETAILS
 NO SCALE

C-1

LAST REVISION DATE PLOTTED => 31-DEC-2015 12-11-15 TIME PLOTTED => 13:52

Dist	COUNTY	ROUTE	POST MILES TOTAL PROJECT	SHEET No.	TOTAL SHEETS
03	Plca	89	9.0/12.5	4	17

12-28-15
 REGISTERED CIVIL ENGINEER DATE
 12-28-15
 PLANS APPROVAL DATE
 THE STATE OF CALIFORNIA OR ITS OFFICERS OR AGENTS SHALL NOT BE RESPONSIBLE FOR THE ACCURACY OR COMPLETENESS OF SCANNED COPIES OF THIS PLAN SHEET.


REGISTERED PROFESSIONAL ENGINEER
 ALEX WIN WU
 No. C77266
 Exp. 6-30-17
 CIVIL
 STATE OF CALIFORNIA

STATIONARY MOUNTED CONSTRUCTION AREA SIGNS


SIGN LETTER	SIGN CODE	PANEL SIZE	SIGN MESSAGE	NUMBER OF POST AND SIZE	NUMBER OF SIGNS
A	CSP-1<CA>	60" x 30"	ROAD WORK NEXT 3 MILES	2 - 4" x 4"	2
B	C40(Mod)<CA>	72" x 42"	TRAFFIC FINES DOUBLED IN WORK ZONES	2 - 4" x 6"	2
C	W20-1	48" x 48"	ROAD WORK AHEAD	1 - 6" x 6"	1
D	G20-2	36" x 18"	END ROAD WORK	1 - 4" x 4"	3

NOTES:


- EXACT SIGN LOCATION TO BE DETERMINED BY THE ENGINEER.
- ALL SIGN CODES SHOWN ARE FEDERAL SIGN CODES UNLESS OTHERWISE DESIGNATED AS A CALIFORNIA SIGN CODE.
- <CA> = CALIFORNIA SIGN CODE.

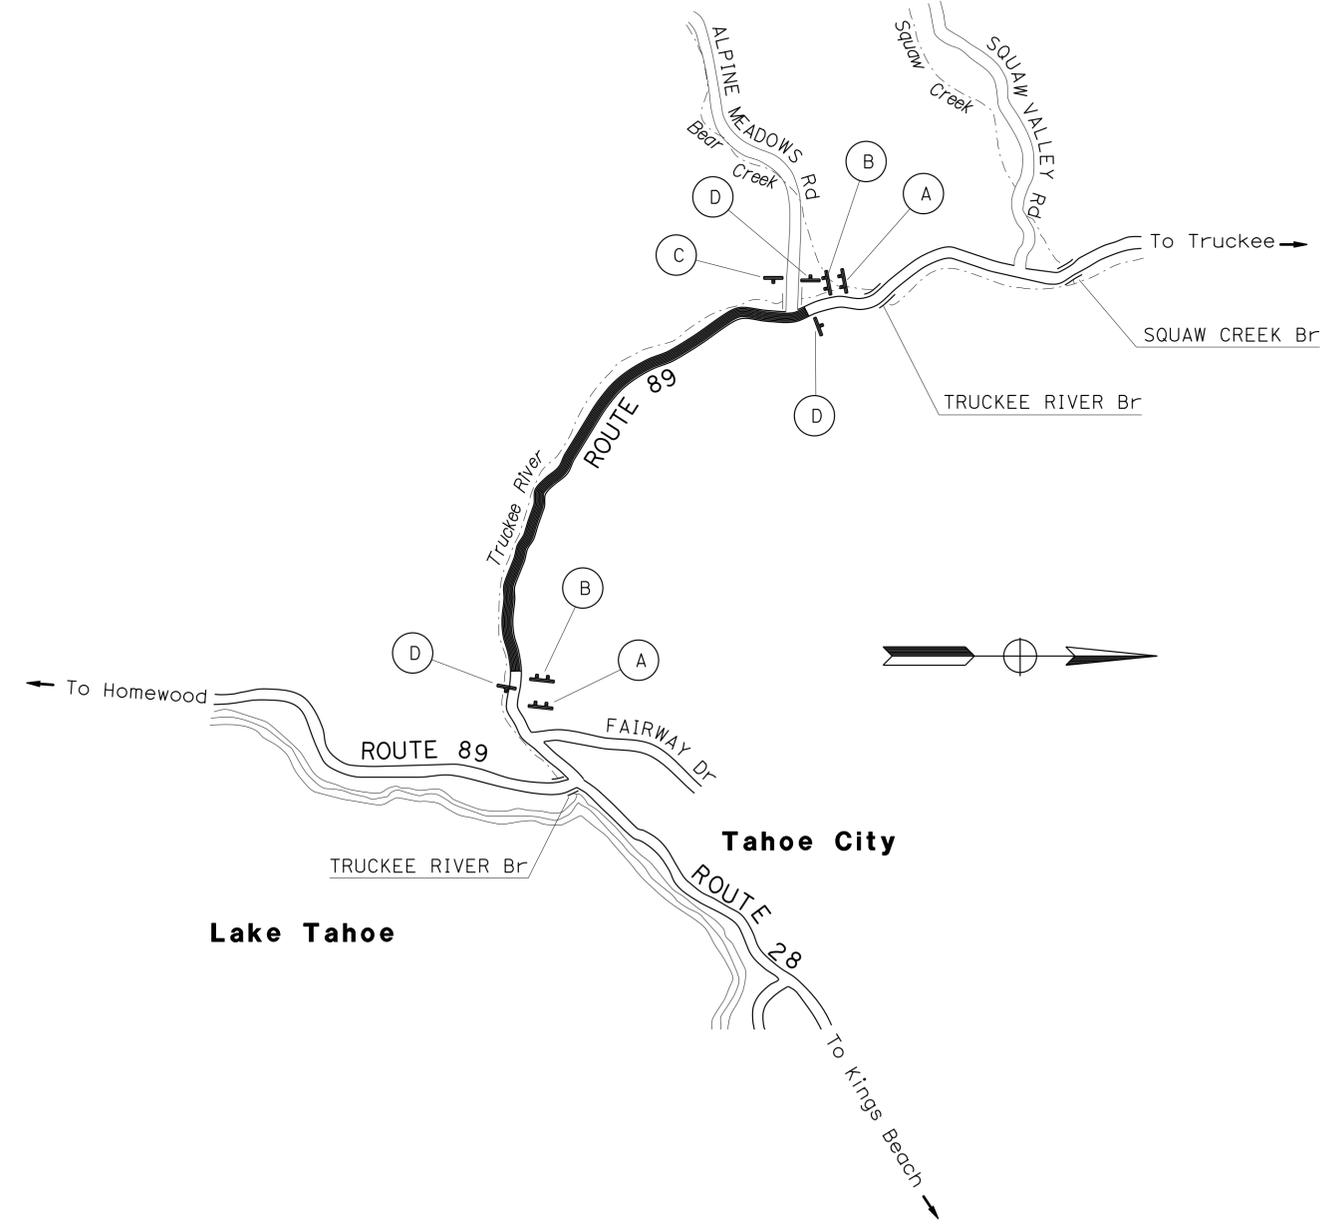

SIGN DETAILS

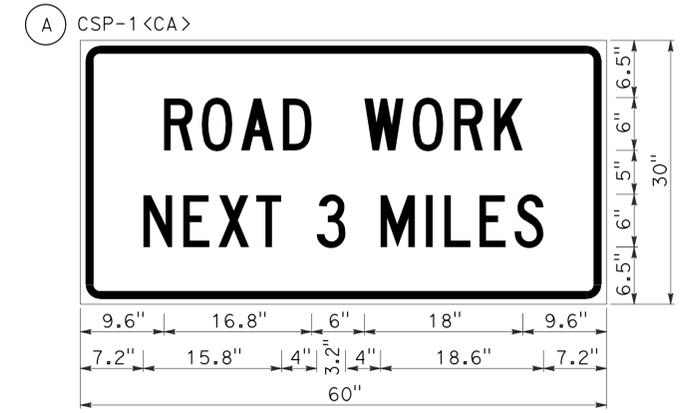

7/8" BORDER WITH 2 1/4" RADIUS AND 5/8" INDENT
 RETROREFLECTIVE ORANGE BACKGROUND
 WITH BLACK LEGEND AND BORDER
 "ROAD WORK" C
 "NEXT 4 MILES" C

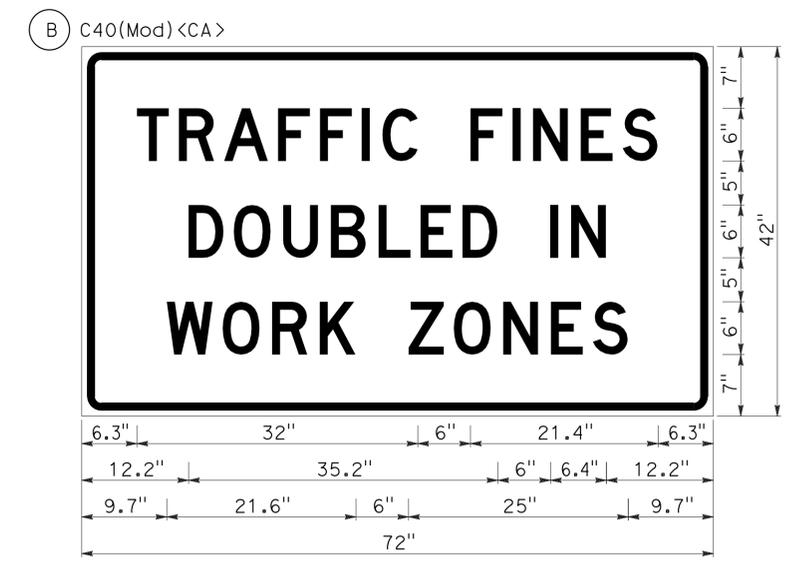

7/8" BORDER WITH 2 1/4" RADIUS AND 5/8" INDENT
 RETROREFLECTIVE WHITE BACKGROUND
 WITH BLACK LEGEND AND BORDER
 "TRAFFIC FINES" D
 "DOUBLED IN" D
 "WORK ZONES" D

CONSTRUCTION AREA SIGNS

NO SCALE

CS-1

APPROVED FOR CONSTRUCTION AREA SIGN WORK ONLY

STATE OF CALIFORNIA - DEPARTMENT OF TRANSPORTATION
 Caltrans

REVISOR BY DATE

JACK KEMMERLY ALEX WU

CALCULATED/DESIGNED BY CHECKED BY

FUNCTIONAL SUPERVISOR JOYCE K LOFTUS

TRAFFIC

USERNAME => s119538
 DGN FILE => 03150001551a001.dgn

RELATIVE BORDER SCALE IS IN INCHES


UNIT 0390

PROJECT NUMBER & PHASE

03150001551

LAST REVISION DATE PLOTTED => 31-DEC-2015
 12-21-15 TIME PLOTTED => 1:32

Dist	COUNTY	ROUTE	POST MILES TOTAL PROJECT	SHEET No.	TOTAL SHEETS
03	Pla	89	9.0/12.5	5	17

  12-28-15
 REGISTERED CIVIL ENGINEER DATE

12-28-15
 PLANS APPROVAL DATE

THE STATE OF CALIFORNIA OR ITS OFFICERS
 OR AGENTS SHALL NOT BE RESPONSIBLE FOR
 THE ACCURACY OR COMPLETENESS OF SCANNED
 COPIES OF THIS PLAN SHEET.

REGISTERED PROFESSIONAL ENGINEER
 ALEX WIN WU
 No. C77266
 Exp. 6-30-17
 CIVIL
 STATE OF CALIFORNIA

**4" METHYL METHACRYLATE
TRAFFIC STRIPE
(RECESSED, BROKEN 12-3)**

DETAIL NUMBER	LINEAR FEET
27C	265
TOTAL	265

**8" METHYL METHACRYLATE
TRAFFIC STRIPE (RECESSED)**


DETAIL NUMBER	LINEAR FEET
38A	766
TOTAL	766

**4" METHYL METHACRYLATE
TRAFFIC STRIPE
(RECESSED, BROKEN 36-12)**

DETAIL NUMBER	LINEAR FEET
31	3,486
TOTAL	3,486

METHYL METHACRYLATE PAVEMENT MARKING

DESCRIPTION	NUMBER	SQUARE FEET
"SIGNAL"	1 @ 32 SQFT	32
"AHEAD"	1 @ 31 SQFT	31
TYPE III ARROW	4 @ 42 SQFT	168
LIMIT LINE	2	60
TOTAL		291

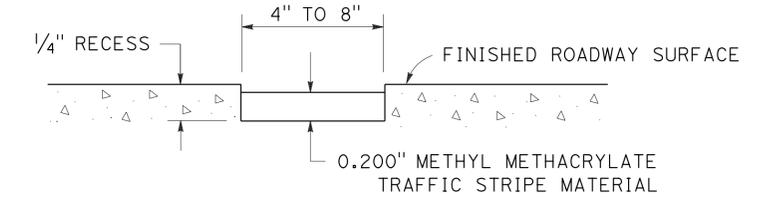

**METHYL METHACRYLATE TRAFFIC STRIPE
RECESSING DETAIL**

NO SCALE

**4" METHYL METHACRYLATE
TRAFFIC STRIPE (RECESSED)**

DETAIL NUMBER	LINEAR FEET
21	31,154
27B	35,606
28	2,008
31	3,486
TOTAL	72,254

**REMOVE THERMOPLASTIC
TRAFFIC STRIPE**

DETAIL NUMBER	LINEAR FEET
39	737
38A	1,532
TOTAL	2,269

NOTES:

1. REMOVE THE EXISTING 6" AND 8" STRIPING FROM POSTMILE 12.26 TO 12.45.
2. THE EXISTING TRAFFIC STRIPE TO BE REMOVED IS RECESSED.

**6" METHYL METHACRYLATE
TRAFFIC STRIPE (RECESSED)**

DETAIL NUMBER	LINEAR FEET
39	491
TOTAL	491

**PAVEMENT DELINEATION
QUANTITIES**

PDQ-1

STATE OF CALIFORNIA - DEPARTMENT OF TRANSPORTATION
Caltrans
 FUNCTIONAL SUPERVISOR: JOYCE K LOFTUS
 JACK KEMMERLY
 ALEX WU
 REVISOR: JACK KEMMERLY
 DATE: 12-28-15
 REVISION: 12-21-15
 TIME PLOTTED: 13:52

STATE OF CALIFORNIA - DEPARTMENT OF TRANSPORTATION
Caltrans MAINTENANCE DESIGN

FUNCTIONAL SUPERVISOR
 PATRICK D. BISHOP

CALCULATED/DESIGNED BY
 CHECKED BY

SARJU D. PATEL
 PATRICK D. BISHOP

REVISED BY
 DATE REVISED

Dist	COUNTY	ROUTE	POST MILES TOTAL PROJECT	SHEET No.	TOTAL SHEETS
03	Plac	89	9.0/12.5	6	17

Sarju D. Patel 12-28-15
 REGISTERED CIVIL ENGINEER DATE

12-28-15
 PLANS APPROVAL DATE

SARJU D. PATEL
 No. C 65611
 Exp. 09-30-17
 CIVIL

THE STATE OF CALIFORNIA OR ITS OFFICERS OR AGENTS SHALL NOT BE RESPONSIBLE FOR THE ACCURACY OR COMPLETENESS OF SCANNED COPIES OF THIS PLAN SHEET.

ROADWAY QUANTITIES

LOCATION (POST MILE)	COLD PLANE ASPHALT CONCRETE PAVEMENT	HOT MIX ASPHALT (TYPE A)	TACK COAT
	SQYD	TON	
9.04 TO 12.26	68,210.4	4,615.6	31.0
12.26 TO 12.45	1,831.2	482.1	3.2
TOTAL	70,041.6	5,097.7	34.2

SHOULDER BACKING

LOCATION (POST MILE)	QUANTITY
	TON
9.06 TO 9.09 Lt	6.9
9.20 TO 9.26 Rt	13.8
9.28 TO 9.30 Rt	4.6
9.43 TO 9.52 Lt	20.7
9.67 TO 9.68 Lt	2.3
9.76 TO 9.80 Lt	9.2
9.81 TO 9.97 Lt	36.7
10.00 TO 10.12 Rt	27.6
10.16 TO 10.26 Lt	23.0
10.31 TO 10.42 Rt	25.3
10.49 TO 10.66 Lt	39.0
10.66 TO 10.81 Rt	34.5
10.82 TO 10.96 Lt	32.2
11.01 TO 11.08 Rt	16.1
11.19 TO 11.30 Lt	25.3
11.49 TO 11.53 Rt	9.2
11.65 TO 11.72 Rt	16.1
11.73 TO 11.76 Lt	6.9
11.77 TO 11.80 Lt	6.9
11.99 TO 12.07 Lt	18.4
12.16 TO 12.17 Lt	2.3
12.26 TO 12.32 Rt	13.8
12.34 TO 12.43 Rt	20.7
12.40 TO 12.45 Rt	11.5
TOTAL	423.0

TEMPORARY DRAINAGE INLET PROTECTION

LOCATION (POST MILE)	QUANTITY
	EA
9.04 TO 12.45	193
TOTAL	193

SUMMARY OF QUANTITIES


Q-1



Dist	COUNTY	ROUTE	POST MILES TOTAL PROJECT	SHEET No.	TOTAL SHEETS
03	Pla	89	9.0/12.5	7	17
<i>Norman Ye</i> 12-28-15 REGISTERED ELECTRICAL ENGINEER DATE			12-28-15 PLANS APPROVAL DATE		
REGISTERED PROFESSIONAL ENGINEER No. 16913 Exp. 06-30-17 ELECTRICAL STATE OF CALIFORNIA					
<small>THE STATE OF CALIFORNIA OR ITS OFFICERS OR AGENTS SHALL NOT BE RESPONSIBLE FOR THE ACCURACY OR COMPLETENESS OF SCANNED COPIES OF THIS PLAN SHEET.</small>					

NOTE:

FOR ACCURATE RIGHT OF WAY DATA, CONTACT RIGHT OF WAY ENGINEERING AT THE DISTRICT OFFICE.

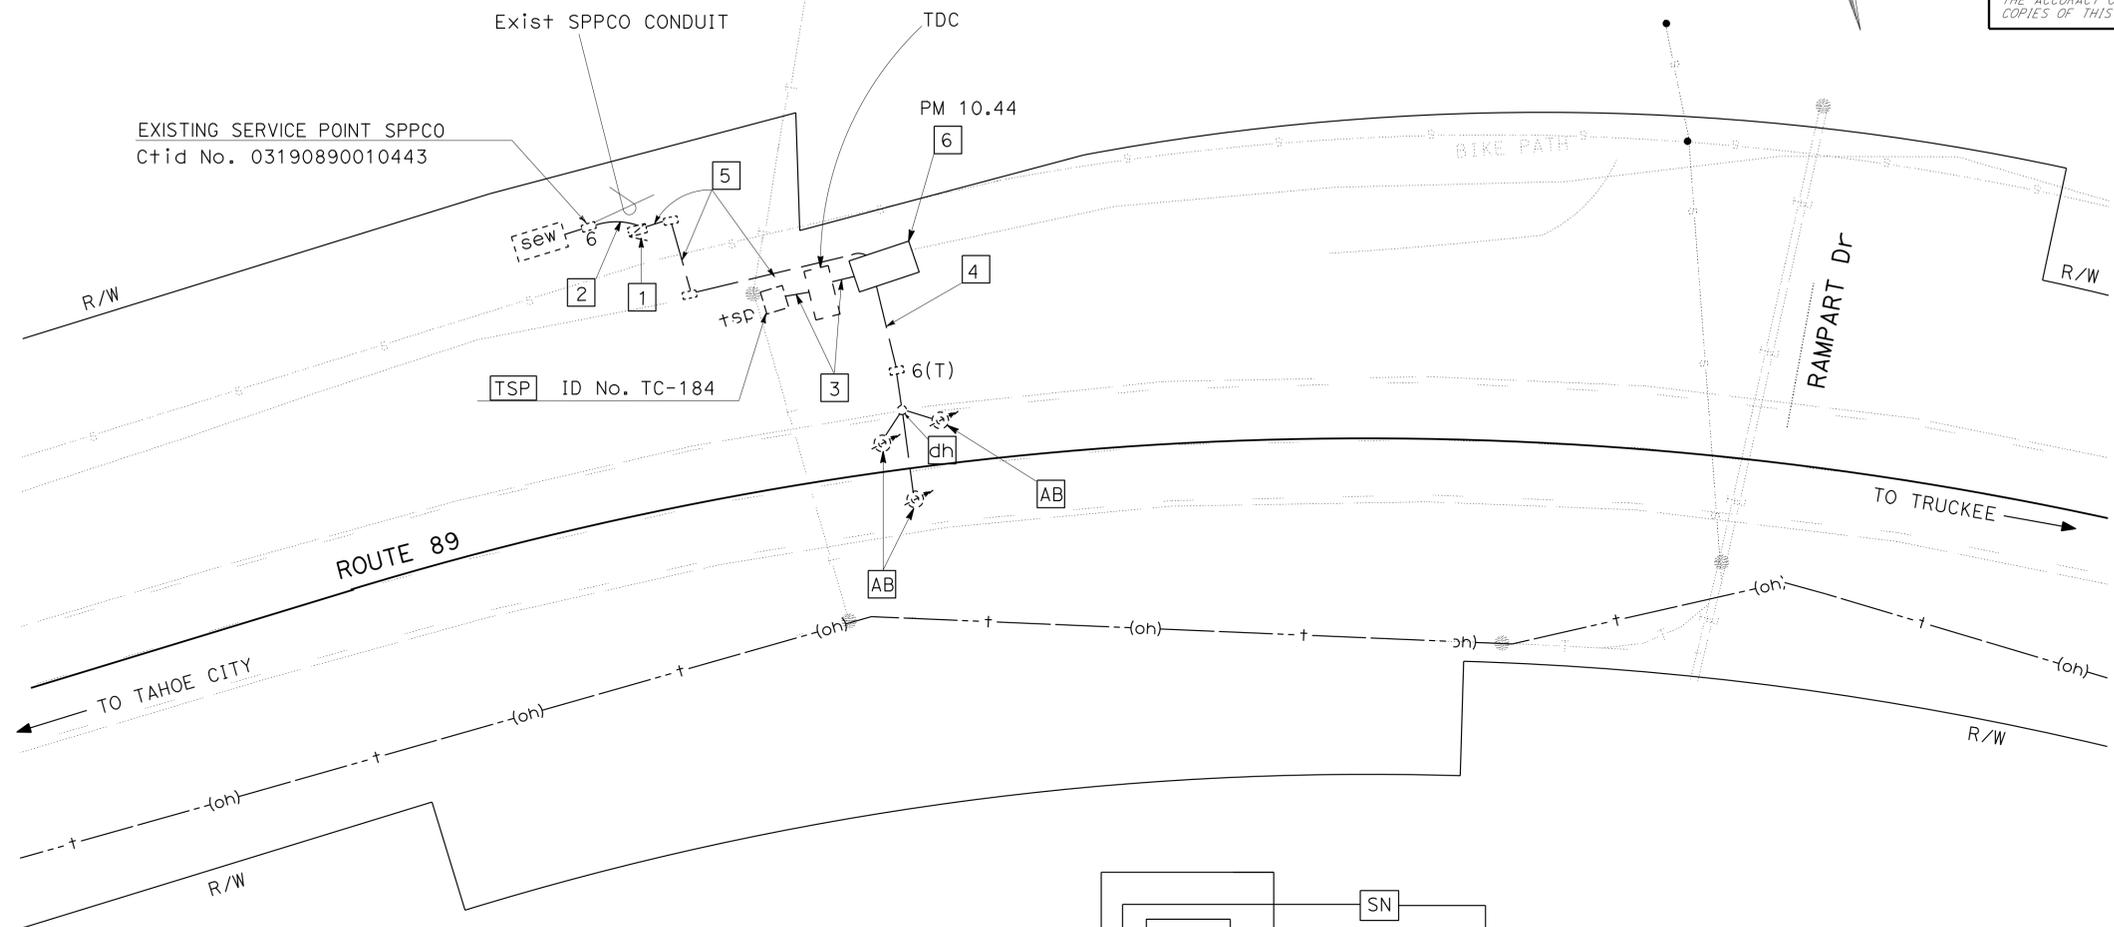


ABBREVIATIONS (FOR THIS SHEET ONLY):

- Exist SENSOR
- Exist SEWER CABINET (OWNED BY CITY)
- REMOTE PROCESSING UNIT
- SN - SOLID NEUTRAL
- SPPCO - SIERRA PACIFIC POWER COMPANY

LEGEND (FOR THIS SHEET ONLY):

- 1 120/240 V TYPE III-AF SERVICE EQUIPMENT ENCLOSURE. SEE SERVICE WIRING DIAGRAM.
- 2 2" C, 3#2.
- 3 1 1/2" C, 1-TELEPHONE CABLE.
- 4 1 1/2" C, REMOVE Exist CABLES.
- 5 2" C, 2#10.
- 6 SEE SHEET E-2.

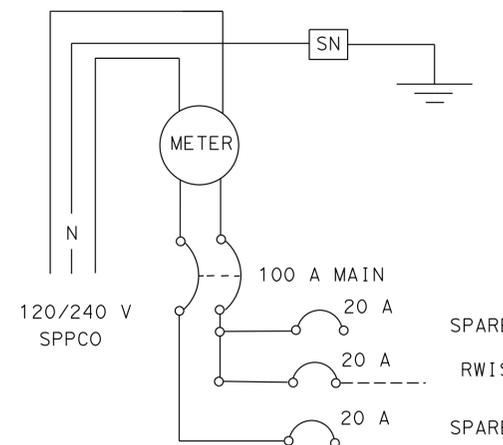

EXISTING SERVICE WIRING DIAGRAM

Ctid No. 03190890010443

STATE OF CALIFORNIA - DEPARTMENT OF TRANSPORTATION
Caltrans ELECTRICAL DESIGN


FUNCTIONAL SUPERVISOR	MARY ANN HUDSPETH
CALCULATED/DESIGNED BY	CHECKED BY
NORMAN YE	MARY ANN HUDSPETH
REVISED BY	DATE REVISED

APPROVED FOR ELECTRICAL WORK ONLY

MODIFY ROADSIDE WEATHER INFORMATION SYSTEM

SCALE: 1" = 50'

 E-1




Dist	COUNTY	ROUTE	POST MILES TOTAL PROJECT	SHEET No.	TOTAL SHEETS
03	Pla	89	9.0/12.5	8	17

Norman Ye 12-28-15
 REGISTERED ELECTRICAL ENGINEER DATE
 12-28-15
 PLANS APPROVAL DATE

REGISTERED PROFESSIONAL ENGINEER
NORMAN YE
 No. 16913
 Exp. 06-30-17
 ELECTRICAL
 STATE OF CALIFORNIA

THE STATE OF CALIFORNIA OR ITS OFFICERS OR AGENTS SHALL NOT BE RESPONSIBLE FOR THE ACCURACY OR COMPLETENESS OF SCANNED COPIES OF THIS PLAN SHEET.

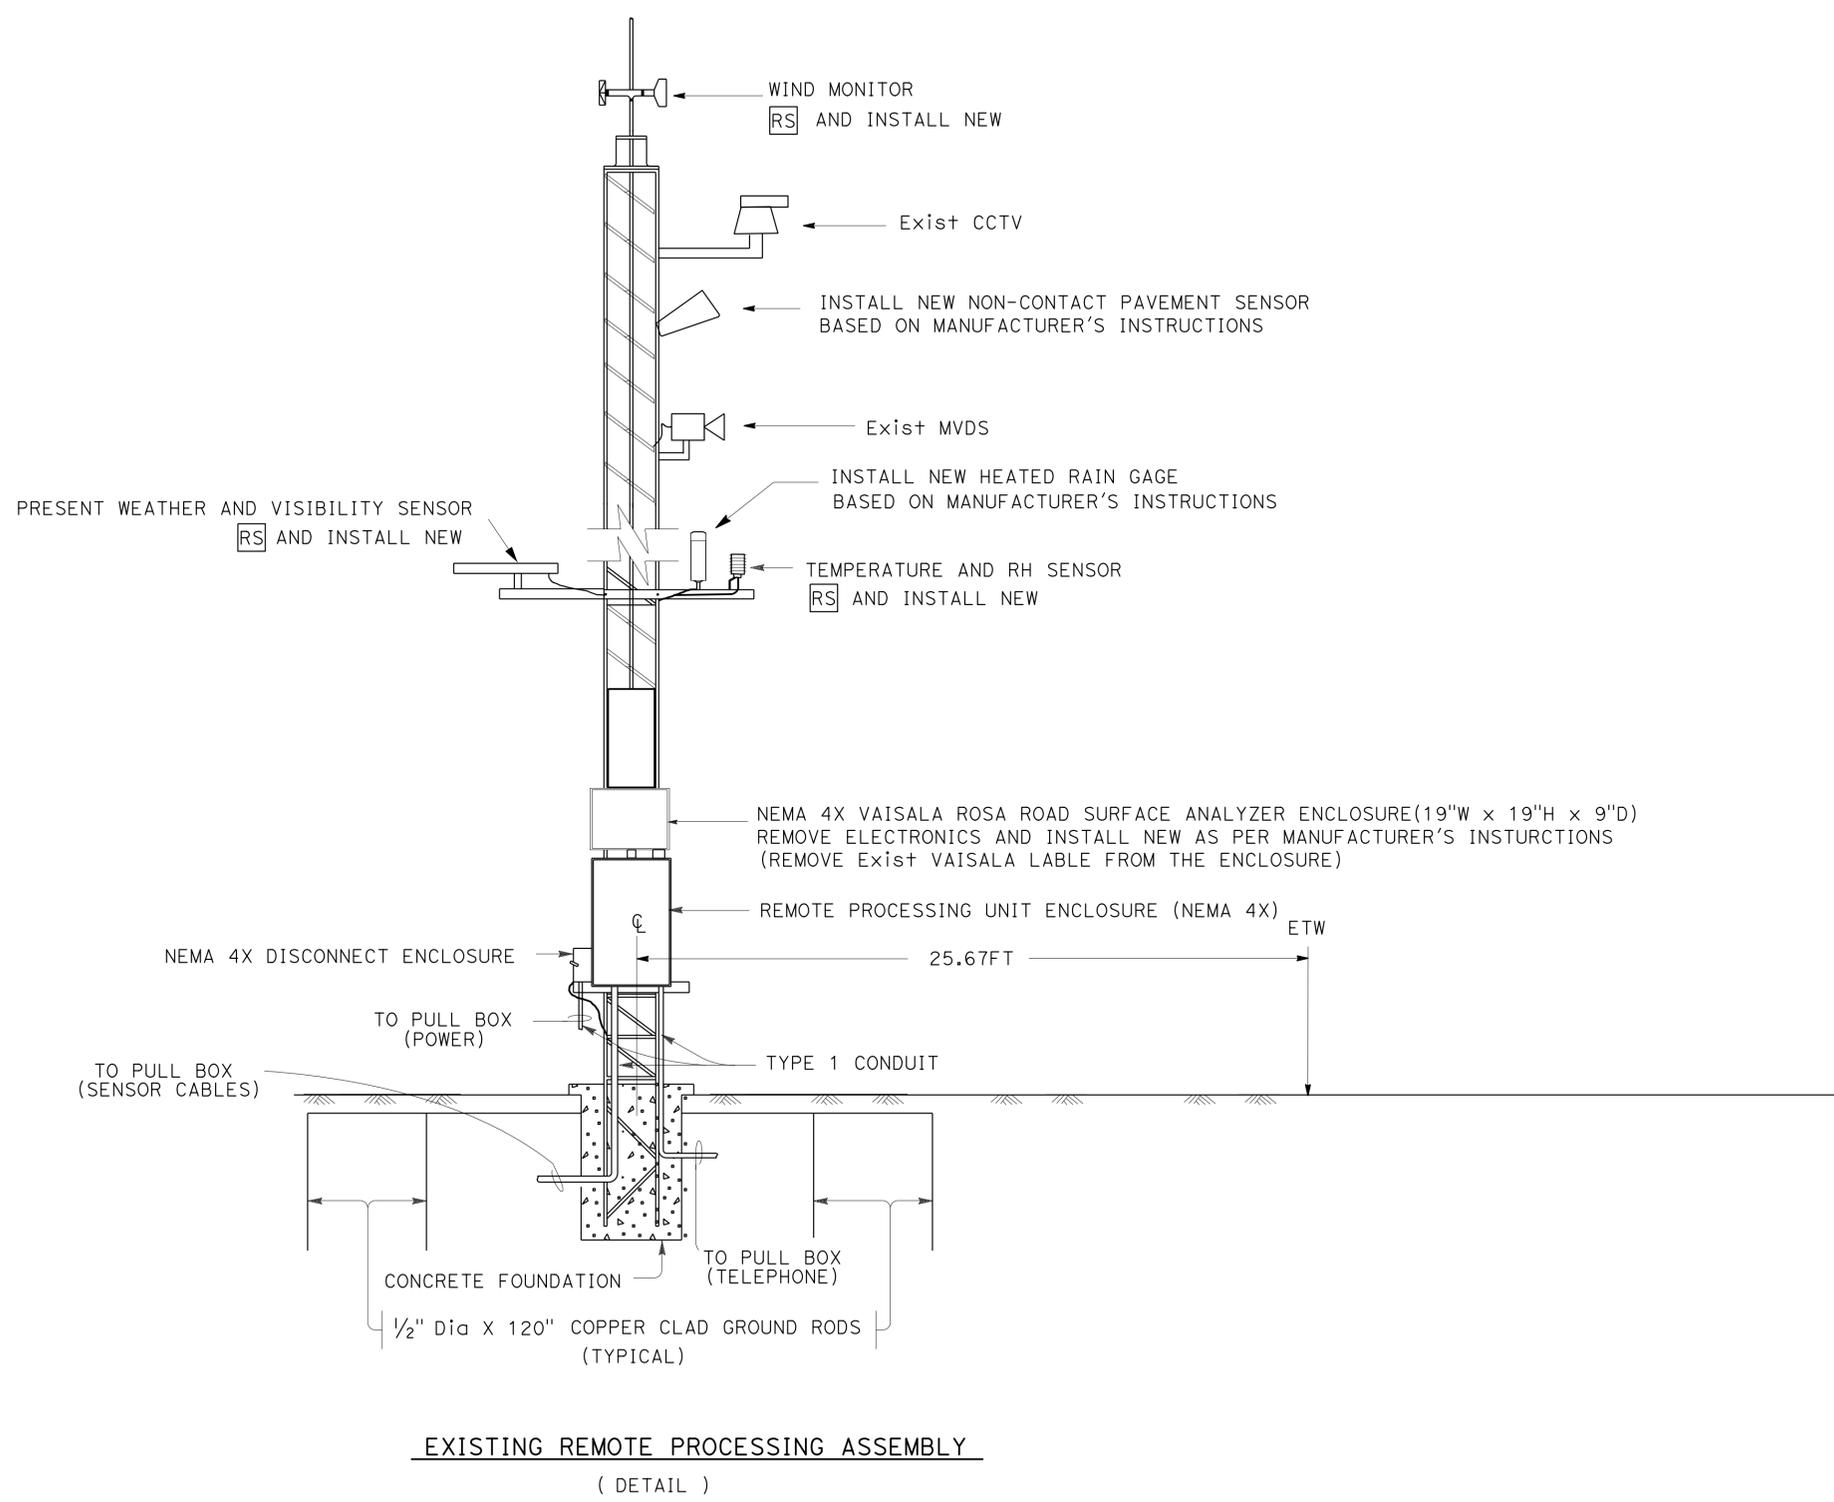

EXISTING REMOTE PROCESSING ASSEMBLY
(DETAIL)

MODIFY ROADSIDE WEATHER INFORMATION SYSTEM

NO SCALE

E-2

STATE OF CALIFORNIA - DEPARTMENT OF TRANSPORTATION	FUNCTIONAL SUPERVISOR	CALCULATED/DESIGNED BY	REVISOR	DATE
Caltrans ELECTRICAL DESIGN	MARY ANN HUDSPETH	MARY ANN HUDSPETH	NORMAN YE	
		CHECKED BY	DATE	
		MARY ANN HUDSPETH		

STATE OF CALIFORNIA - DEPARTMENT OF TRANSPORTATION
Caltrans
 ELECTRICAL DESIGN

FUNCTIONAL SUPERVISOR
 MARY ANN HUDSPETH

CALCULATED/DESIGNED BY
 CHECKED BY

NORMAN YE
 MARY ANN HUDSPETH

REVISED BY
 DATE REVISED

NOTE:


ITEM SHOWN IN THIS TABLE IS NOT A SEPARATE PAY ITEM, FOR INFORMATION ONLY.

MODIFY ROADSIDE WEATHER INFORMATION SYSTEM

SHEET No.	ROADSIDE WEATHER INFORMATION SYSTEM
	EA
E-1	1

Dist	COUNTY	ROUTE	POST MILES TOTAL PROJECT	SHEET No.	TOTAL SHEETS
03	Pla	89	9.0/12.5	9	17

Norman Ye 12-28-15
 REGISTERED ELECTRICAL ENGINEER DATE
 12-28-15
 PLANS APPROVAL DATE

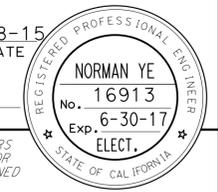

THE STATE OF CALIFORNIA OR ITS OFFICERS OR AGENTS SHALL NOT BE RESPONSIBLE FOR THE ACCURACY OR COMPLETENESS OF SCANNED COPIES OF THIS PLAN SHEET.

**ELECTRICAL QUANTITIES
 E-3**

LAST REVISION | DATE PLOTTED => 31-DEC-2015 | TIME PLOTTED => 13:52
 12-3-15

	M	
Maint	MAINTENANCE	
Max	MAXIMUM	
MB	METAL BEAM	
MBB	METAL BEAM BARRIER	
MBGR	METAL BEAM GUARD RAILING	
Med	MEDIAN	
MGS	MIDWEST GUARDRAIL SYSTEM	
MH	MANHOLE	
Min	MINIMUM	
Misc	MISCELLANEOUS	
Misc I & S	MISCELLANEOUS IRON AND STEEL	
Mkr	MARKER	
Mod	MODIFIED, MODIFY	
Mon	MONUMENT	
MP	METAL PLATE	
MPGR	METAL PLATE GUARD RAILING	
MR	MOVEMENT RATING	
MSE	MECHANICALLY STABILIZED EMBANKMENT	
Mt	MOUNTAIN, MOUNT	
MtI	MATERIAL	
MVP	MAINTENANCE VEHICLE PULLOUT	
	N	
N	NORTH	
NB	NORTHBOUND	
No.	NUMBER (MUST HAVE PERIOD)	
Nos.	NUMBERS (MUST HAVE PERIOD)	
NPS	NOMINAL PIPE SIZE	
NS	NEAR SIDE	
NSP	NEW STANDARD PLAN	
NTS	NOT TO SCALE	
	O	
Obir	OBLITERATE	
OC	OVERCROSSING	
OD	OUTSIDE DIAMETER	
OF	OUTSIDE FACE	
OG	ORIGINAL GROUND	
OGAC	OPEN GRADED ASPHALT CONCRETE	
OGFC	OPEN GRADED FRICTION COURSE	
OH	OVERHEAD	
OHWM	ORDINARY HIGH WATER MARK	
O-O	OUT TO OUT	
Opp	OPPOSITE	
OSD	OVERSIDE DRAIN	
	P	
p	PAGE	
PAP	PERFORATED ALUMINUM PIPE	
PB	PULL BOX	
PC	POINT OF CURVATURE, PRECAST	
PCC	POINT OF COMPOUND CURVE, PORTLAND CEMENT CONCRETE	
PCMS	PORTABLE CHANGEABLE MESSAGE SIGN	
PCP	PERFORATED CONCRETE PIPE, PRESTRESSED CONCRETE PIPE	
PCVC	POINT OF COMPOUND VERTICAL CURVE	
PEC	PERMIT TO ENTER AND CONSTRUCT	
Ped	PEDESTRIAN	
Ped OC	PEDESTRIAN OVERCROSSING	
Ped UC	PEDESTRIAN UNDERCROSSING	
Perm MtI	PERMEABLE MATERIAL	

	P continued	
PG	PROFILE GRADE	
PI	POINT OF INTERSECTION	
PJP	PARTIAL JOINT PENETRATION	
Pkwy	PARKWAY	
PL, PL	PLATE	
P/L	PROPERTY LINE	
PM	POST MILE, TIME FROM NOON TO MIDNIGHT	
PN	PAVING NOTCH	
POC	POINT OF HORIZONTAL CURVE	
POT	POINT OF TANGENT	
POVC	POINT OF VERTICAL CURVE	
PP	PIPE PILE, PLASTIC PIPE, POWER POLE	
PPL	PREFORMED PERMEABLE LINER	
PPP	PERFORATED PLASTIC PIPE	
PRC	POINT OF REVERSE CURVE	
PRF	PAVEMENT REINFORCING FABRIC	
PRVC	POINT OF REVERSE VERTICAL CURVE	
PS&E	PLANS, SPECIFICATIONS AND ESTIMATES	
PS, P/S	PRESTRESSED	
PSP	PERFORATED STEEL PIPE	
PT	POINT OF TANGENCY	
PVC	POLYVINYL CHLORIDE	
Pvmt	PAVEMENT	
	Q	
Qty	QUANTITY	
	R	
R	RADIUS	
R & D	REMOVE AND DISPOSE	
R & S	REMOVE AND SALVAGE	
R/C	RATE OF CHANGE	
RCA	REINFORCED CONCRETE ARCH	
RCB	REINFORCED CONCRETE BOX	
RCP	REINFORCED CONCRETE PIPE	
RCPA	REINFORCED CONCRETE PIPE ARCH	
Rd	ROAD	
Reinf	REINFORCED, REINFORCEMENT, REINFORCING	
Rel	RELOCATE	
Repl	REPLACEMENT	
Ret	RETAINING	
Rev	REVISED, REVISION	
Rdwy	ROADWAY	
RHMA	RUBBERIZED HOT MIX ASPHALT	
Riv	RIVER	
RM	ROAD-MIXED	
RP	RADIUS POINT, REFERENCE POINT	
RR	RAILROAD	
RSP	ROCK SLOPE PROTECTION, REVISED STANDARD PLAN	
Rt	RIGHT	
Rte	ROUTE	
RW	REDWOOD, RETAINING WALL	
R/W	RIGHT OF WAY	
Rwy	RAILWAY	

	S	
S	SOUTH, SUPPLEMENT	
SAE	STRUCTURE APPROACH EMBANKMENT	
Salv	SALVAGE	
SAPP	STRUCTURAL ALUMINUM PLATE PIPE	
SB	SOUTHBOUND	
SC	SAND CUSHION	
SCSP	SLOTTED CORRUGATED STEEL PIPE	
SD	STORM DRAIN	
Sec	SECOND, SECTION	
Sep	SEPARATION	
SG	SUBGRADE	
Shld	SHOULDER	
Sht	SHEET	
Sim	SIMILAR	
SL	STATION LINE	
SM	SELECTED MATERIAL	
Spec	SPECIAL, SPECIFICATIONS	
SPP	SLOTTED PLASTIC PIPE	
SS	SLOPE STAKE	
SSBM	STRAP AND SADDLE BRACKET METHOD	
SSD	STRUCTURAL SECTION DRAIN	
SSPA	STRUCTURAL STEEL PLATE ARCH	
SSPP	STRUCTURAL STEEL PLATE PIPE	
SSPPA	STRUCTURAL STEEL PLATE PIPE ARCH	
SSRP	STEEL SPIRAL RIB PIPE	
St	STREET	
Sta	STATION	
STBB	SINGLE THRIE BEAM BARRIER	
Std	STANDARD	
Str	STRUCTURE	
Surf	SURFACING	
SW	SIDEWALK, SOUND WALL	
Swr	SEWER	
Sym	SYMMETRICAL	
S4S	SURFACE 4 SIDES	
	T	
T	SEMI-TANGENT	
Tan	TANGENT	
TBB	THRIE BEAM BARRIER	
Tbr	TIMBER	
TC	TOP OF CURB	
TCB	TRAFFIC CONTROL BOX	
TCE	TEMPORARY CONSTRUCTION EASEMENT	
TeI	TELEPHONE	
Temp	TEMPORARY	
TG	TOP OF GRADE	
Tot	TOTAL	
TP	TELEPHONE POLE	
TPB	TREATED PERMEABLE BASE	
TPM	TREATED PERMEABLE MATERIAL	
Trans	TRANSITION	

	T continued	
TS	TRANSVERSE, TRAFFIC SIGNAL, TUBULAR STEEL	
Typ	TYPICAL	U
UC	UNDERCROSSING	
UD	UNDERDRAIN	
UG	UNDERGROUND	
UON	UNLESS OTHERWISE NOTED	
UP	UNDERPASS	V
V	VALVE, DESIGN SPEED	
Var	VARIABLE, VARIES	
VC	VERTICAL CURVE	
VCP	VITRIFIED CLAY PIPE	
Vert	VERTICAL	
Via	VIADUCT	
Vol	VOLUME	W
W	WEST, WIDTH	
WB	WESTBOUND	
WH	WEEP HOLE	
WM	WIRE MESH	
WS	WATER SURFACE	
WSP	WELDED STEEL PIPE	
Wt	WEIGHT	
WV	WATER VALVE	
WW	WINGWALL	
WWL	WINGWALL LAYOUT LINE	X
X Sec	CROSS SECTION	
Xing	CROSSING	Y
Yr	YEAR	
Yrs	YEARS	

Dist	COUNTY	ROUTE	POST MILES TOTAL PROJECT	SHEET No.	TOTAL SHEETS
03	Pla	89	9.0/12.5	10	17

Grace M. Tsushima
REGISTERED CIVIL ENGINEER

July 19, 2013
PLANS APPROVAL DATE

REGISTERED PROFESSIONAL ENGINEER
 Grace M. Tsushima
 No. C49814
 Exp. 9-30-14
 CIVIL
 STATE OF CALIFORNIA

THE STATE OF CALIFORNIA OR ITS OFFICERS OR AGENTS SHALL NOT BE RESPONSIBLE FOR THE ACCURACY OR COMPLETENESS OF SCANNED COPIES OF THIS PLAN SHEET.

TO ACCOMPANY PLANS DATED 12-28-15

UNIT OF MEASUREMENT SYMBOLS:
Some of the symbols used in the project plan quantity tables and in the Bid Item List are:

TABLE A

SYMBOL USED	DEFINITIONS
ACRE	ACRE
CF	CUBIC FOOT
CY	CUBIC YARD
EA	EACH
GAL	GALLON
LB	POUND
LF	LINEAR FOOT
SQFT	SQUARE FOOT
SQYD	SQUARE YARD
STA	100 FEET
TAB	TABLET
TON	2,000 POUNDS

Some of the symbols used in the plans other than in the project plan quantity tables are:

TABLE B

SYMBOL USED	DEFINITIONS
ksi	KIPS PER SQUARE INCH
ksf	KIPS PER SQUARE FOOT
psi	POUNDS PER SQUARE INCH
psf	POUNDS PER SQUARE FOOT
lb/ft ³ , pcf	POUNDS PER CUBIC FOOT
tsf	TONS PER SQUARE FOOT
mph, MPH *	MILES PER HOUR
ø	NOMINAL DIAMETER
oz	OUNCE
lb	POUND
kíp	1,000 POUNDS
cal	CALORIE
ft	FOOT OR FEET
gal	GALLON

* For use on a sign panel only

STATE OF CALIFORNIA
DEPARTMENT OF TRANSPORTATION

**ABBREVIATIONS
(SHEET 2 OF 2)**

NO SCALE

RSP A10B DATED JULY 19, 2013 SUPERSEDES STANDARD PLAN A10B
DATED MAY 20, 2011 - PAGE 2 OF THE STANDARD PLANS BOOK DATED 2010.












2010 REVISED STANDARD PLAN RSP A10B

Dist	COUNTY	ROUTE	POST MILES TOTAL PROJECT	SHEET No.	TOTAL SHEETS
03	Pla	89	9.0/12.5	11	17



Roberta L. McLaughlin
 REGISTERED CIVIL ENGINEER
 July 20, 2012
 PLANS APPROVAL DATE

THE STATE OF CALIFORNIA OR ITS OFFICERS OR AGENTS SHALL NOT BE RESPONSIBLE FOR THE ACCURACY OR COMPLETENESS OF SCANNED COPIES OF THIS PLAN SHEET.

TO ACCOMPANY PLANS DATED 12-28-15

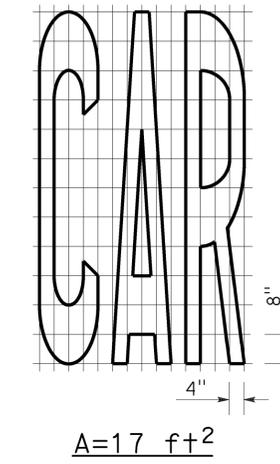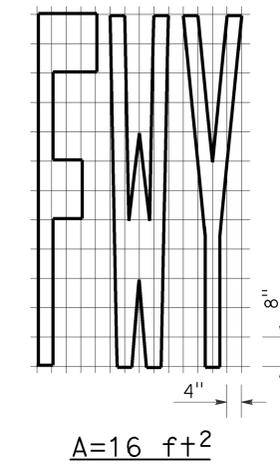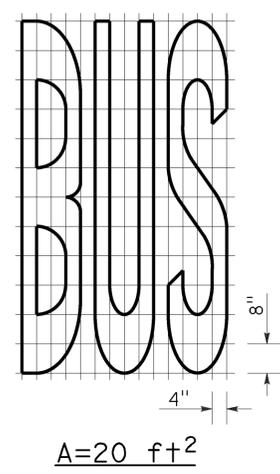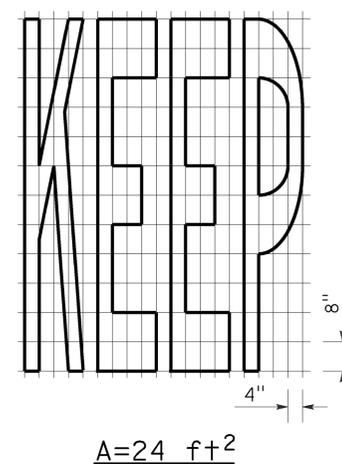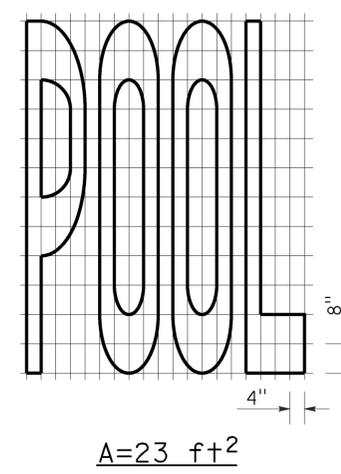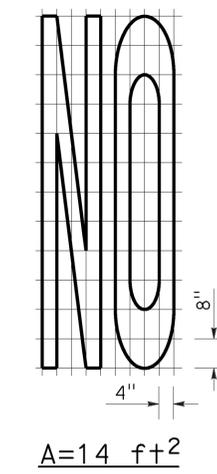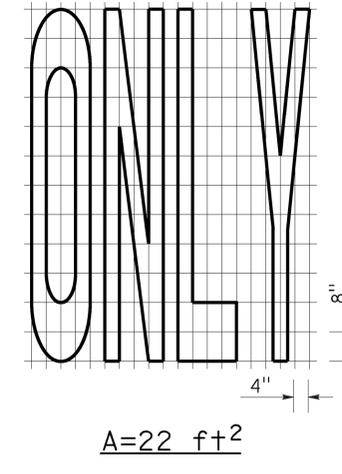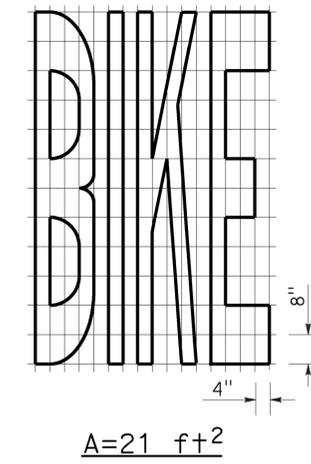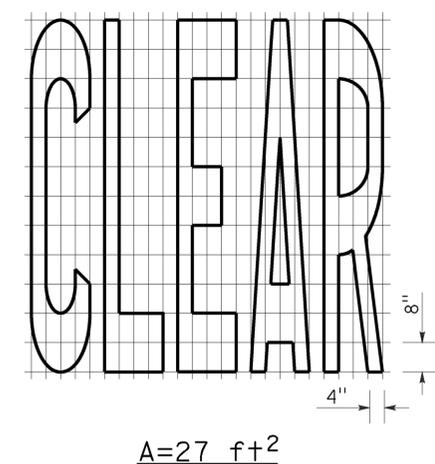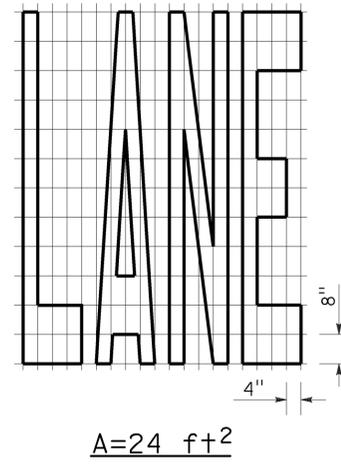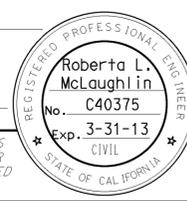

WORD MARKINGS			
ITEM	ft ²	ITEM	ft ²
LANE	24	NO	14
POOL	23	BIKE	21
CAR	17	BUS	20
CLEAR	27	ONLY	22
KEEP	24	FWY	16

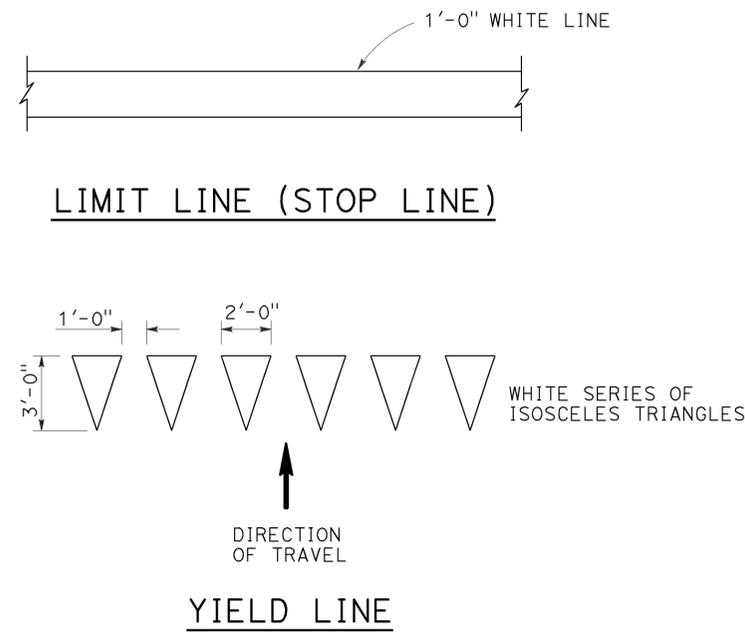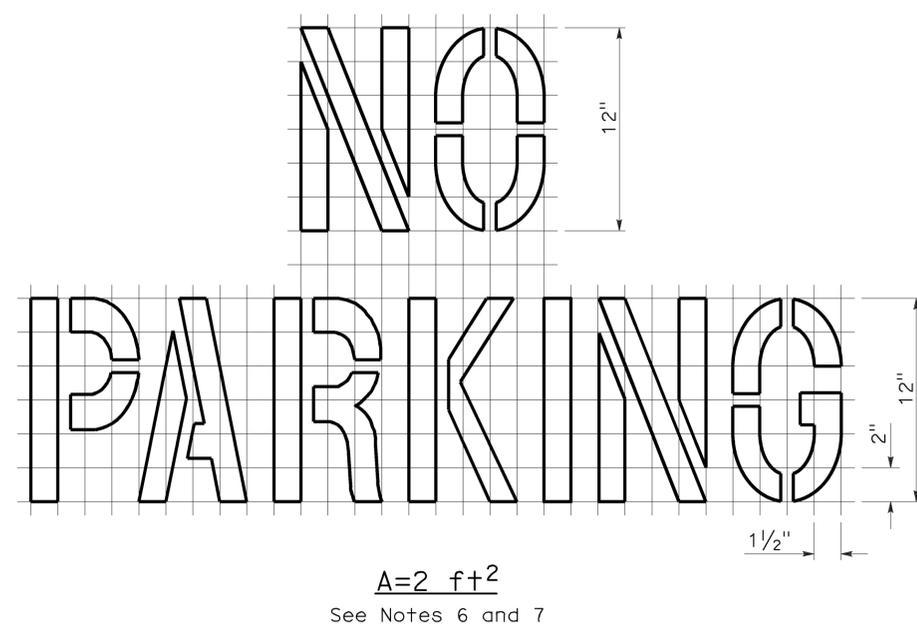

NOTES:

1. If a message consists of more than one word, it should read "UP", i.e., the first word should be nearest the driver.
2. The space between words should be at least four times the height of the characters for low speed roads, but not more than ten times the height of the characters. The space may be reduced appropriately where there is limited space because of local conditions.
3. Minor variations in dimensions may be accepted by the Engineer.
4. Portions of a letter, number or symbol may be separated by connecting segments not to exceed 2" in width.
5. The words "NO PARKING" pavement marking is to be used for parking facilities. For typical locations of markings, see Standard Plans A90A and A90B.
6. The words "NO PARKING", shall be painted in white letters no less than 1'-0" high on a contrasting background and located so that it is visible to traffic enforcement officials.

STATE OF CALIFORNIA
DEPARTMENT OF TRANSPORTATION


**PAVEMENT MARKINGS
WORDS, LIMIT AND YIELD LINES**

NO SCALE

RSP A24E DATED JULY 20, 2012 SUPERSEDES STANDARD PLAN A24E
DATED MAY 20, 2011 - PAGE 17 OF THE STANDARD PLANS BOOK DATED 2010.

2010 REVISED STANDARD PLAN RSP A24E

Dist	COUNTY	ROUTE	POST MILES TOTAL PROJECT	SHEET No.	TOTAL SHEETS
03	Pla	89	9.0/12.5	12	17

 
 REGISTERED CIVIL ENGINEER
 July 19, 2013
 PLANS APPROVAL DATE



THE STATE OF CALIFORNIA OR ITS OFFICERS OR AGENTS SHALL NOT BE RESPONSIBLE FOR THE ACCURACY OR COMPLETENESS OF SCANNED COPIES OF THIS PLAN SHEET.

TO ACCOMPANY PLANS DATED 12-28-15

TABLE 1

TAPER LENGTH CRITERIA AND CHANNELIZING DEVICE SPACING							
SPEED (S)	MINIMUM TAPER LENGTH * FOR WIDTH OF OFFSET 12 FEET (W)				MAXIMUM CHANNELIZING DEVICE SPACING		
	TANGENT 2L	MERGING L	SHIFTING L/2	SHOULDER L/3	X	Y	Z **
					TAPER	TANGENT	CONFLICT
mph	ft	ft	ft	ft	ft	ft	ft
20	160	80	40	27	20	40	10
25	250	125	63	42	25	50	12
30	360	180	90	60	30	60	15
35	490	245	123	82	35	70	17
40	640	320	160	107	40	80	20
45	1080	540	270	180	45	90	22
50	1200	600	300	200	50	100	25
55	1320	660	330	220	55	110	27
60	1440	720	360	240	60	120	30
65	1560	780	390	260	65	130	32
70	1680	840	420	280	70	140	35

* - For other offsets, use the following merging taper length formula for L:
 For speed of 40 mph or less, $L = WS^2/60$
 For speed of 45 mph or more, $L = WS$

Where: L = Taper length in feet
 W = Width of offset in feet
 S = Posted speed limit, off-peak 85th-percentile speed prior to work starting, or the anticipated operating speed in mph

** - Use for taper and tangent sections where there are no pavement markings or where there is a conflict between existing pavement markings and channelizers (CA).

TABLE 2

LONGITUDINAL BUFFER SPACE AND FLAGGER STATION SPACING				
SPEED *	Min D **	DOWNGRADE Min D ***		
		-3%	-6%	-9%
		ft	ft	ft
20	115	116	120	126
25	155	158	165	173
30	200	205	215	227
35	250	257	271	287
40	305	315	333	354
45	360	378	400	427
50	425	446	474	507
55	495	520	553	593
60	570	598	638	686
65	645	682	728	785
70	730	771	825	891

* - Speed is posted speed limit, off-peak 85th-percentile speed prior to work starting, or the anticipated operating speed in mph
 ** - Longitudinal buffer space or flagger station spacing
 *** - Use on sustained downgrade steeper than -3 percent and longer than 1 mile.

TABLE 3

ADVANCE WARNING SIGN SPACING			
ROAD TYPE	DISTANCE BETWEEN SIGNS *		
	A	B	C
	ft	ft	ft
URBAN - 25 mph OR LESS	100	100	100
URBAN - MORE THAN 25 mph TO 40 mph	250	250	250
URBAN - MORE THAN 40 mph	350	350	350
RURAL	500	500	500
EXPRESSWAY / FREEWAY	1000	1500	2640

* - The distances are approximate, are intended for guidance purposes only, and should be applied with engineering judgment. These distances should be adjusted by the Engineer for field conditions, if necessary, by increasing or decreasing the recommended distances.

STATE OF CALIFORNIA
 DEPARTMENT OF TRANSPORTATION

TRAFFIC CONTROL SYSTEM TABLES FOR LANE AND RAMP CLOSURES

NO SCALE

RSP T9 DATED JULY 19, 2013 SUPERSEDES RSP T9 DATED APRIL 19, 2013 THAT SUPPLEMENTS THE STANDARD PLANS BOOK DATED 2010.

2010 REVISED STANDARD PLAN RSP T9

NOTES:

See Revised Standard Plan RSP T9 for tables.

Use cone spacing X for taper segment, Y for tangent segment or Z for conflict situations, as appropriate, per Table 1, unless X, Y, or Z cone spacing is shown on this sheet.

Unless otherwise specified in the special provisions, all temporary warning signs shall have black legend on fluorescent orange background.

California codes are designated by (CA). Otherwise, Federal (MUTCD) codes are shown.

Dist	COUNTY	ROUTE	POST MILES TOTAL PROJECT	SHEET No.	TOTAL SHEETS
03	Pla	89	9.0/12.5	13	17

Devinder Singh
REGISTERED CIVIL ENGINEER


October 30, 2015
PLANS APPROVAL DATE

REGISTERED PROFESSIONAL ENGINEER
Devinder Singh
No. C50470
Exp. 6-30-17
CIVIL
STATE OF CALIFORNIA

THE STATE OF CALIFORNIA OR ITS OFFICERS OR AGENTS SHALL NOT BE RESPONSIBLE FOR THE ACCURACY OR COMPLETENESS OF SCANNED COPIES OF THIS PLAN SHEET.


TYPICAL LANE CLOSURE WITH REVERSIBLE CONTROL

TO ACCOMPANY PLANS DATED 12-28-15

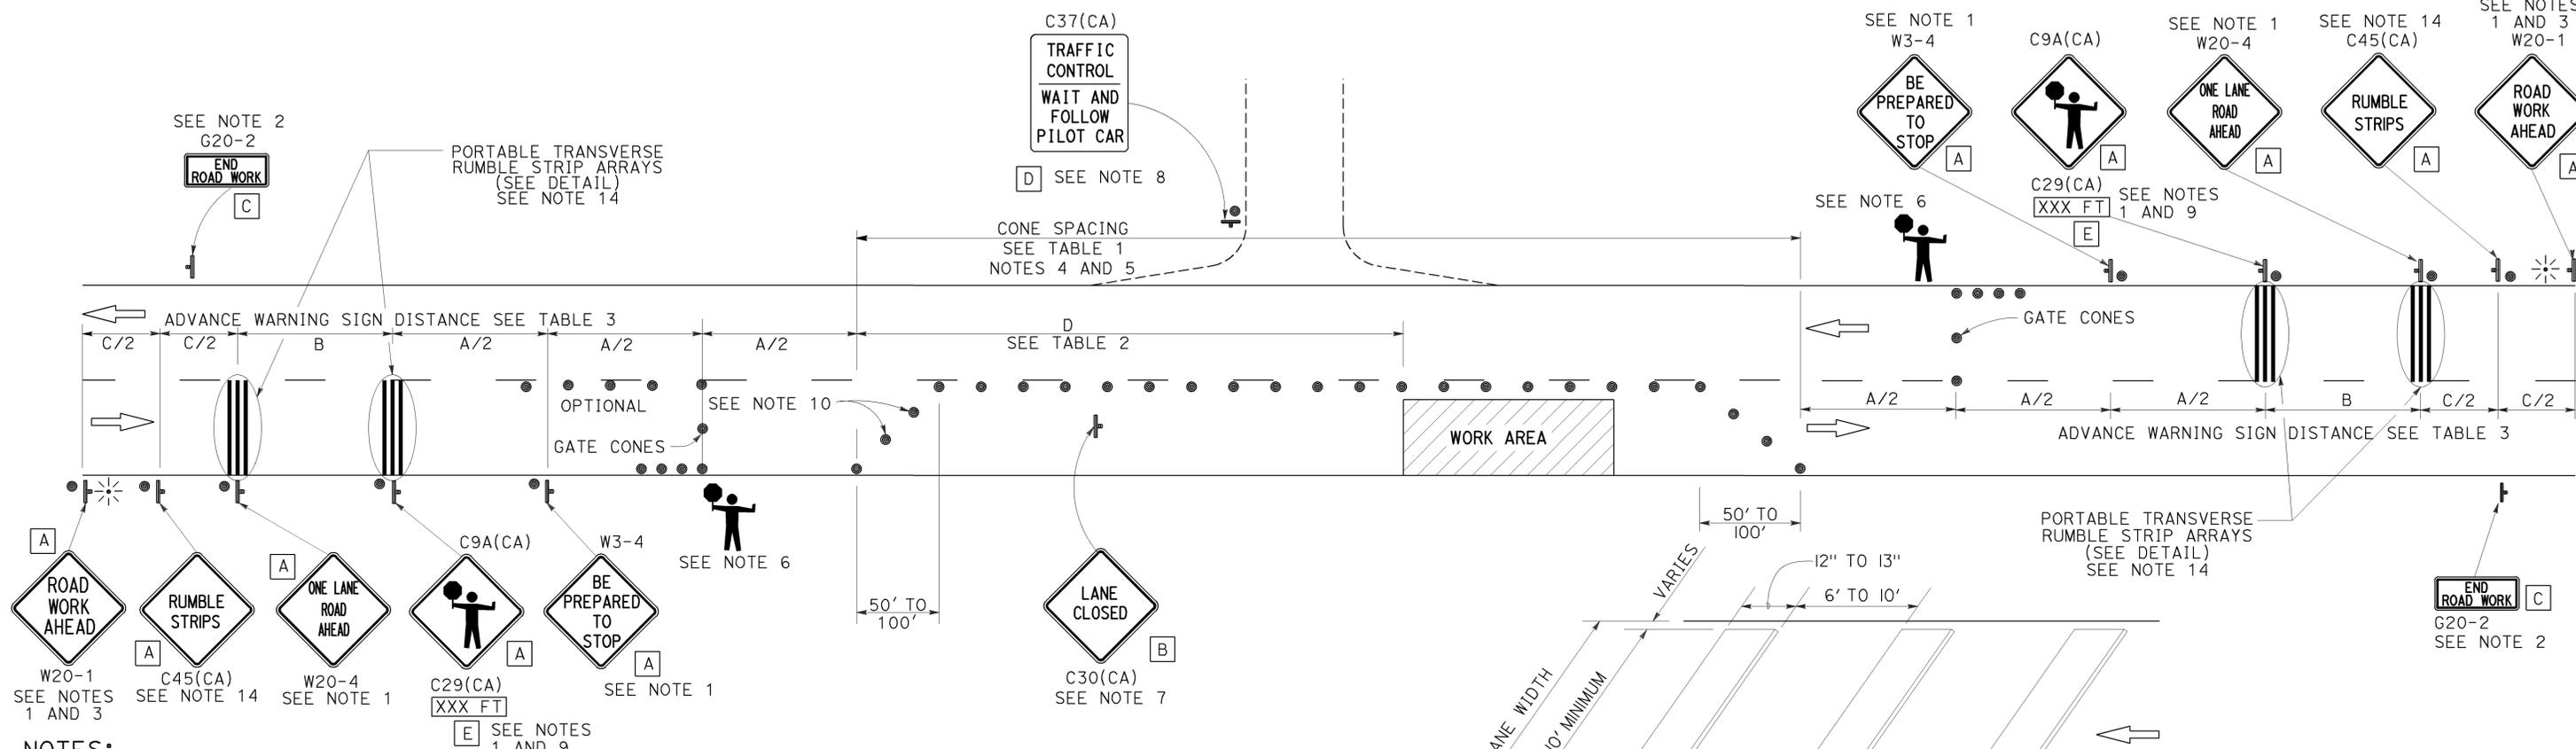

NOTES:

- Each advance warning sign in each direction of travel shall be equipped with at least two flags for daytime closure. Each flag shall be at least 16" x 16" in size and shall be orange or fluorescent red-orange in color. Flashing beacons shall be placed at the locations indicated for lane closure during hours of darkness.
- A G20-2 "END ROAD WORK" sign, as appropriate, shall be placed at the end of the lane control unless the end of work area is obvious, or ends within a larger project's limits.
- If the W20-1 sign would follow within 2000' of a stationary W20-1 or G20-1 "ROAD WORK NEXT _____ MILES", use a W20-4 sign for the first advance warning sign.
- All cones used for lane closures during the hours of darkness shall be fitted with retroreflective bands (or sleeves) as specified in the specifications.
- Portable delineators, placed at one-half the spacing indicated for traffic cones, may be used instead of cones for daytime closures only.
- Additional advance flaggers may be required. Flagger should stand in a conspicuous place, be visible to approaching traffic as well as approaching vehicles after the first vehicle has stopped. During the hours of darkness, the flagging-station and flagger shall be illuminated and clearly visible to approaching traffic. The illumination footprint of the lighting on the ground shall be at least 20' in diameter. Place a minimum of four cones at 50' intervals in advance of flagger station as shown.
- Place C30(CA) "LANE CLOSED" sign at 500' to 1000' intervals throughout extended work areas. They are optional if the work area is visible from the flagger station.
- When a pilot car is used, place a C37(CA) "TRAFFIC CONTROL-WAIT AND FOLLOW PILOT CAR" sign with black legend on white background at all intersections, driveways and alleys without a flagger within traffic control area. Signs shall be clean and visible at all times. Where traffic can not be effectively self-regulated, at least one flagger shall be used at each intersection within traffic control area.
- An optional C29(CA) sign may be placed below the C9A(CA) sign.
- Either traffic cones or barricades shall be placed on the taper. Barricades shall be Type I, II, or III.
- The color of the portable transverse rumble strips shall be black or orange. Use 2 arrays, each array shall consist of 3 rumble strips.
- Portable transverse rumble strips shall not be placed on sharp horizontal or vertical curves nor shall they be placed through pedestrian crossings.
- If the portable transverse rumble strips become out of alignment (skewed) by more than 6 inches, measured from one end to the other, they shall be readjusted to bring the placement back to the original location.
- Portable transverse rumble strips are not required if any one of the following conditions is satisfied:
 - Work duration occupies a location for four hours or less
 - Posted speed limit is below 45 MPH
 - Work is of emergency nature
 - Work zone is in snow or icy weather conditions

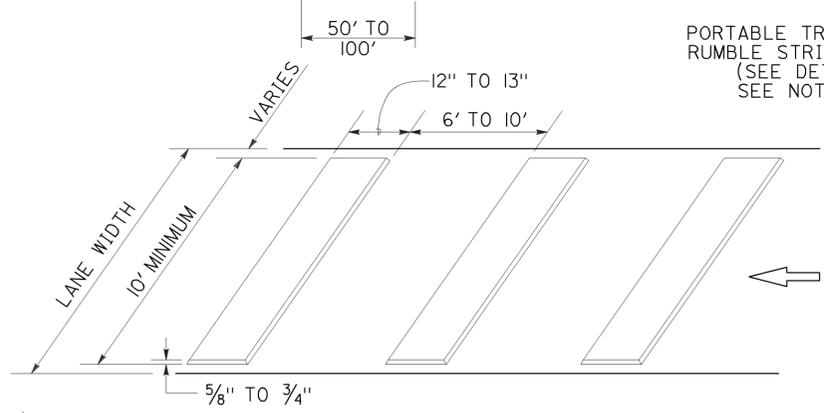

PORTABLE TRANSVERSE RUMBLE STRIP ARRAY DETAIL

SIGN PANEL SIZE (Min)

- A 48" x 48"
- B 30" x 30"
- C 36" x 18"
- D 36" x 42"
- E 20" x 7"

LEGEND

- TRAFFIC CONE
- ⊥ TEMPORARY TRAFFIC CONTROL SIGN
- ⚡ PORTABLE FLASHING BEACON
- 🚧 FLAGGER

STATE OF CALIFORNIA
DEPARTMENT OF TRANSPORTATION

TRAFFIC CONTROL SYSTEM FOR LANE CLOSURE ON TWO LANE CONVENTIONAL HIGHWAYS

NO SCALE


RSP T13 DATED OCTOBER 30, 2015 SUPERSEDES RSP T13 DATED OCTOBER 17, 2014, RSP T13 DATED JULY 18, 2014 AND RSP T13 DATED APRIL 19, 2013 AND STANDARD PLAN T13 DATED MAY 20, 2011 - PAGE 241 OF THE STANDARD PLANS BOOK DATED 2010.

REVISED STANDARD PLAN RSP T13

2010 REVISED STANDARD PLAN RSP T13



TO ACCOMPANY PLANS DATED 12-28-15

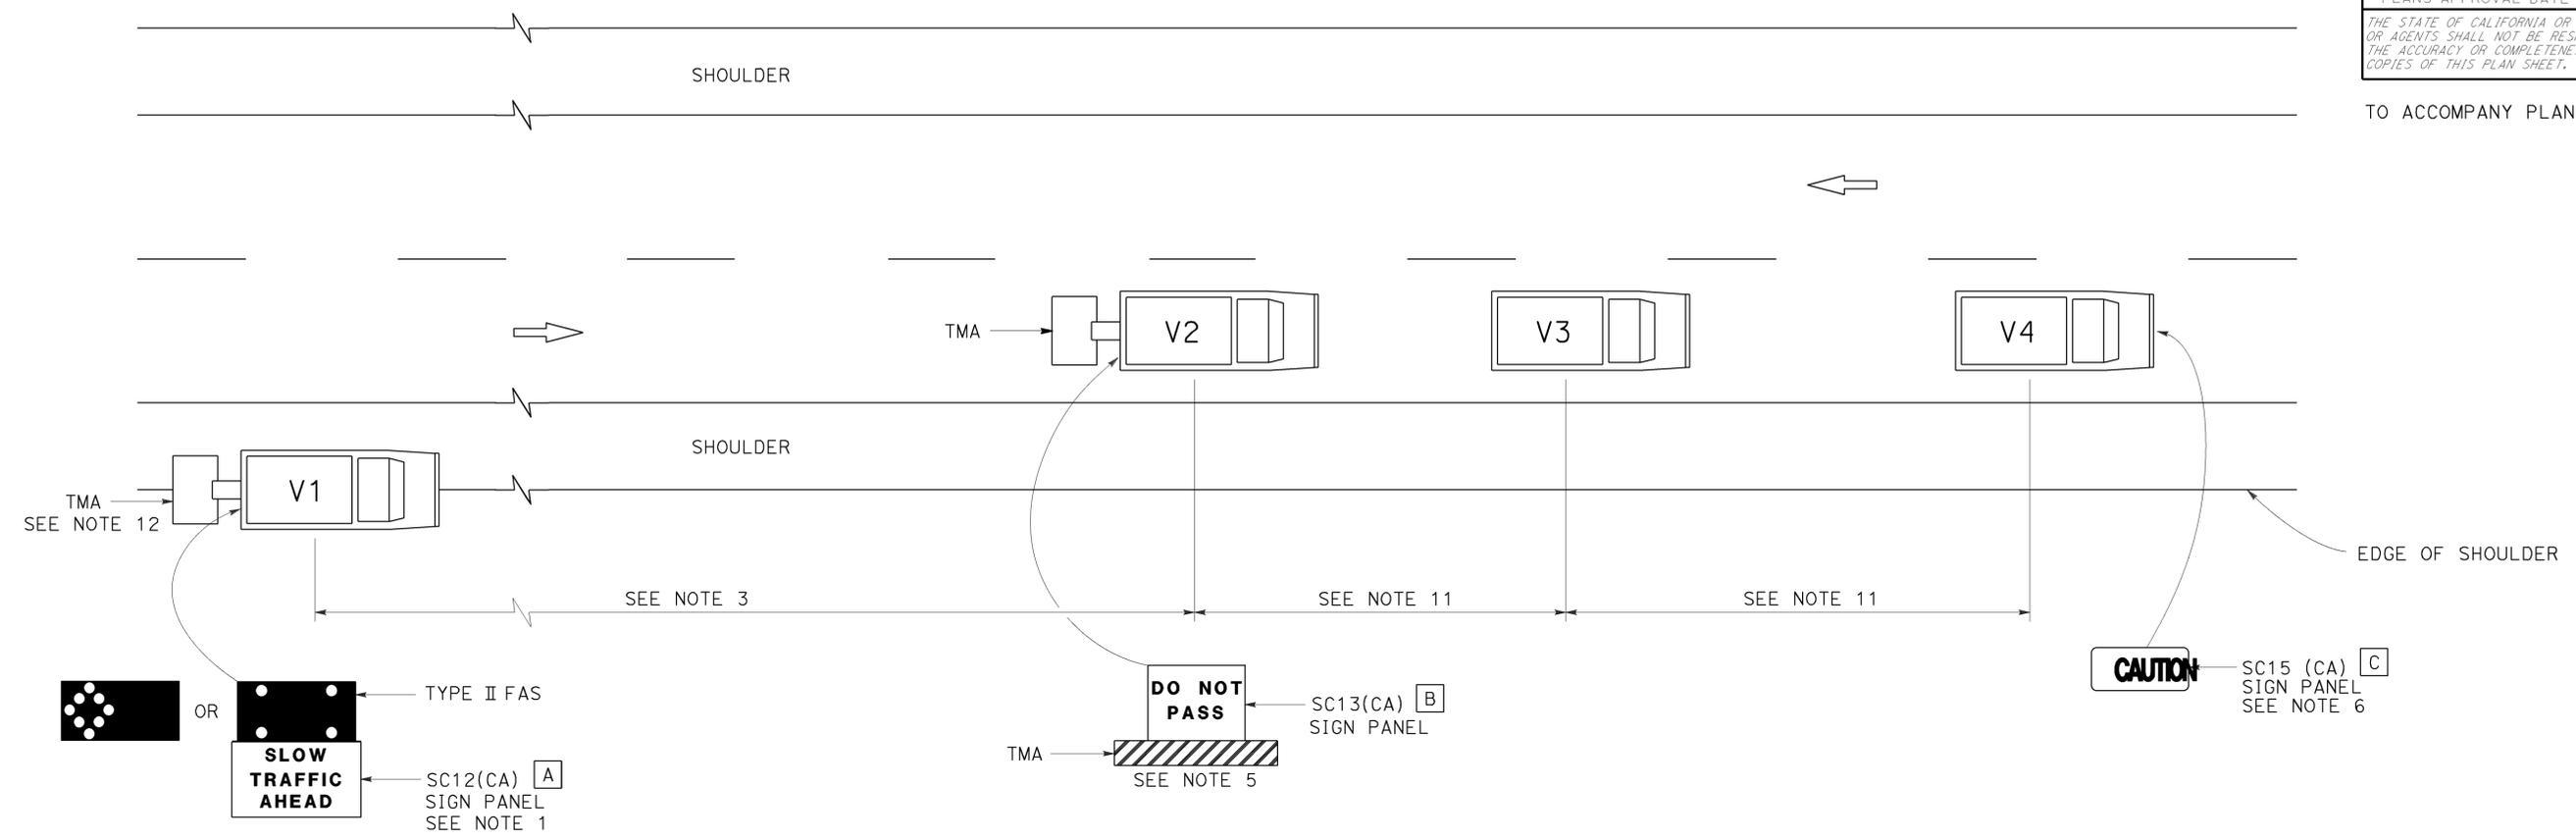

NOTES:

1. Either a changeable message sign or a SC12(CA) "SLOW TRAFFIC AHEAD" sign shall be mounted on the rear of sign vehicle V1. The changeable message sign shall be sequenced to show the "CAUTION" message first, follow by the "SLOW TRAFFIC AHEAD" message. A Type II flashing arrow sign may be used with the SC12(CA) sign panel.
2. Sign vehicle V1 should be positioned where highly visible when shoulders are not available.
3. If traffic queues develop, sign vehicle V1 should be positioned upstream from the end of queue.
4. Vehicle-mounted sign panels shall have Type III or above retroreflective sheeting, black on white, or black on fluorescent orange, with 6" minimum series D letters per Caltrans sign specifications.
5. Shadow vehicle shall be equipped with a truck-mounted attenuator. The sign panel shown shall be mounted on the rear of shadow vehicle V2. The message "LANE CLOSED" may be used in place of the "DO NOT PASS" message.
6. The sign panel shown shall be mounted on the front of sign vehicle V4, facing opposing traffic.

7. All vehicles shall be equipped with flashing or rotating amber lights.
8. Sign vehicle V4 will not be required when the work and vehicles V2 and V3 are 2' or more from the centerline of the highway during the work or application operations.
9. All vehicles used for lane closures shall be equipped with two-way radios and the vehicle operators shall maintain communication during the work or application operation.
10. This plan shall not be used where workers would be on foot in the work area. Use a stationary type lane closure (Revised Standard Plan T13) for this condition.
11. Minimize spacing between vehicles V2 and V3 and vehicles V3 and V4 to deter road users from driving in between them.
12. If sign vehicle V1 encroaches into the traffic lane due to insufficient shoulder width, sign vehicle V1 shall be equipped with a truck-mounted attenuator. Sign vehicle V1 shall stay as close to the edge of shoulder as practicable.

LEGEND

- V1 SIGN VEHICLE
- V2 SHADOW VEHICLE
- V3 WORK/APPLICATION VEHICLE
- V4 SIGN VEHICLE
- TMA TRUCK-MOUNTED ATTENUATOR
-  FLASHING ARROW SIGN (FAS) IN FLASHING CAUTION MODE
-  FLASHING ARROW SIGN (FAS) IN ALTERNATING DIAMOND CAUTION

SIGN PANEL SIZE (Min)

- A** 72" x 42"
- B** 54" x 42"
- C** 54" x 24"

STATE OF CALIFORNIA
 DEPARTMENT OF TRANSPORTATION
**TRAFFIC CONTROL SYSTEM
 FOR MOVING LANE CLOSURE
 ON TWO LANE HIGHWAYS**
 NO SCALE

RSP T17 DATED APRIL 19, 2013 SUPERSEDES STANDARD PLAN T17
 DATED MAY 20, 2011 - PAGE 245 OF THE STANDARD PLANS BOOK DATED 2010.

REVISED STANDARD PLAN RSP T17

2010 REVISED STANDARD PLAN RSP T17

LEGEND:

AB	ABANDON. IF APPLIED TO CONDUIT, REMOVE CONDUCTORS
BC	INSTALL PULL BOX IN EXISTING CONDUIT RUN
BP	PEDESTRIAN BARRICADE, TYPE AS INDICATED ON PLAN
CB	INSTALL CONDUIT INTO EXISTING PULL BOX
CC	CONNECT NEW AND EXISTING CONDUIT. REMOVE EXISTING CONDUCTORS AND INSTALL CONDUCTORS AS INDICATED
CF	CONDUIT TO REMAIN FOR FUTURE USE. REMOVE CONDUCTORS. INSTALL PULL TAPE
DH	DETECTOR HANDHOLE
FA	FOUNDATION TO BE ABANDONED
IS	INSTALL SIGN ON SIGNAL MAST ARM
NS	NO SLIP BASE ON STANDARD
PEC	PHOTOELECTRIC CONTROL
PEU	PHOTOELECTRIC UNIT
RC	EQUIPMENT OR MATERIAL TO BE REMOVED AND BECOME THE PROPERTY OF THE CONTRACTOR
RE	REMOVE ELECTROLIER, FUSES AND BALLAST. TAPE ENDS OF CONDUCTORS
RL	RELOCATE EQUIPMENT
RR	REMOVE AND REUSE EQUIPMENT
RS	REMOVE AND SALVAGE EQUIPMENT
SC	SPLICE NEW TO EXISTING CONDUCTORS
SD	SERVICE DISCONNECT
TSP	TELEPHONE SERVICE POINT

ABBREVIATIONS

AC+	UNDERGROUNDED CONDUCTOR	MAT	MAST ARM MOUNTING TOP ATTACHMENT
APS	ACCESSIBLE PEDESTRIAN SIGNAL	MAS	MAST ARM MOUNTING SIDE ATTACHMENT
Batt	BATTERY	MBPS	MANUAL BYPASS SWITCH
BBS	BATTERY BACKUP SYSTEM	M/M	MULTIPLE TO MULTIPLE TRANSFORMER
BC	BOLT CIRCLE	Mtg	MOUNTING
BIK	BLACK	MV	MERCURY VAPOR LIGHTING FIXTURE
BP	BYPASS	MVDS	MICROWAVE VEHICLE DETECTION SYSTEM
BPB	BICYCLE PUSH BUTTON	N	NEUTRAL (GROUNDED CONDUCTOR)
C	CONDUIT	NB	NEUTRAL BUS
CB	CIRCUIT BREAKER	NC	NORMALLY CLOSE
CCTV	CLOSED CIRCUIT TELEVISION	NO	NORMALLY OPEN
Ckt	CIRCUIT	P	CIRCUIT BREAKER'S POLE
CMS	CHANGEABLE MESSAGE SIGN	PB	PULL BOX
Ctid	CALTRANS IDENTIFICATION	PBA	PUSH BUTTON ASSEMBLY
Comm	COMMUNICATION	PEC	PHOTOELECTRIC CONTROL
Cntl	CONTROL	Ped	PEDESTRIAN
DF	DEPARTMENT-FURNISHED	PEU	PHOTOELECTRIC UNIT
DLC	LOOP DETECTOR LEAD-IN CABLE	PT	CONDUIT WITH PULL TAPE
EMS	EXTINGUISHABLE MESSAGE SIGN	PTR	POWER TRANSFER RELAY
EVUC	EMERGENCY VEHICLE UNIT CABLE	RE	RELOCATED EQUIPMENT
EVUD	EMERGENCY VEHICLE UNIT DETECTOR	RM	RAMP METERING
FB	FLASHING BEACON	RWIS	ROADSIDE WEATHER INFORMATION SYSTEM
FBCA	FLASHING BEACON CONTROL ASSEMBLY	SB	SLIP BASE
FBS	FLASHING BEACON WITH SLIP BASE	SIC	SIGNAL INTERCONNECT CABLE
FO	FIBER OPTIC	Sig	SIGNAL
G	EQUIPMENT GROUNDING CONDUCTOR	SMA	SIGNAL MAST ARM
GB	GROUND BUS	SNS	STREET NAME SIGN
GFCI	GROUND FAULT CIRCUIT INTERRUPTER	SP	SERVICE POINT
Grn	GREEN	TB	TERMINAL BOARD
HAR	HIGHWAY ADVISORY RADIO	TDC	TELEPHONE DEMARCATION CABINET
Hex	HEXAGONAL	Temp	TEMPERATURE
HPS	HIGH PRESSURE SODIUM	TMS	TRAFFIC MONITORING STATION
IISNS	INTERNALLY ILLUMINATED STREET NAME SIGN	TOS	TRAFFIC OPERATIONS SYSTEM
ISL	INDUCTION SIGN LIGHTING	UPS	UNINTERRUPTABLE POWER SUPPLY
LED	LIGHT EMITTING DIODE	UPSC	UNINTERRUPTABLE POWER SUPPLY CONTROLLER
LMA	LUMINAIRE MAST ARM	Veh	VEHICLE
LPS	LOW PRESSURE SODIUM	VIVDS	VIDEO IMAGE VEHICLE DETECTION SYSTEM
Ltg	LIGHTING	Wht	WHITE
Lum	LUMINAIRE	WIM	WEIGH-IN-MOTION
M	METERED	Xfmr	TRANSFORMER

Dist	COUNTY	ROUTE	POST MILES TOTAL PROJECT	SHEET No.	TOTAL SHEETS
03	Pla	89	9.0/12.5	15	17

Theresa Gabriel
REGISTERED ELECTRICAL ENGINEER

October 30, 2015
PLANS APPROVAL DATE

Theresa
Aziz Gabriel
No. E15129
Exp. 6-30-16
ELECTRICAL
STATE OF CALIFORNIA

THE STATE OF CALIFORNIA OR ITS OFFICERS OR AGENTS SHALL NOT BE RESPONSIBLE FOR THE ACCURACY OR COMPLETENESS OF SCANNED COPIES OF THIS PLAN SHEET.

TO ACCOMPANY PLANS DATED 12-28-15

SOFFIT AND WALL-MOUNTED LUMINAIRES

- PENDANT SOFFIT LUMINAIRE, 70 W HPS UNLESS OTHERWISE SPECIFIED
- FLUSH-MOUNTED SOFFIT LUMINAIRE, 70 W HPS UNLESS OTHERWISE SPECIFIED
- WALL-MOUNTED LUMINAIRE, 70 W HPS UNLESS OTHERWISE SPECIFIED
- EXISTING SOFFIT OR WALL-MOUNTED LUMINAIRE TO REMAIN UNMODIFIED
- EXISTING SOFFIT OR WALL-MOUNTED LUMINAIRE TO BE MODIFIED AS SPECIFIED

NOTE:

Arrow indicates "street side" of luminaire.

COMMONLY USED SYMBOLS FOR UNITED STATES CUSTOMARY UNITS OF MEASUREMENT:

SYMBOL	DEFINITIONS
Ω	OHMS
min	MINUTE
s	SECOND
bps	BITS PER SECOND
Bps	BYTES PER SECOND
A	AMPERE
V	VOLT
V(dc)	VOLT (DIRECT CURRENT)
V(ac)	VOLT (ALTERNATING CURRENT)
FC	FOOT - CANDLE
W	WATTS
VA	VOLT-AMPERE
M	MEGA
k	KILO
m	MILLI
μ	MICRO
P	PICO
Hz	HERTZ

STATE OF CALIFORNIA
DEPARTMENT OF TRANSPORTATION

ELECTRICAL SYSTEMS (LEGEND AND ABBREVIATIONS)

NO SCALE

RSP ES-1A DATED OCTOBER 30, 2015 SUPERSEDES RSP ES-1A DATED JULY 19, 2013 AND STANDARD PLAN ES-1A DATED MAY 20, 2011 - PAGE 425 OF THE STANDARD PLANS BOOK DATED 2010.

REVISED STANDARD PLAN RSP ES-1A

MISCELLANEOUS ELECTROLIERS

NEW	EXISTING	
		LUMINAIRE ON WOOD POLE
		NON-STANDARD ELECTROLIER (SEE PROJECT LEGEND)
		CITY ELECTROLIER
		ELECTROLIER FOUNDATION (FUTURE INSTALLATION)

NOTES:

- LED luminaires shall be 235 W when installed on Type 21, 21D, 30, 31 and 32 Standards, unless otherwise specified. LED luminaires shall be 165 W when installed on other type standards or poles, unless otherwise specified.
- Luminaires shall be the cutoff type, ANSI Type III medium cutoff lighting distribution, unless otherwise specified.

STANDARD ELECTROLIER

NEW	EXISTING	STANDARD TYPE
		15
		15D
		15 STRUCTURE
		15D STRUCTURE
		21
		21D
		21 STRUCTURE
		21D STRUCTURE
		30
		31
		32

Dist	COUNTY	ROUTE	POST MILES TOTAL PROJECT	SHEET No.	TOTAL SHEETS
03	Pla	89	9.0/12.5	16	17

Theresa Gabriel
REGISTERED ELECTRICAL ENGINEER
October 30, 2015
PLANS APPROVAL DATE

THE STATE OF CALIFORNIA OR ITS OFFICERS OR AGENTS SHALL NOT BE RESPONSIBLE FOR THE ACCURACY OR COMPLETENESS OF SCANNED COPIES OF THIS PLAN SHEET.

TO ACCOMPANY PLANS DATED 12-28-15

CONDUIT

SIGNAL EQUIPMENT

NEW	EXISTING	
---	---	LIGHTING CONDUIT, UNLESS OTHERWISE INDICATED OR NOTED
---	---	TRAFFIC SIGNAL CONDUIT
---C---	---c---	COMMUNICATION CONDUIT
---T---	---t---	TELEPHONE CONDUIT
---F---	---f---	FIRE ALARM CONDUIT
---FO---	---fo---	FIBER OPTIC CONDUIT
---	---	CONDUIT TERMINATION
		CONDUIT RISER ATTACHED TO THE STRUCTURE OR SERVICE POLE

NEW	EXISTING	
		PEDESTRIAN SIGNAL HEAD
		PUSH BUTTON ASSEMBLY POST
		PEDESTRIAN BARRICADE
		VEHICLE SIGNAL HEAD (WITH BACKPLATE AND 3-SECTIONS: RED, YELLOW AND GREEN)
		VEHICLE SIGNAL HEAD WITH ANGLE VISOR
		MODIFICATIONS OF BASIC SYMBOL: "L" INDICATES ALL NON-ARROW SECTIONS LOUVERED "LG" INDICATES LOUVERED GREEN SECTION ONLY "PV" INDICATES ALL 12" SECTIONS PROGRAMMED VISIBILITY "8" INDICATES ALL 8" SECTIONS (ONLY WHEN SPECIFIED)

SERVICE EQUIPMENT

NEW	EXISTING	
---OH---	---oh---	OVERHEAD LINES
		WOOD POLE, "U" INDICATES UTILITY OWNED
		POLE GUY WITH ANCHOR
		UTILITY TRANSFORMER - GROUND MOUNTED
		SERVICE EQUIPMENT ENCLOSURE TYPE. DOOR INDICATES FRONT OF ENCLOSURE
		TELEPHONE DEMARCATION CABINET

POLE-MOUNTED SERVICE DESIGNATION

	TYPE H SERVICE, 28'-10"	TYPE OF INSTALLATION AND POLE HEIGHT ABOVE GRADE
--	-------------------------	--

FLASHING BEACON

NEW	EXISTING	
		FLASHING BEACON (ONE VEHICLE SIGNAL HEAD WITH BACKPLATE AND VISOR) "R" INDICATES RED INDICATION, "Y" INDICATES YELLOW INDICATION
		FLASHING BEACON WITH TYPE 15-FBS STANDARD AND A SIGN.
		FLASHING BEACON WITH TYPES 9, 9A OR 9B SIGN UNLESS OTHERWISE SPECIFIED OR INDICATED

		VEHICLE SIGNAL HEAD CONSISTING OF RED, YELLOW AND GREEN LEFT ARROW SECTIONS
		VEHICLE SIGNAL HEAD CONSISTING OF RED AND YELLOW SECTIONS WITH AN UP GREEN ARROW SECTION
		VEHICLE SIGNAL HEAD (5 SECTION) CONSISTING OF RED, YELLOW AND GREEN SECTIONS WITH YELLOW AND GREEN RIGHT ARROW SECTIONS
		TYPE 15TS STANDARD WITH VEHICLE SIGNAL HEAD AND LUMINAIRE
		TYPE 21TS STANDARD WITH VEHICLE SIGNAL HEAD AND LUMINAIRE
		STANDARD WITH LUMINAIRE AND SIGNAL MAST ARMS AND ATTACHED VEHICLE SIGNAL HEADS
		TYPE 1 STANDARD WITH ATTACHED VEHICLE SIGNAL HEADS
		STANDARD WITH A SIGNAL MAST ARM, ATTACHED VEHICLE SIGNAL HEADS AND INTERNALLY ILLUMINATED STREET NAME SIGN
		CONTROLLER ASSEMBLY. DOOR INDICATES FRONT OF CABINET

SIGNAL EQUIPMENT Cont

NEW	EXISTING	
		GUARD POST
		TYPE 1 STANDARD WITH RAMP METERING SIGN
		OPTICAL DETECTOR FOR THE EMERGENCY VEHICLE DETECTION

NOTES:

- All signal sections shall be 12" unless shown otherwise.
- Signal heads shall be provided with backplates unless shown otherwise.

ILLUMINATED OVERHEAD SIGN

NEW	EXISTING	
		SINGLE POST, SINGLE ILLUMINATED SIGN, BALANCED BUTTERFLY
		SINGLE POST, DOUBLE ILLUMINATED SIGN, BALANCED BUTTERFLY
		SINGLE POST, SINGLE ILLUMINATED SIGN, FULL CANTILEVER
		DOUBLE POST, SINGLE ILLUMINATED SIGN
		SINGLE ILLUMINATED SIGN MOUNTED ON STRUCTURE
		DOUBLE POST, SINGLE ILLUMINATED SIGN WITH ELECTROLIER

STATE OF CALIFORNIA
DEPARTMENT OF TRANSPORTATION
**ELECTRICAL SYSTEMS
(LEGEND AND ABBREVIATIONS)**

NO SCALE

RSP ES-1B DATED OCTOBER 30, 2015 SUPERSEDES RSP ES-1B DATED JULY 19, 2013 AND STANDARD PLAN ES-1B DATED MAY 20, 2011 - PAGE 426 OF THE STANDARD PLANS BOOK DATED 2010.

REVISED STANDARD PLAN RSP ES-1B


2010 REVISED STANDARD PLAN RSP ES-1B




TO ACCOMPANY PLANS DATED 12-28-15

EQUIPMENT IDENTIFICATION


ILLUMINATED SIGN IDENTIFICATION NUMBER:

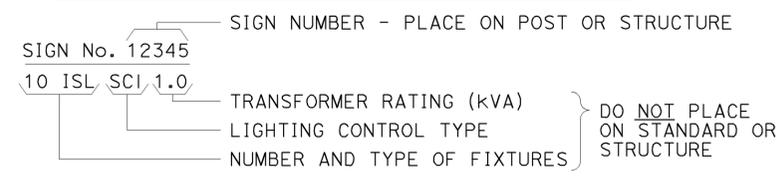


ELECTROLIER OR EQUIPMENT IDENTIFICATION NUMBER:

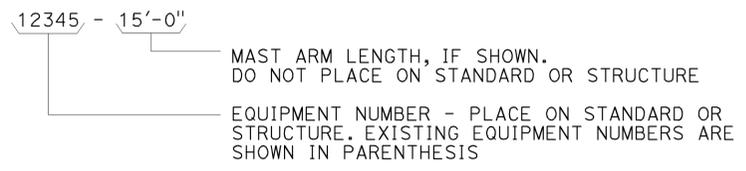


CONDUIT AND CONDUCTOR IDENTIFICATION:

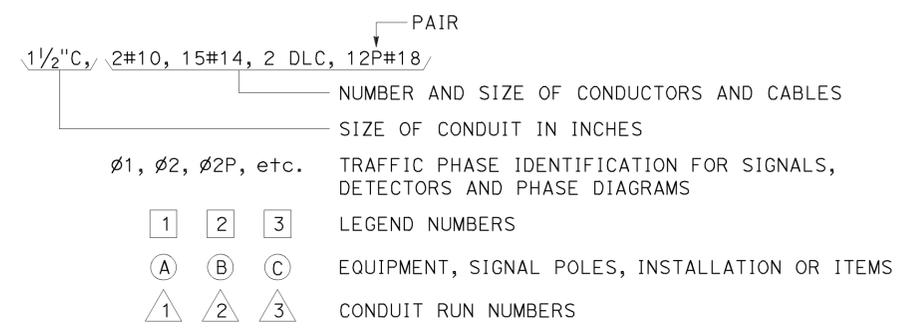


SIGNAL AND LIGHTING STANDARD (TYPICAL DESIGNATION):

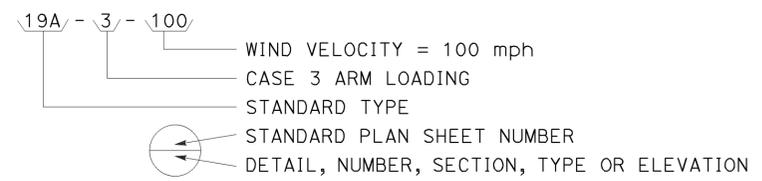


MISCELLANEOUS EQUIPMENT

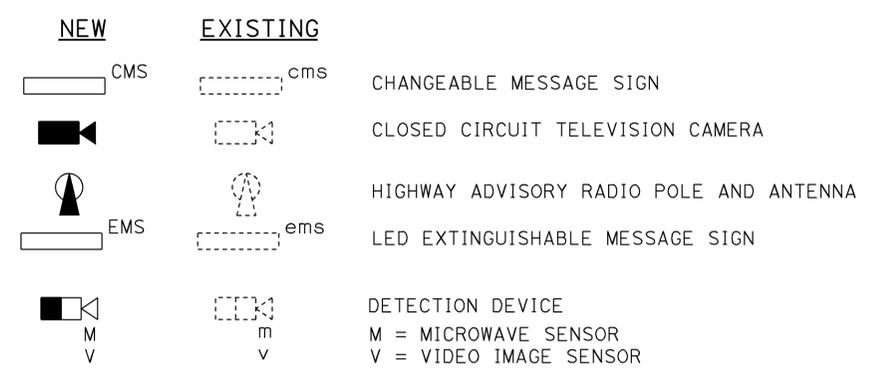



WIRING DIAGRAM LEGEND

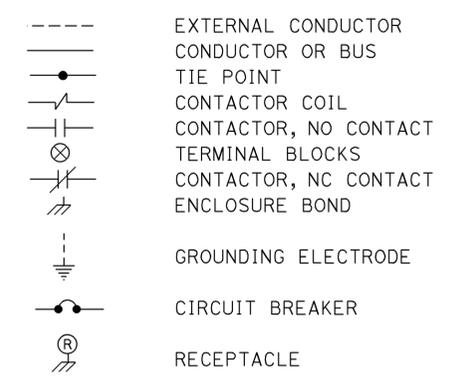

PULL BOXES

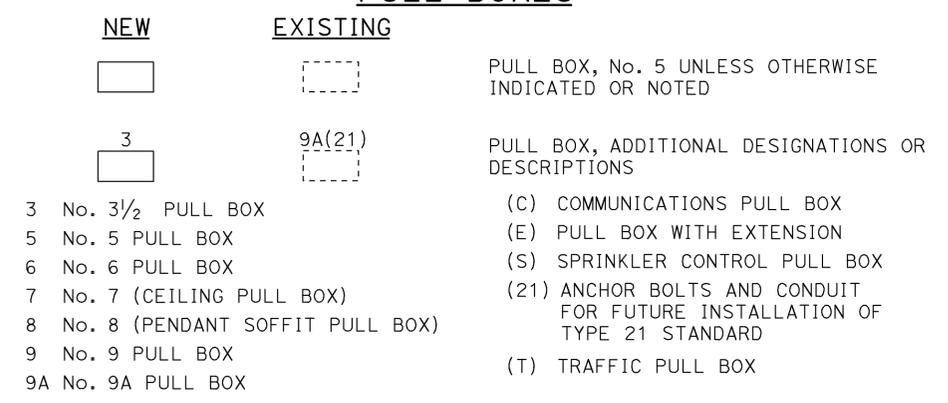

VEHICLE DETECTORS

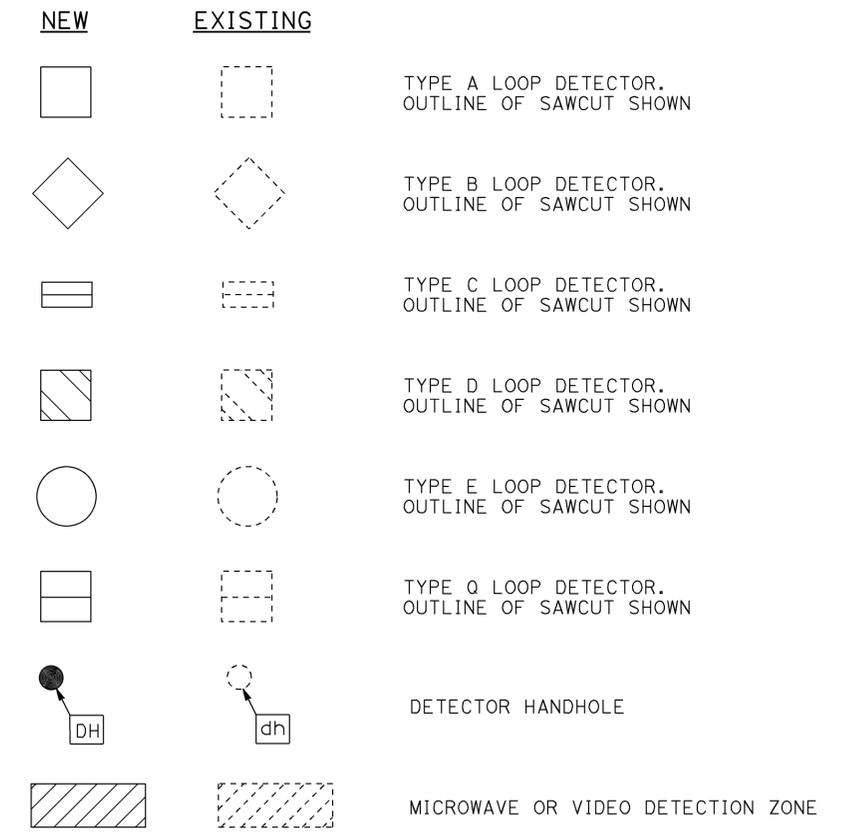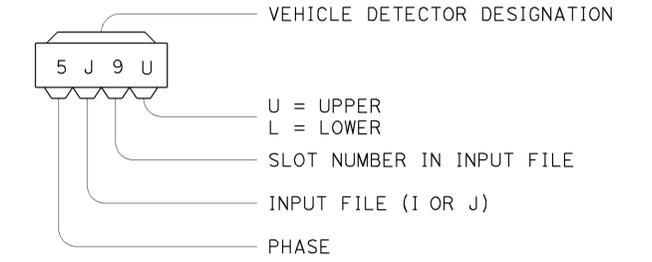

STATE OF CALIFORNIA
DEPARTMENT OF TRANSPORTATION

ELECTRICAL SYSTEMS (LEGEND AND ABBREVIATIONS)

NO SCALE

RSP ES-1C DATED OCTOBER 30, 2015 SUPERSEDES RSP ES-1C DATED JULY 19, 2013 AND STANDARD PLAN ES-1C DATED MAY 20, 2011 - PAGE 427 OF THE STANDARD PLANS BOOK DATED 2010.

2010 REVISED STANDARD PLAN RSP ES-1C