



INDEX OF PLANS

SHEET No.	DESCRIPTION
1	TITLE AND LOCATION MAP
2	TYPICAL CROSS SECTION
3-7	CONSTRUCTION DETAILS
8	CONSTRUCTION AREA SIGNS
9	PAVEMENT DELINEATION AND SIGN QUANTITIES
10-11	SUMMARY OF QUANTITIES
12-13	ELECTRICAL PLANS
14-32	REVISED STANDARD PLAN

THE STANDARD PLANS LIST APPLICABLE TO THIS CONTRACT IS INCLUDED IN THE NOTICE TO BIDDERS AND SPECIAL PROVISIONS BOOK.

STATE OF CALIFORNIA **ACNHP-P120(057)E**
DEPARTMENT OF TRANSPORTATION
PROJECT PLANS FOR CONSTRUCTION ON
STATE HIGHWAY
IN STANISLAUS COUNTY NEAR OAKDALE
FROM STANISLAUS COUNTY LINE
TO 0.2 MILE WEST OF STANISLAUS RIVER BRIDGE

TO BE SUPPLEMENTED BY STANDARD PLANS DATED 2010

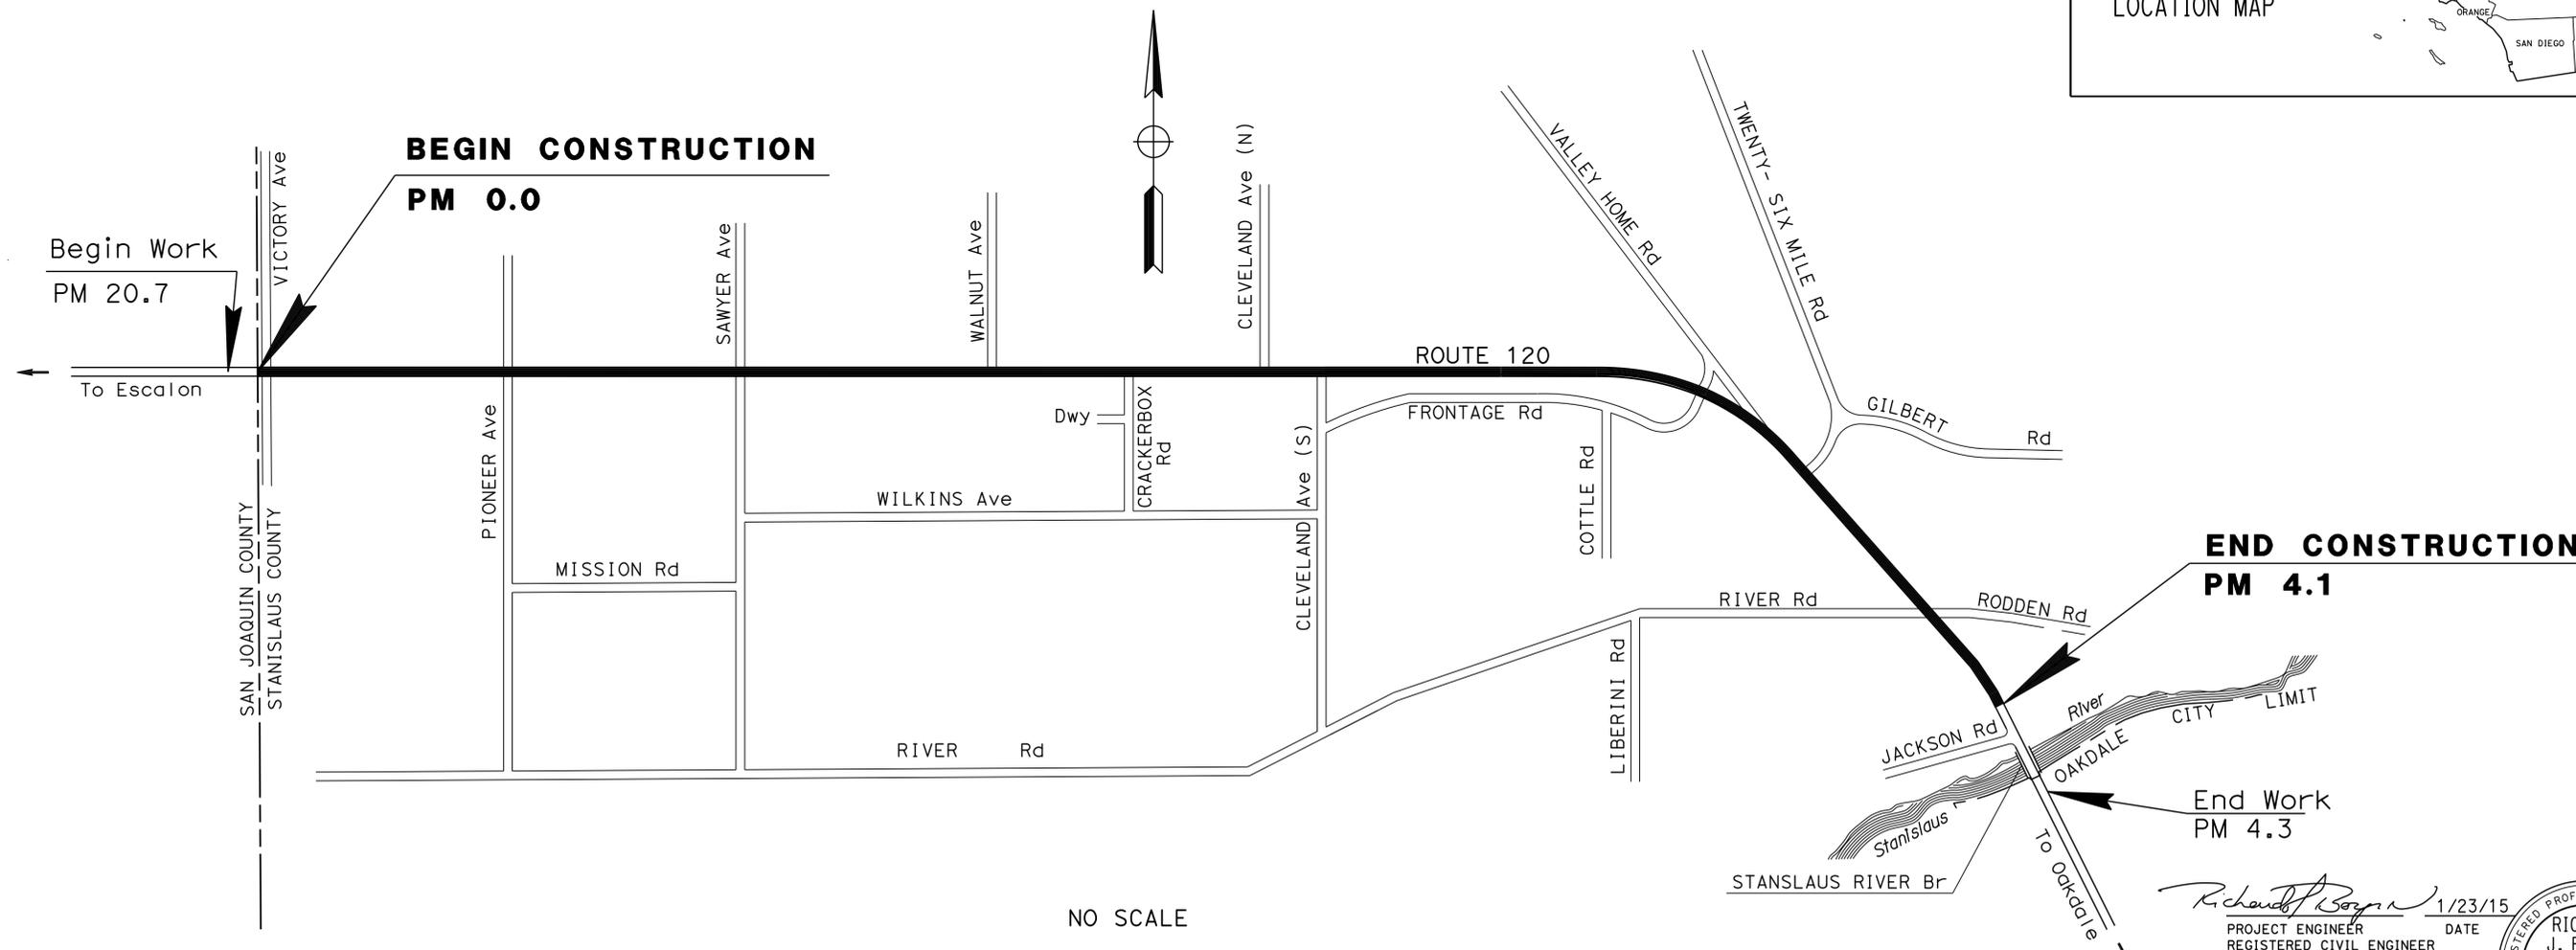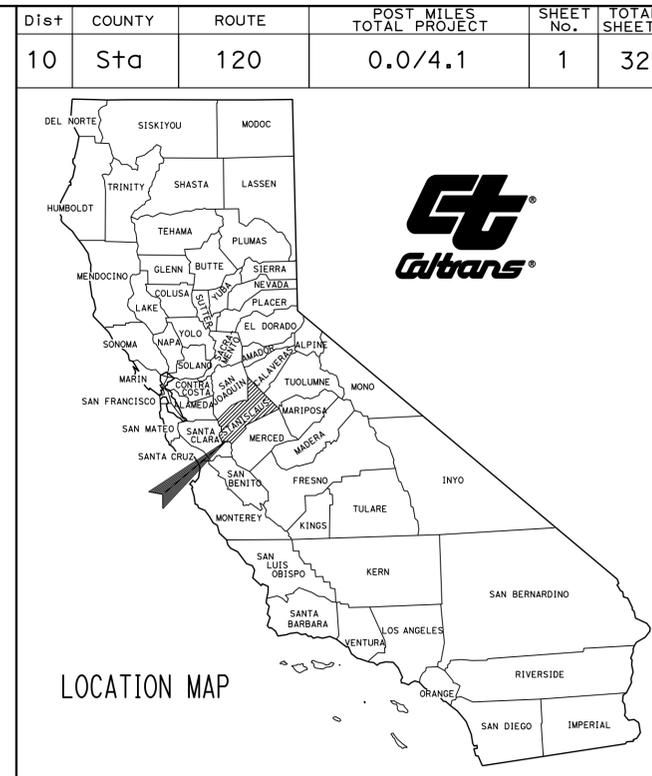

PROJECT MANAGER ARVINDER BAJWA	DESIGN ENGINEER NOMER GUTIERREZ
-----------------------------------	------------------------------------

THE CONTRACTOR SHALL POSSESS THE CLASS (OR CLASSES) OF LICENSE AS SPECIFIED IN THE "NOTICE TO BIDDERS."

PROJECT ENGINEER DATE 1/23/15
 REGISTERED CIVIL ENGINEER
 No. 75844
 Exp. 06-30-16
 CIVIL
 STATE OF CALIFORNIA

January 26, 2015
 PLANS APPROVAL DATE
THE STATE OF CALIFORNIA OR ITS OFFICERS OR AGENTS SHALL NOT BE RESPONSIBLE FOR THE ACCURACY OR COMPLETENESS OF SCANNED COPIES OF THIS PLAN SHEET.

CONTRACT No.	10-OK1404
PROJECT ID	1013000051

DATE PLOTTED => 24-FEB-2015 TIME PLOTTED => 12:38

STATE OF CALIFORNIA - DEPARTMENT OF TRANSPORTATION
Caltrans
 DESIGN

NOTES:

1. DIMENSIONS OF THE PAVEMENT STRUCTURES (STRUCTURAL SECTIONS) ARE SUBJECT TO TOLERANCES SPECIFIED IN THE STANDARD SPECIFICATIONS.
2. FOR ACCURATE RIGHT OF WAY DATA, CONTACT RIGHT OF WAY ENGINEERING AT THE DISTRICT OFFICE.
3. FOR REPAIR FAILED AREA DIMENSIONS AND LOCATIONS, SEE REPAIR FAILED AREA TABLE ON SUMMARY OF QUANTITIES SHEET.
4. FOR LOCATIONS AND TYPES OF DIKE, SEE SUMMARY OF QUANTITIES SHEET.

ABBREVIATIONS:

RHMA-G - RUBBERIZED HOT MIX ASPHALT (GAP GRADED)
 SAMI-R - STRESS ABSORBING MEMBRANE INTERLAYER - RUBBERIZED
 (ASPHALT-RUBBERIZED BINDER WITH PRECOATED SCREENINGS)

DESIGN DESIGNATION

HMA OVERLAY, AND ADA UPGRADE
 ADT 2014 (Exst) 14,600 DHV=1,990
 ADT 2015 14,800
 ADT 2035 19,900

PAVEMENT CLIMATE REGION


INLAND VALLEY

Dist	COUNTY	ROUTE	POST MILES TOTAL PROJECT	SHEET No.	TOTAL SHEETS
10	Sta	120	0.0/4.1	2	32


Richard J. Boyer 1/23/15
 REGISTERED CIVIL ENGINEER DATE
 1-26-15
 PLANS APPROVAL DATE

REGISTERED PROFESSIONAL ENGINEER
 RICHARD J. BOYER
 No. 75844
 Exp. 06-30-16
 CIVIL
 STATE OF CALIFORNIA


THE STATE OF CALIFORNIA OR ITS OFFICERS OR AGENTS SHALL NOT BE RESPONSIBLE FOR THE ACCURACY OR COMPLETENESS OF SCANNED COPIES OF THIS PLAN SHEET.

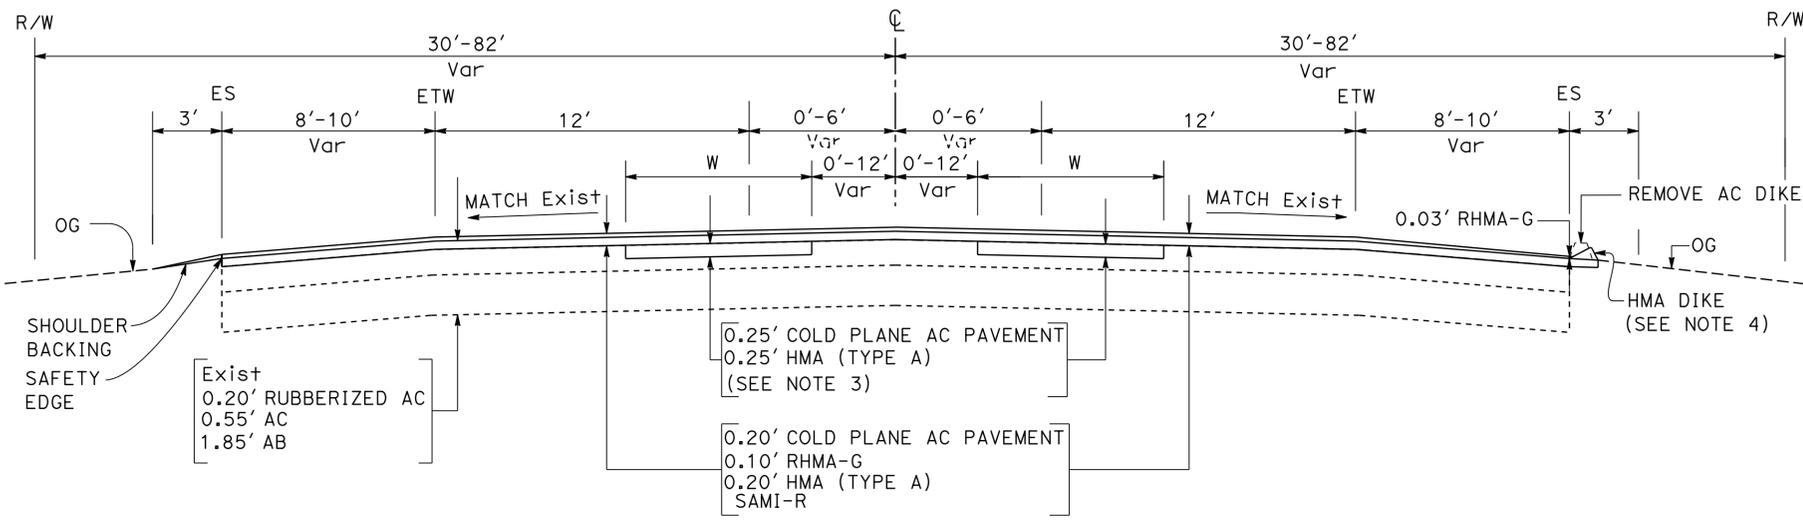

PM 0.42 TO PM 0.62
 PM 3.06 TO PM 4.01

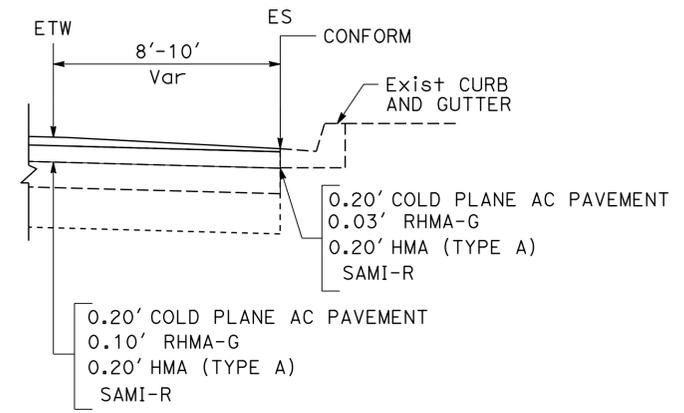

PM 3.24 Lt, PM 3.31 Lt
 AND PM 3.80 Lt
CURB & GUTTER LOCATIONS

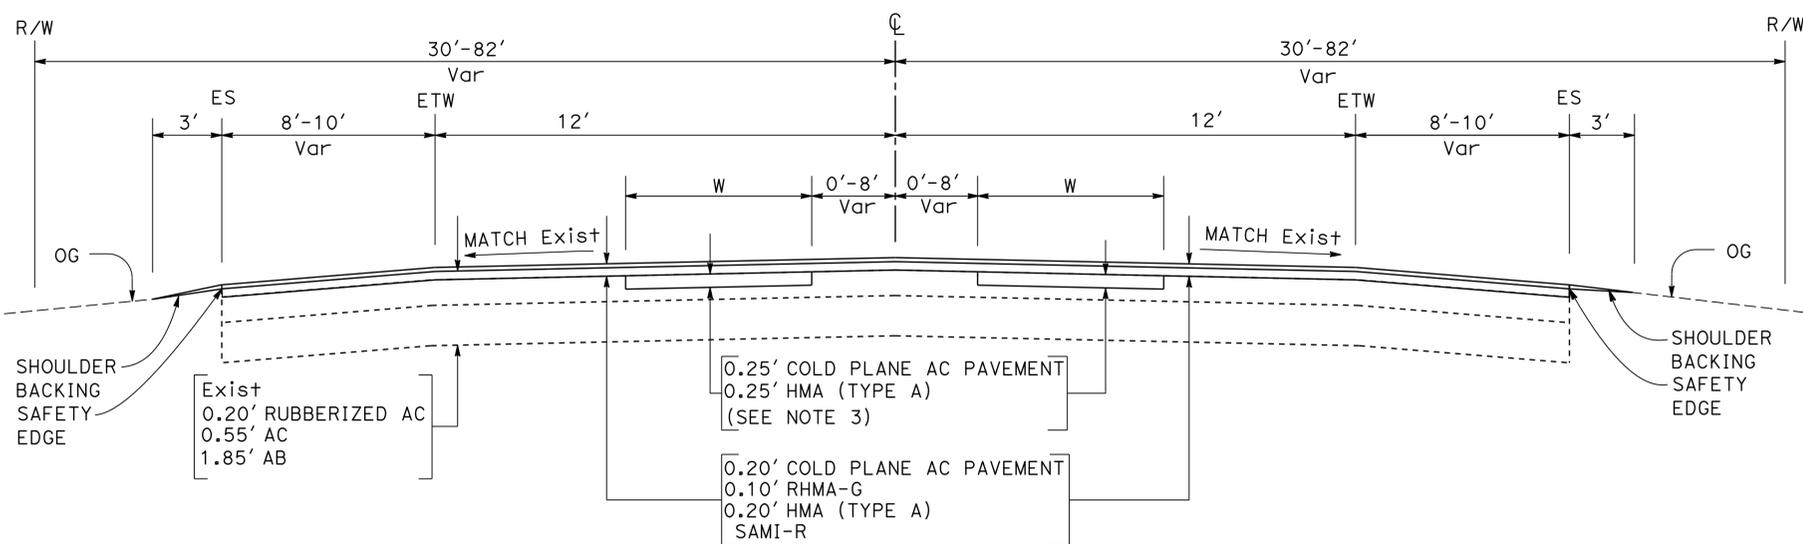

PM 0.00 TO PM 0.42
 PM 0.62 TO PM 3.06
 PM 4.01 TO PM 4.10

ROUTE 120

TYPICAL CROSS SECTIONS

NO SCALE

X-1

Dist	COUNTY	ROUTE	POST MILES TOTAL PROJECT	SHEET No.	TOTAL SHEETS
10	Sta	120	0.0/4.1	3	32

<i>Richard J. Boyer</i>	1/23/15
REGISTERED CIVIL ENGINEER	DATE
1-26-15	
PLANS APPROVAL DATE	

REGISTERED PROFESSIONAL ENGINEER	Richard J. Boyer
No.	75844
Exp	6/30/16
CIVIL	

THE STATE OF CALIFORNIA OR ITS OFFICERS OR AGENTS SHALL NOT BE RESPONSIBLE FOR THE ACCURACY OR COMPLETENESS OF SCANNED COPIES OF THIS PLAN SHEET.


LEGEND:

-  - HMA (TYPE A)
-  - COLD PLANE AC PAVEMENT HMA (TYPE A)
-  - COLD PLANE AC PAVEMENT RHMA-G
-  - DETECTABLE WARNING SURFACE

ABBREVIATIONS:

- RHMA-G - RUBBERIZED HOT MIX ASPHALT (GAP GRADED)
- CR - CURB RAMP

STATE OF CALIFORNIA - DEPARTMENT OF TRANSPORTATION	DESIGN
FUNCTIONAL SUPERVISOR	NOMER GUTIERREZ
CALCULATED/DESIGNED BY	CHECKED BY
GABE ELEFANTE	RICHARD BOYER
REVISOR	DATE
GE	12-16-14
GE	12-29-14
GE	1-29-15

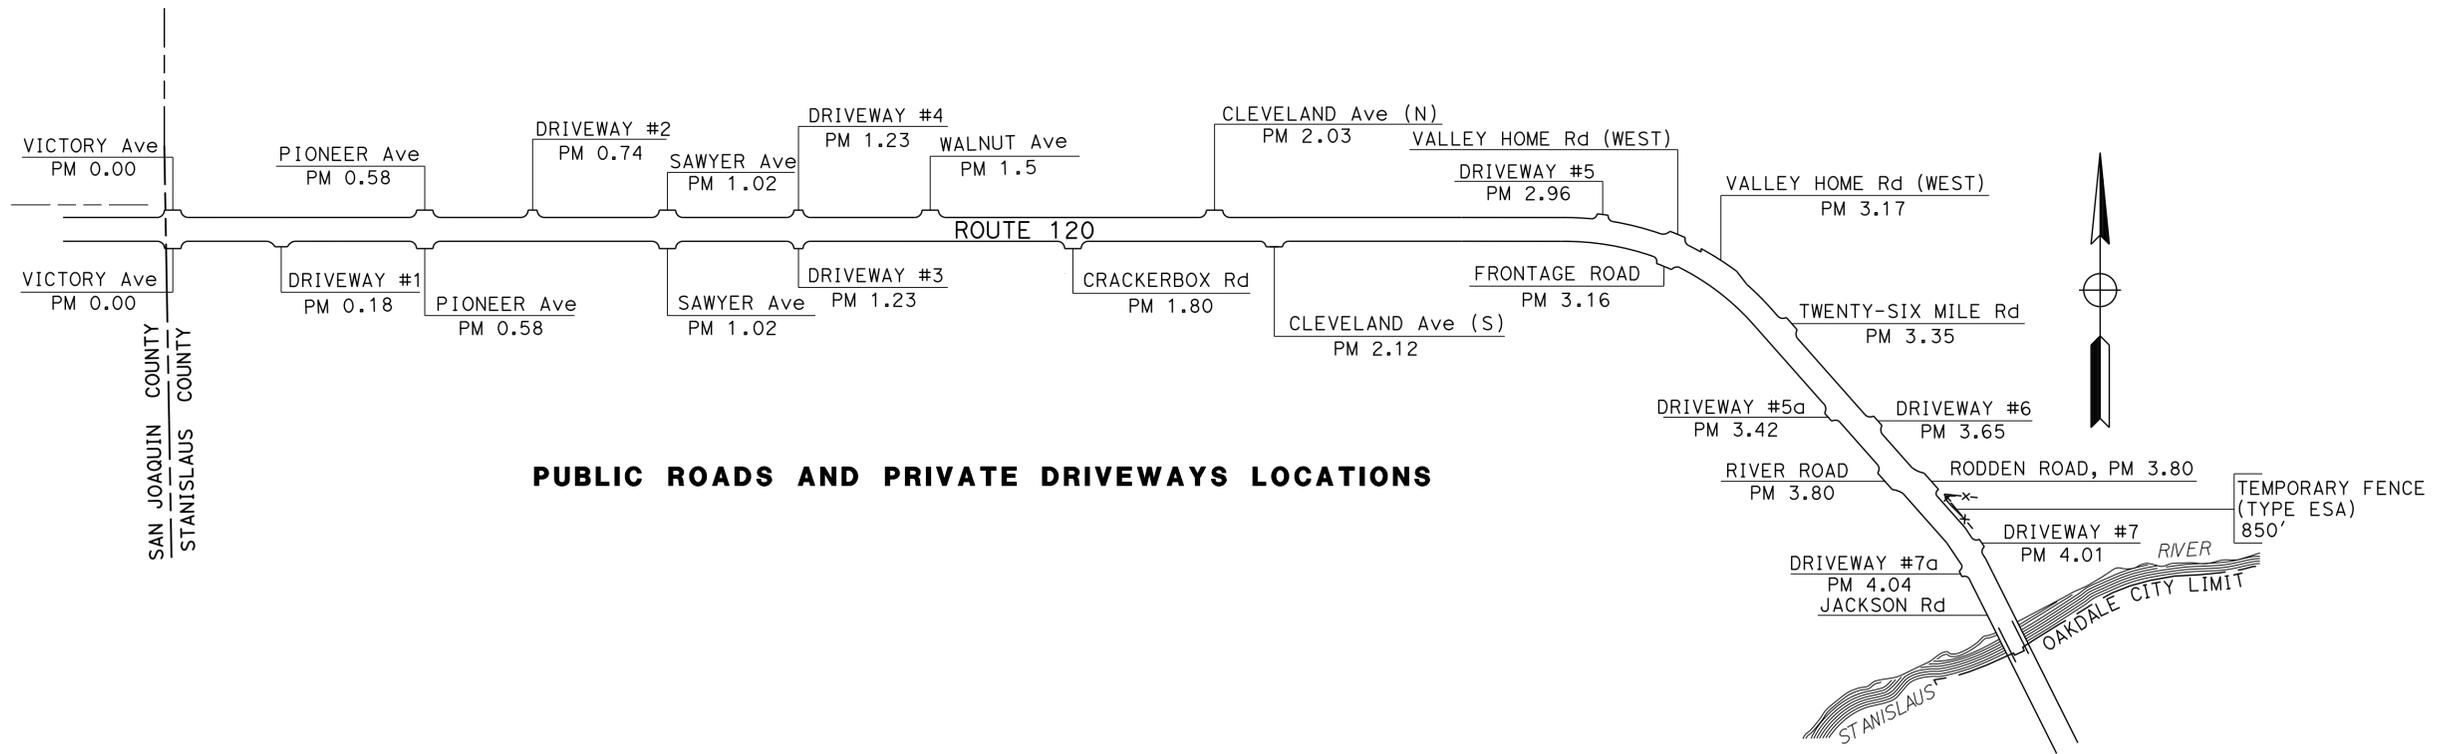

CONSTRUCTION DETAILS

NO SCALE

C-1




Dist	COUNTY	ROUTE	POST MILES TOTAL PROJECT	SHEET No.	TOTAL SHEETS
10	Sta	120	0.0/4.1	4	32

REGISTERED CIVIL ENGINEER DATE 1/23/15
 RICHARD J. BOYER
 No. 75844
 Exp. 06-30-16
 CIVIL
 STATE OF CALIFORNIA

1-26-15
 PLANS APPROVAL DATE

THE STATE OF CALIFORNIA OR ITS OFFICERS OR AGENTS SHALL NOT BE RESPONSIBLE FOR THE ACCURACY OR COMPLETENESS OF SCANNED COPIES OF THIS PLAN SHEET.

NOTE (THIS SHEET ONLY):
 LINE "AA" IS FOR CONSTRUCTION PURPOSES ONLY.

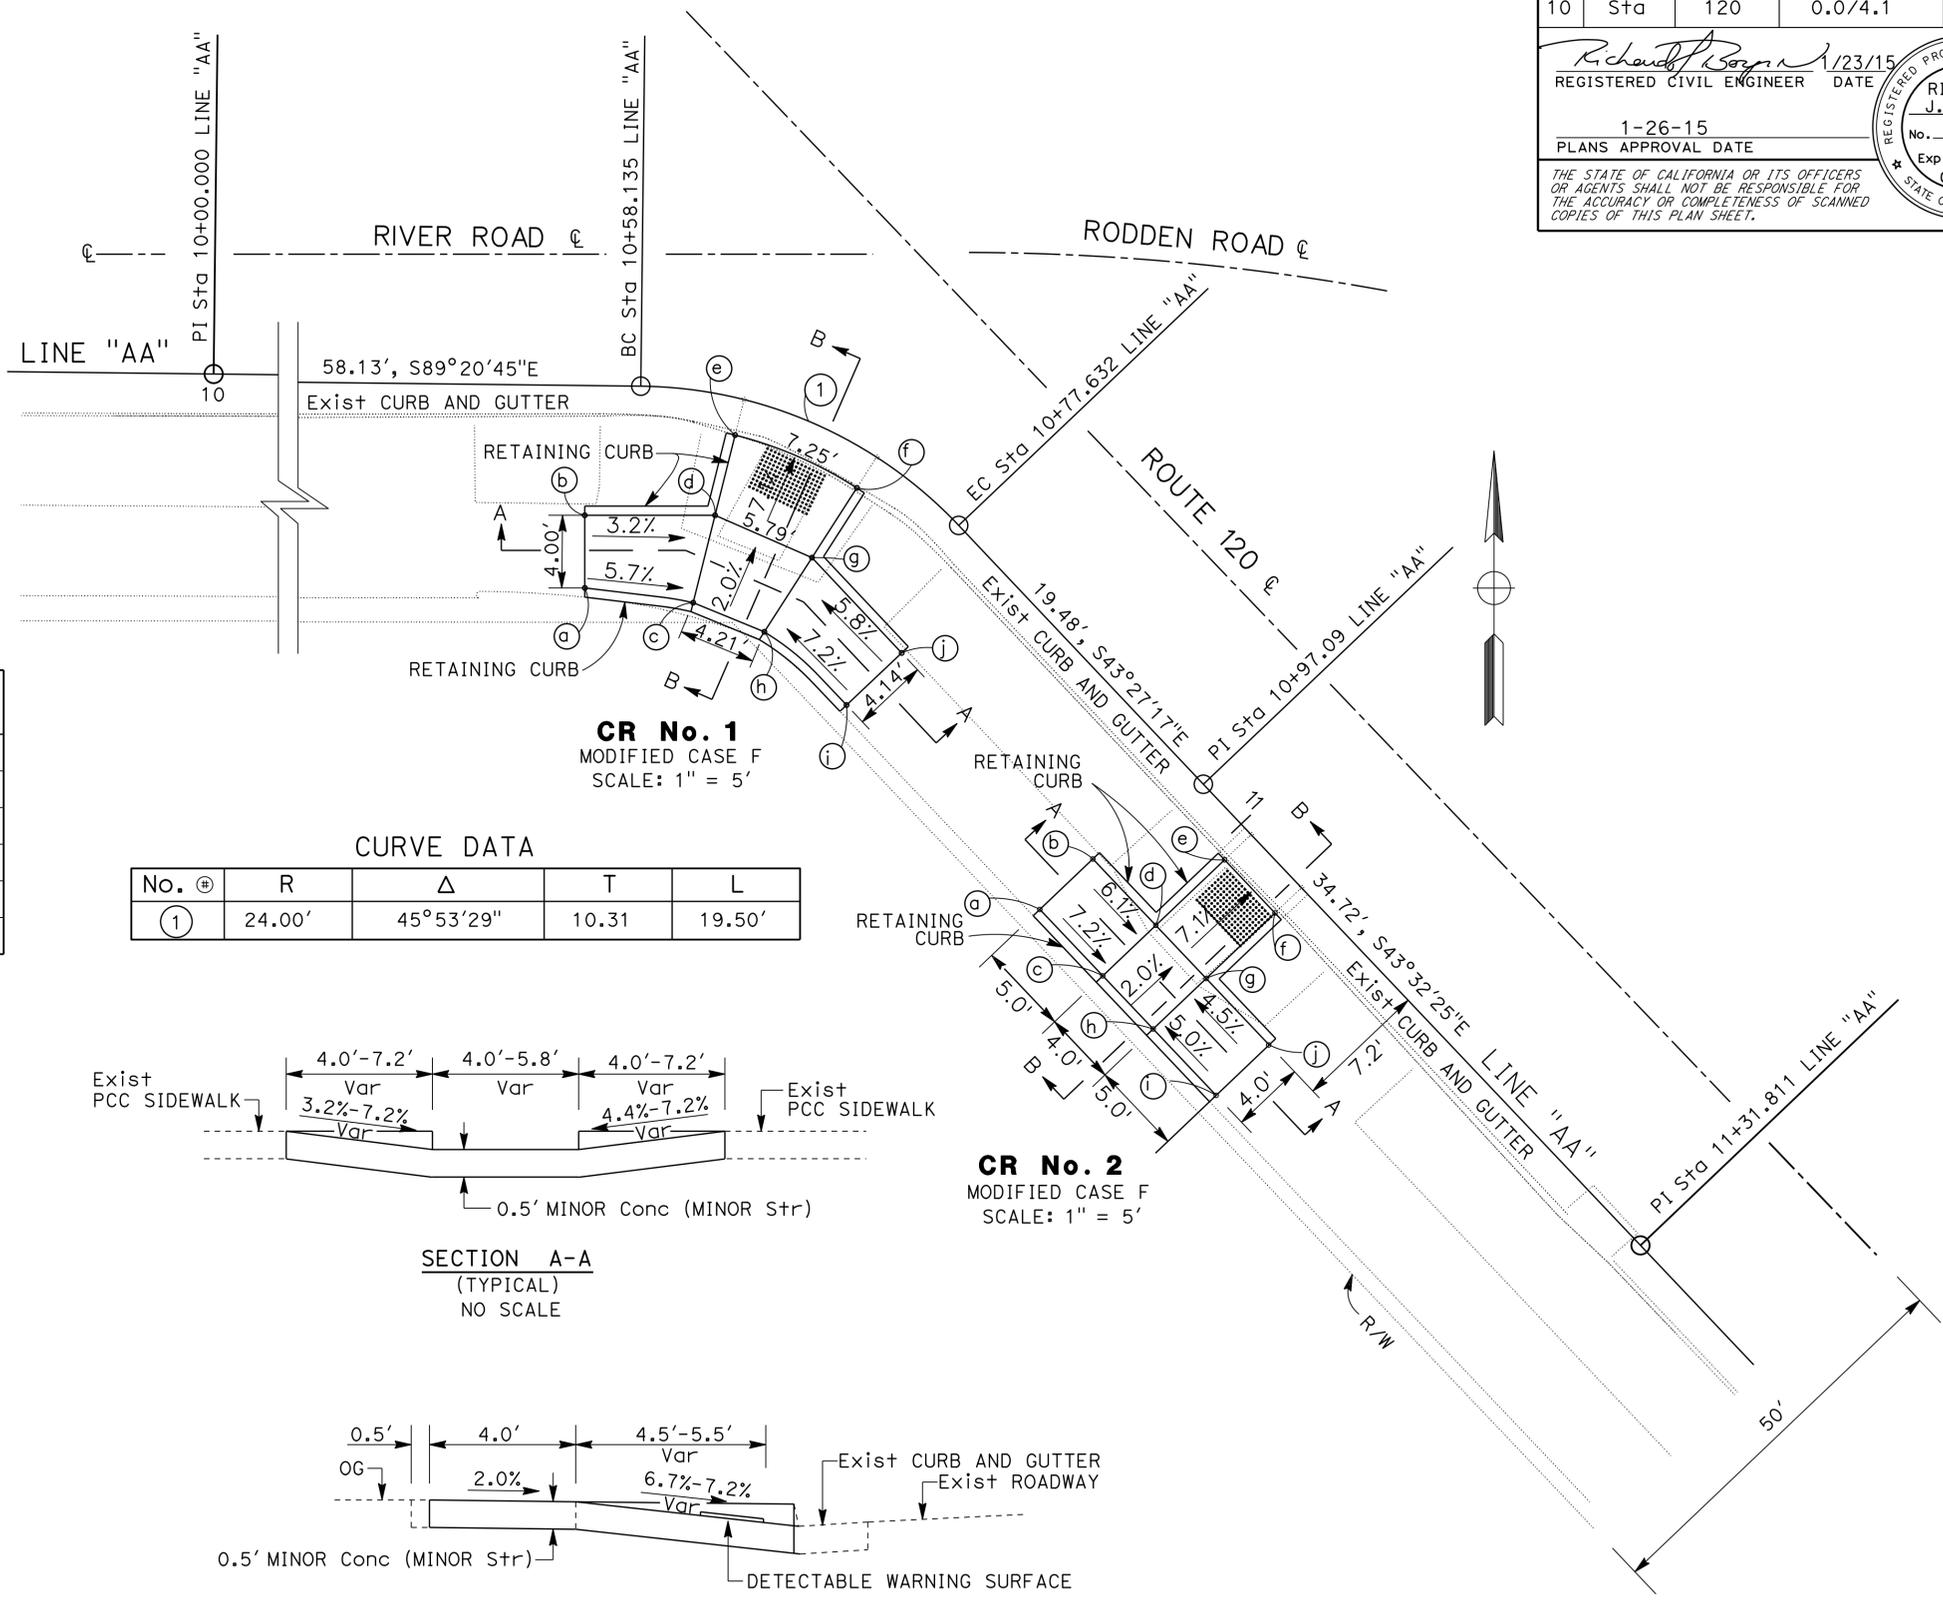

CONSTRUCTION AND DESIGN CONTROL


LOCTION	HORIZONTAL: NAD83- 92 (Epoch 1991.35) VERTICAL: NGVD29		
LINE "AA"	NORTHING	EASTING	DESCRIPTION
10+00.000	2,108,026.808	6,458,092.914	PI
10+58.135	2,108,026.144	6,458,151.044	BC
10+77.632	2,108,018.546	6,458,168.437	EC
10+97.090	2,108,044.422	6,458,181.819	PI
11+31.811	2,107,979.252	6,458,205.738	PI

CURVE DATA


No. @	R	Δ	T	L
①	24.00'	45°53'29"	10.31	19.50'

CURB RAMP

CR No.	STATION	Point No.	OFFSET	Elev		
1	10+55.20, "AA" LINE	a	11.00' Rt	172.719'		
		b	7.04' Rt	172.506'		
		c	11.43' Rt	172.375'		
		d	6.51' Rt	172.278'		
		e	2.00' Rt	171.953'		
		f	2.00' Rt	172.062'		
1	10+63.84, "AA" LINE	g	6.52' Rt	172.387'		
		h	11.35' Rt	172.482'		
		i	11.20' Rt	172.915'		
		j	7.53' Rt	172.805'		
		2	10+95.88, "AA" LINE	a	11.19' Rt	172.843'
				b	7.19' Rt	172.711'
c	11.19' Rt			172.485'		
d	7.19' Rt			172.405'		
e	2.00' Rt			172.034'		
f	2.00' Rt			172.024'		
2	11+04.88, "AA" LINE	g	7.19' Rt	172.395'		
		h	11.19' Rt	172.475'		
		i	11.19' Rt	172.727'		
		j	7.19' Rt	172.620'		

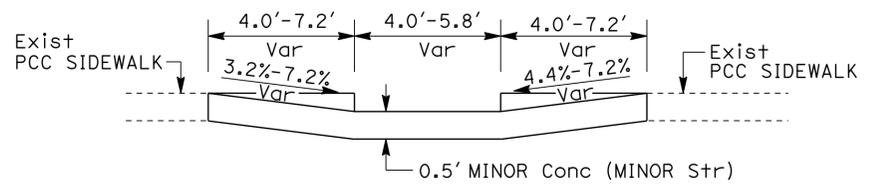

SECTION A-A
 (TYPICAL)
 NO SCALE

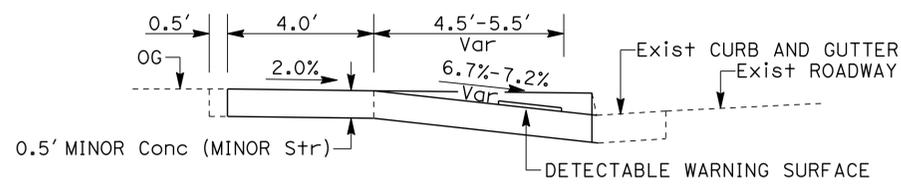

SECTION B-B
 (TYPICAL)
 NO SCALE


CONSTRUCTION DETAILS
 SCALE AS SHOWN
 C-2

STATE OF CALIFORNIA - DEPARTMENT OF TRANSPORTATION DESIGN
 GABE ELEFANTE RICHARD BOYER
 NOMER GUTIERREZ
 1-29-15 16:57


DIST	COUNTY	ROUTE	POST MILES TOTAL PROJECT	SHEET No.	TOTAL SHEETS
10	Sta	120	0.0/4.1	5	32

Richard J. Boyer 1/23/15
 REGISTERED CIVIL ENGINEER DATE
 1-26-15
 PLANS APPROVAL DATE
 THE STATE OF CALIFORNIA OR ITS OFFICERS OR AGENTS SHALL NOT BE RESPONSIBLE FOR THE ACCURACY OR COMPLETENESS OF SCANNED COPIES OF THIS PLAN SHEET.


REGISTERED PROFESSIONAL ENGINEER
 RICHARD J. BOYER
 No. 75844
 Exp. 06-30-16
 CIVIL
 STATE OF CALIFORNIA

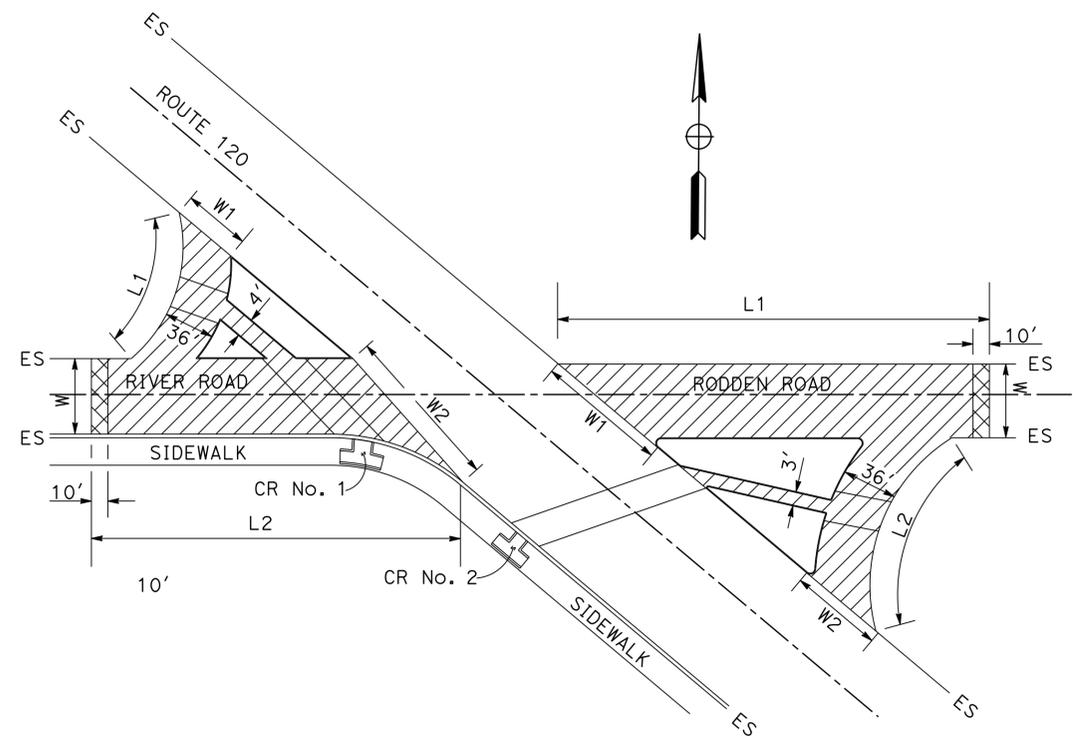


TYPICAL PAVING LIMIT FOR RIVER ROAD/RODDEN ROAD

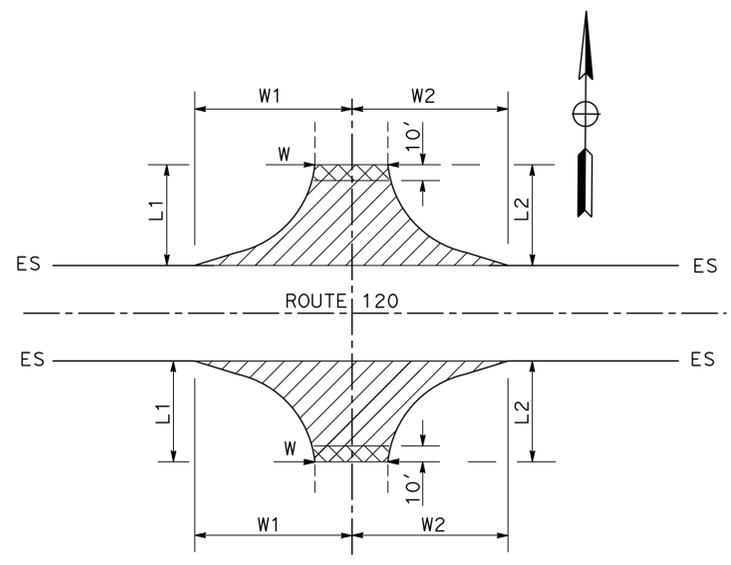


TYPICAL PAVING LIMITS FOR VICTORY AVENUE SAWYER AVENUE

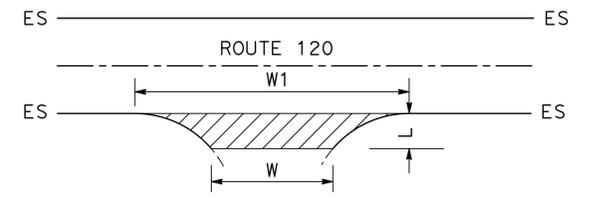


TYPICAL PAVING LIMITS FOR PRIVATE DRIVEWAYS NUMBER 1, 2, 3, 4, 5, 5a, 6, AND 7a

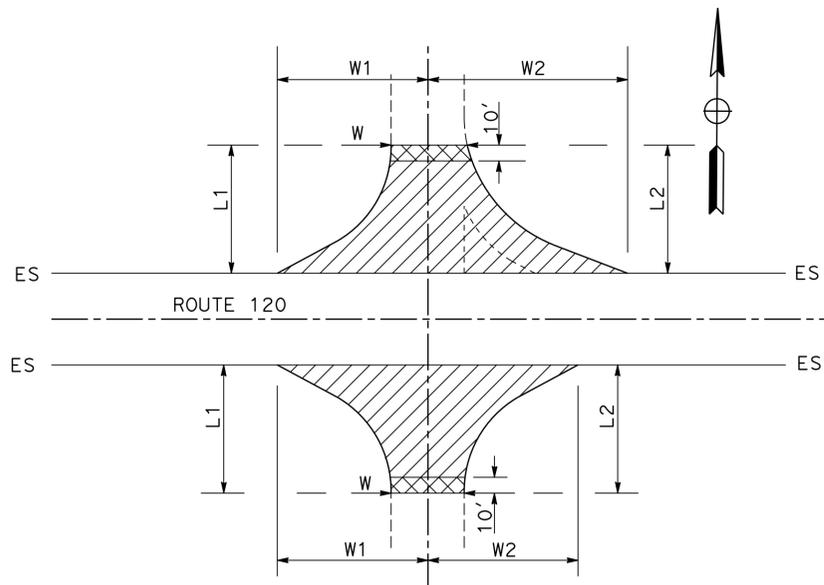

PAVING LIMIT FOR PIONEER AVENUE

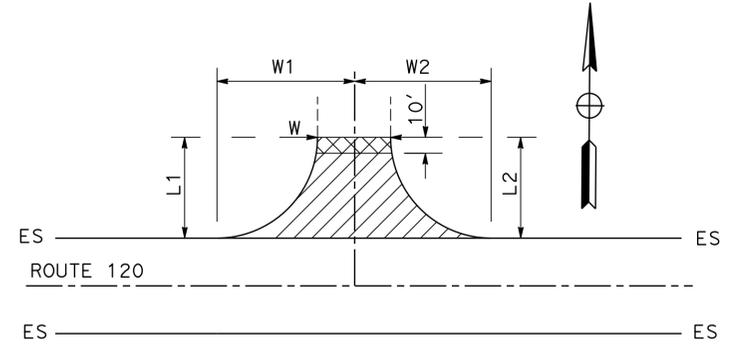

TYPICAL PAVING LIMITS FOR 26 MILE ROAD DRIVEWAY No. 7

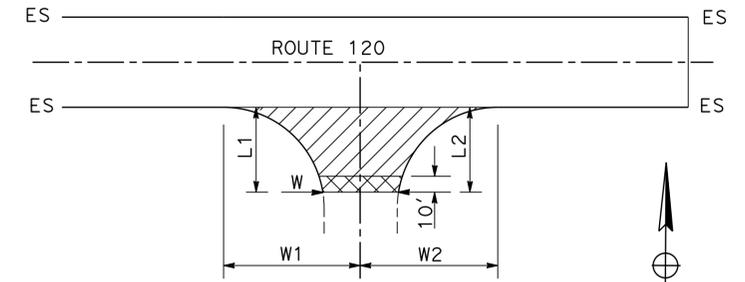

TYPICAL PAVING LIMITS FOR WALNUT AVENUE CRACKERBOX ROAD CLEVELAND AVENUE (NORTH) CLEVELAND AVENUE (SOUTH)

CONSTRUCTION DETAILS
NO SCALE
C-3

STATE OF CALIFORNIA - DEPARTMENT OF TRANSPORTATION	DESIGN	FUNCTIONAL SUPERVISOR	REVISOR	DATE
		NOMER GUTIERREZ	GABE ELEFANTE	12-29-14
		CHECKED BY	REVISOR	DATE
		RICHARD BOYER	GABE ELEFANTE	12-16-14
		DESIGNED BY	REVISOR	DATE
			GABE ELEFANTE	12-29-14

LAST REVISION DATE PLOTTED => 09-FEB-2015 12-29-14 TIME PLOTTED => 16:57





PUBLIC ROADS

ROAD NAME	PM	SIDE	LENGTH		WIDTH		
			L1	L2	W	W1	W2
VICTORY AVENUE	0.00	R+	30'	48'	54'	30'	50'
VICTORY AVENUE	0.00	L+	60'	60'	18'	30'	80'
PIONEER AVENUE	0.58	R+	40'	40'	38'	72'	60'
PIONEER AVENUE	0.58	L+	48'	48'	42'	72'	72'
SAWYER AVENUE	1.02	R+	42'	42'	48'	72'	48'
SAWYER AVENUE	1.02	L+	42'	42'	36'	72'	72'
WALNUT AVENUE	1.50	L+	60'	52'	60'	86'	84'
CRACKERBOX ROAD	1.80	R+	36'	36'	36'	60'	60'
CLEVELAND AVENUE (NORTH)	2.03	L+	42'	42'	40'	72'	102'
CLEVELAND AVENUE (SOUTH)	2.12	R+	48'	48'	42'	72'	60'
VALLEY HOME ROAD (WEST)	3.16	L+	84'	132'	26'	44'	44'
VALLEY HOME ROAD (EAST)	3.16	L+	36'	84'	23'		
FRONTAGE ROAD	3.16	R+	48'	48'	30'	48'	48'
TWENTY SIX MILE ROAD	3.35	L+	60'	60'	36'	42'	96'
RIVER ROAD	3.80	R+	60'	72'	28'	60'	60'
RODDEN ROAD	3.80	L+	108'	68'	42'	30'	50'
DRIVEWAY No. 7	4.01	L+	72'	72'	32'	48'	48'

PRIVATE DRIVEWAYS

LOCATION DRIVEWAY No	PM	SIDE	W	W1	L
1	0.18	R+	68'	94'	5'
2	0.74	L+	60'	90'	5'
3	1.23	R+	60'	80'	5'
4	1.23	L+	96'	108'	5'
5	2.96	L+	120'	134'	5'
5a	3.42	R+	32'	42'	5'
6	3.65	L+	70'	98'	5'
7a	4.04	R+	18'	24'	5'

PRIVATE DRIVEWAY WIDTHS AND LOCATIONS ARE APPROXIMATE. ACTUAL LOCATIONS AND WIDTHS WILL BE DETERMINED BY THE ENGINEER.

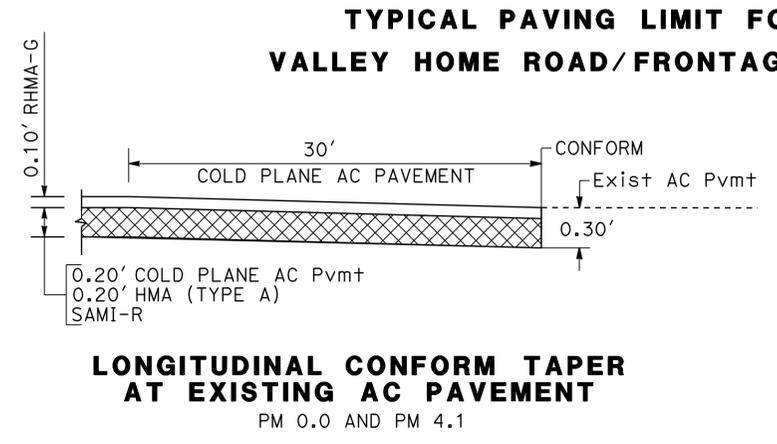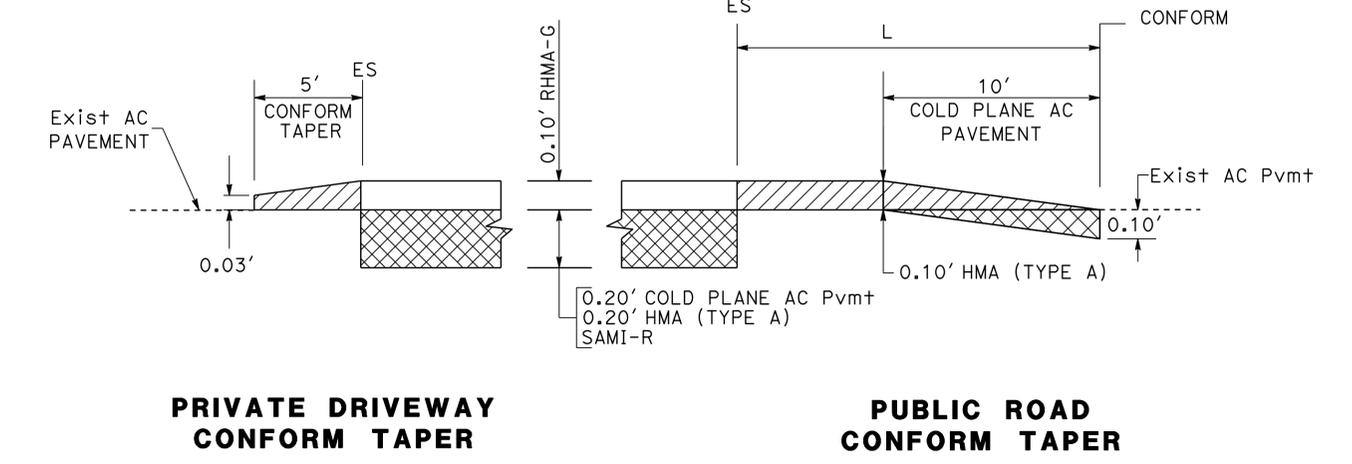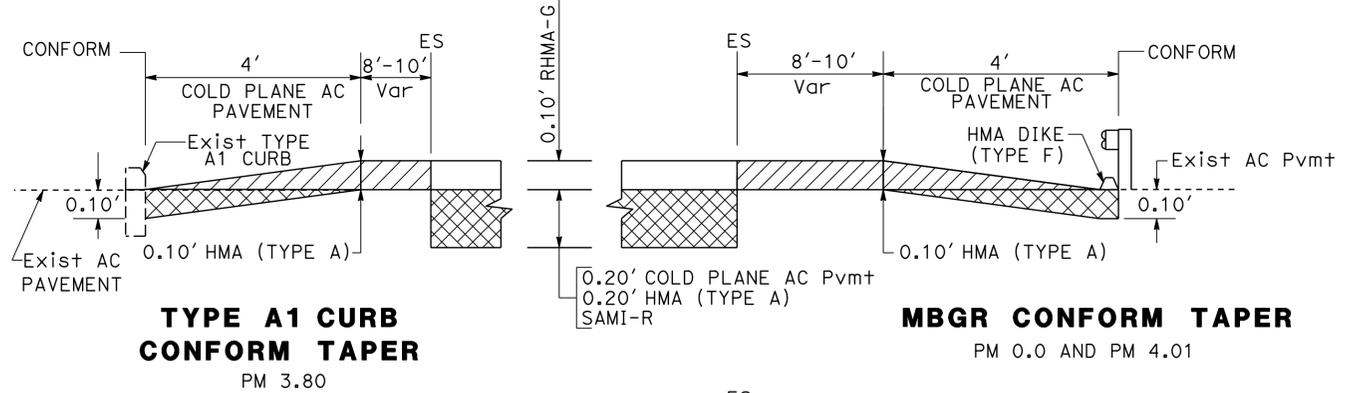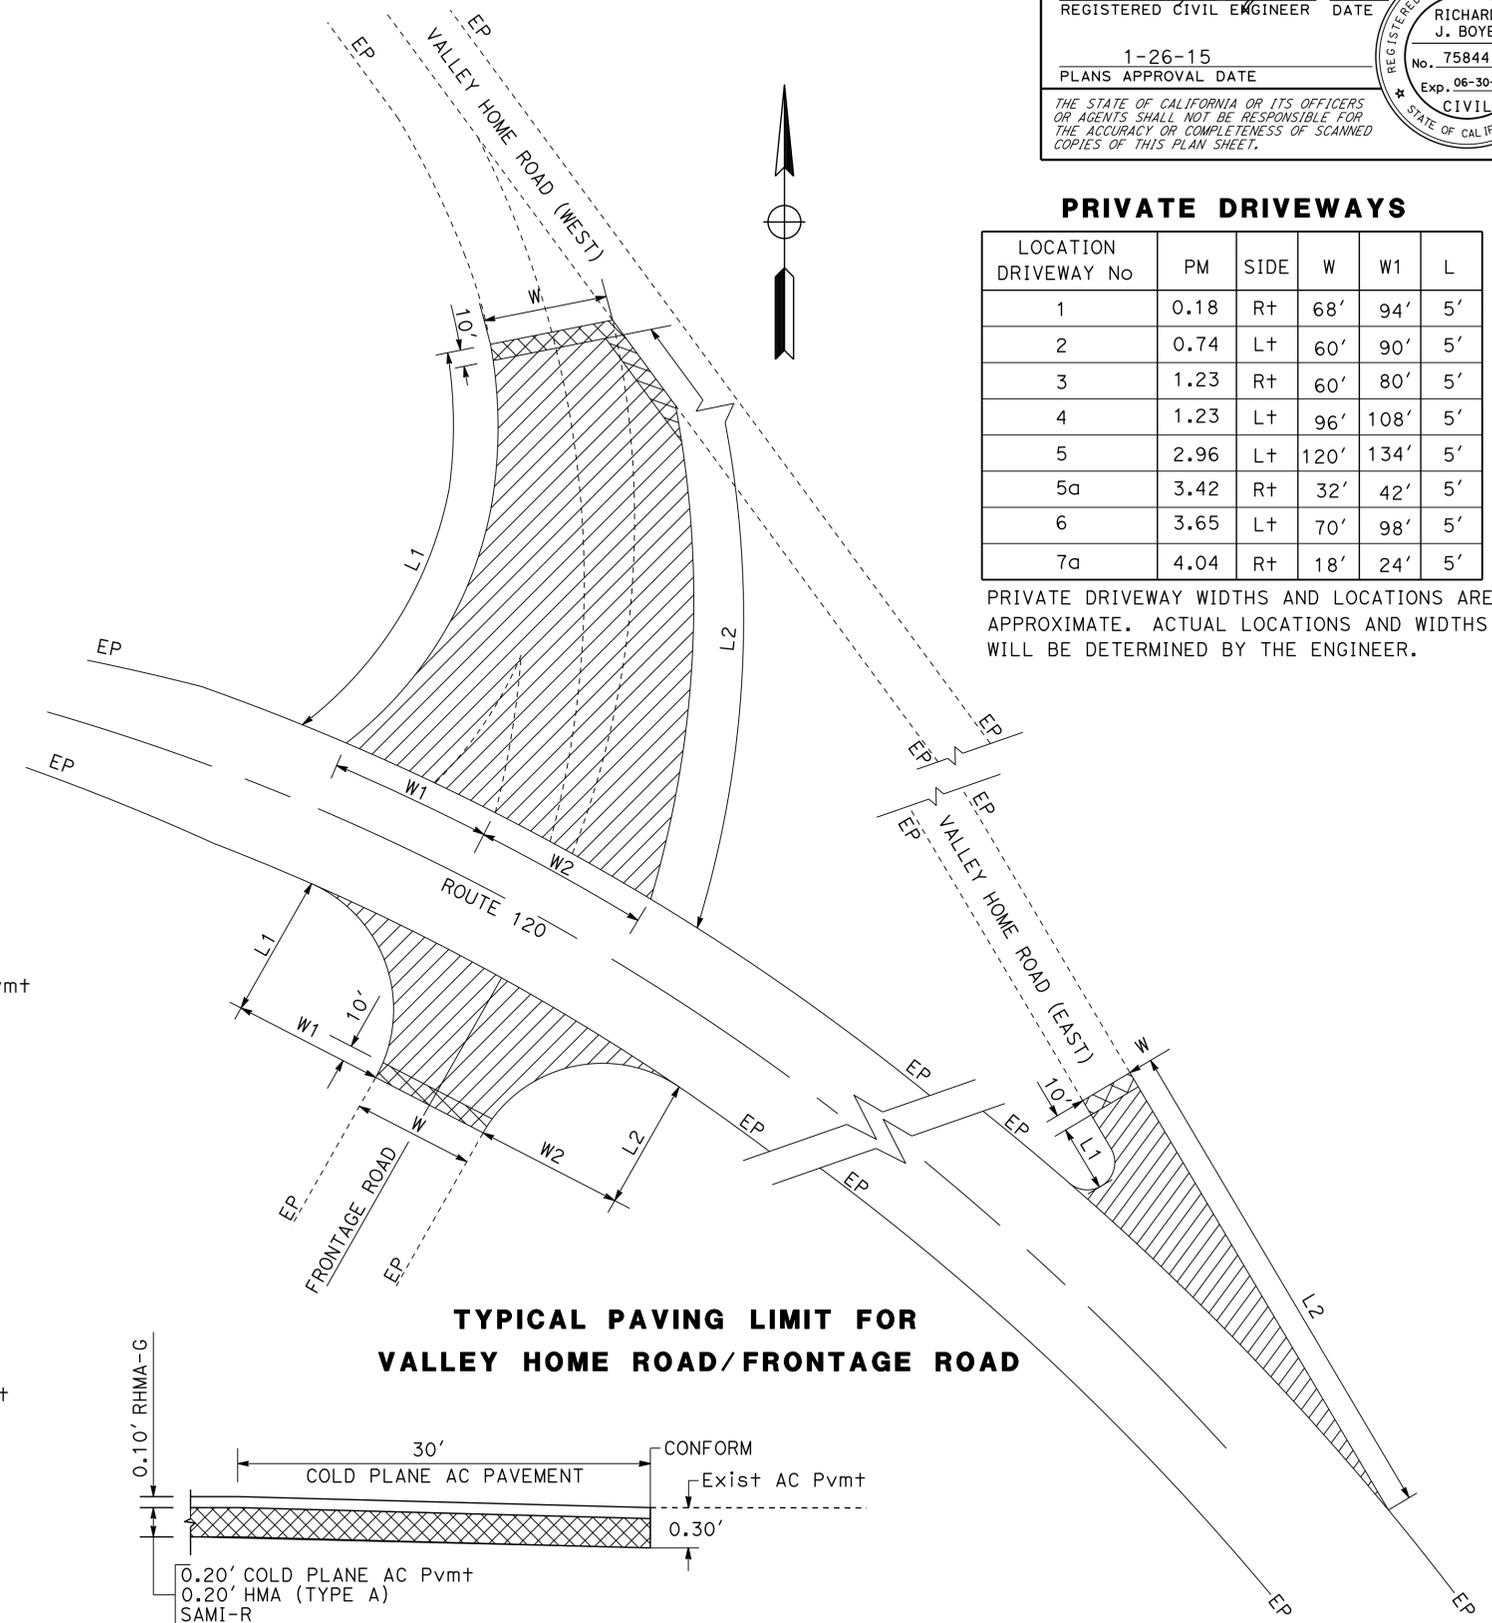

TYPICAL PAVING LIMIT FOR VALLEY HOME ROAD/FRONTAGE ROAD

CONSTRUCTION DETAILS

NO SCALE

C-4

STATE OF CALIFORNIA - DEPARTMENT OF TRANSPORTATION
 GELEFANTE
 RICHARD BOYER
 NOMER GUTIERREZ
 DESIGN

STATE OF CALIFORNIA - DEPARTMENT OF TRANSPORTATION
Caltrans DESIGN

FUNCTIONAL SUPERVISOR: NOMER GUTIERREZ
 CALCULATED/DESIGNED BY: GABE ELEFANTE / RICHARD BOYER
 CHECKED BY: RICHARD BOYER
 REVISIONS:
 GE 1-29-15 1-29-15
 GE 1-07-15 1-07-15
 GE 12-16-14 12-16-14

USERNAME => s121153
 DGN FILE => 1013000051qa0045

BORDER LAST REVISED 7/2/2010
 RELATIVE BORDER SCALE IS IN INCHES
 0 1 2 3

UNIT 1454
 PROJECT NUMBER & PHASE: 10130000511

DATE PLOTTED => 09-FEB-2015
 TIME PLOTTED => 16:57
CONSTRUCTION DETAILS C-5
 NO SCALE

DIST	COUNTY	ROUTE	POST MILES TOTAL PROJECT	SHEET No.	TOTAL SHEETS
10	Sta	120	0.0/4.1	7	32

Richard J. Boyer 1/23/15
 REGISTERED CIVIL ENGINEER DATE


Richard J. Boyer
 No. 75844
 Exp. 6/30/16
 CIVIL
 STATE OF CALIFORNIA

1-26-15
 PLANS APPROVAL DATE


THE STATE OF CALIFORNIA OR ITS OFFICERS OR AGENTS SHALL NOT BE RESPONSIBLE FOR THE ACCURACY OR COMPLETENESS OF SCANNED COPIES OF THIS PLAN SHEET.

LEGEND (THIS SHEET ONLY):


-  TWO-WAY YELLOW REFLECTIVE MARKER (TYPE D)
-  4" YELLOW STRIPING
-  4" WHITE STRIPING
-  RUMBLE STRIPS

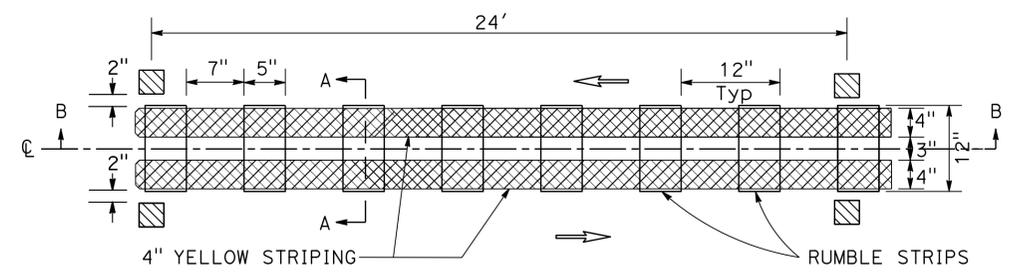


PLAN (TYPICAL)
**CENTERLINE RUMBLE STRIP (HMA, GROUND-IN INDENTATIONS)
 NO PASSING ZONE - DETAIL 22**

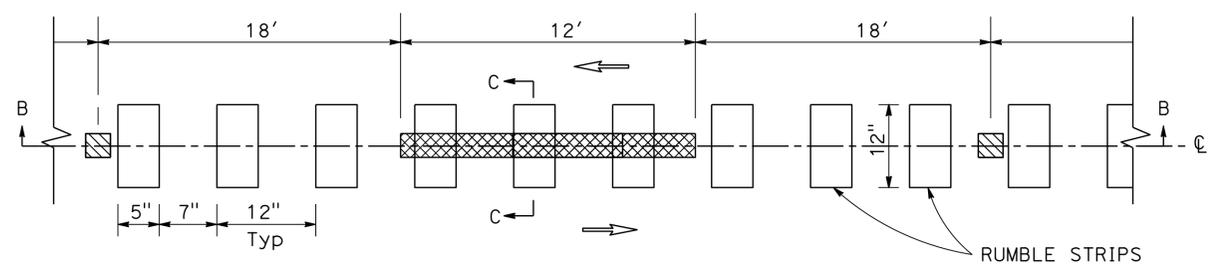


PLAN (TYPICAL)
**CENTERLINE RUMBLE STRIP (HMA, GROUND-IN INDENTATIONS)
 PASSING ZONE - DETAIL 6**

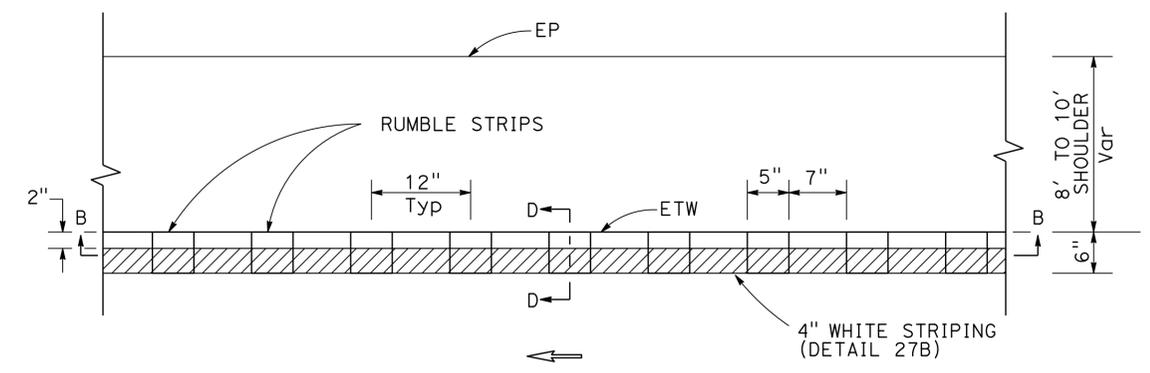


PLAN (TYPICAL)
 ALTERNATE SHOULDER RUMBLE STRIP
 (GROUND-IN INDENTATION)

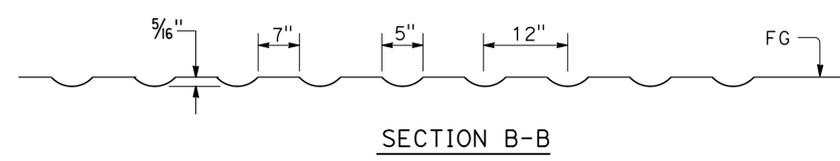


SECTION B-B

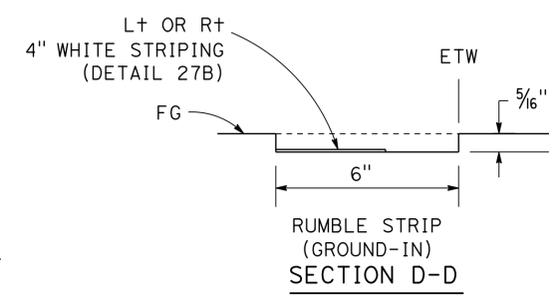


SECTION D-D

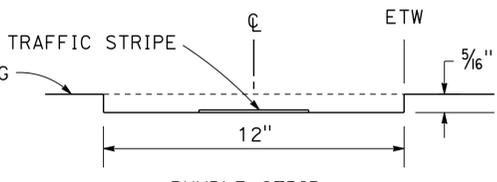


SECTION C-C

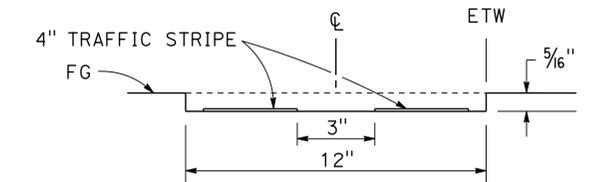

SECTION A-A

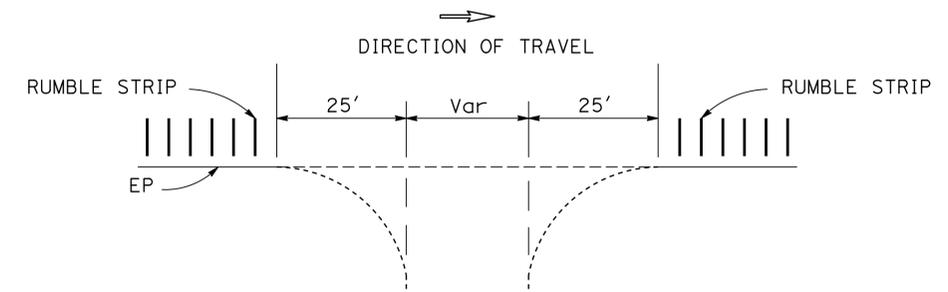

**RUMBLE STRIP GAP AT PRIVATE DRIVEWAY
 TYPICAL DETAIL**

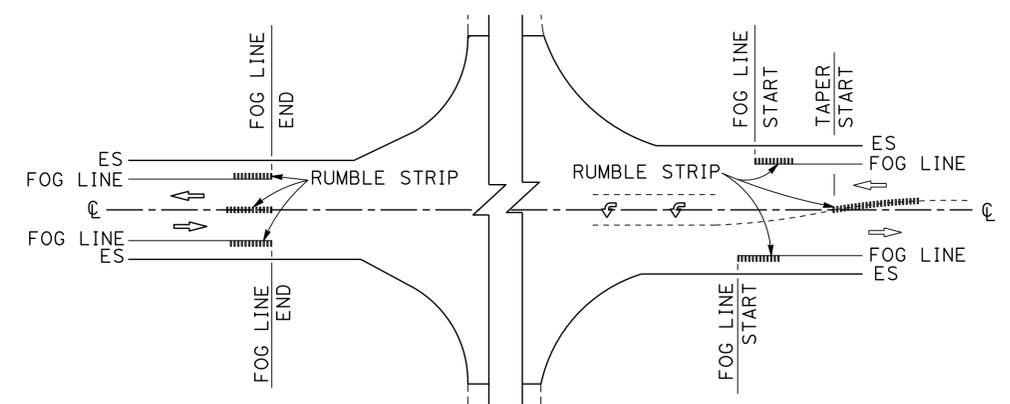

**RUMBLE STRIP GAP AT PUBLIC Rd INTERSECTION
 TYPICAL DETAIL**

CONSTRUCTION DETAILS C-5
 NO SCALE

STATIONARY MOUNTED CONSTRUCTION AREA SIGNS

SIGN No. (X)	SIGN CODE		PANEL SIZE	SIGN MESSAGE	NUMBER OF POSTS AND SIZE	NUMBER OF SIGNS
	FEDERAL	CALIFORNIA				
A	G20-1		60" x 36"	ROAD WORK NEXT 4 MILES	2 - 4" x 6"	2
B	G20-2		36" x 18"	END ROAD WORK	1 - 4" x 4"	15
C	W20-1		36" x 36"	ROAD WORK AHEAD	1 - 4" x 6"	16

NOTE:

EXACT CONSTRUCTION AREA SIGN LOCATIONS WILL BE DETERMINED BY THE ENGINEER.


Dist	COUNTY	ROUTE	POST MILES TOTAL PROJECT	SHEET No.	TOTAL SHEETS
10	Sta	120	0.0/4.1	8	32

Richard B. ... 1/23/15
 REGISTERED CIVIL ENGINEER DATE

1-26-15
 PLANS APPROVAL DATE

THE STATE OF CALIFORNIA OR ITS OFFICERS OR AGENTS SHALL NOT BE RESPONSIBLE FOR THE ACCURACY OR COMPLETENESS OF SCANNED COPIES OF THIS PLAN SHEET.

REGISTERED PROFESSIONAL ENGINEER
 HUE NGUYEN
 No. 74484
 Exp. 12/31/15
 CIVIL
 STATE OF CALIFORNIA

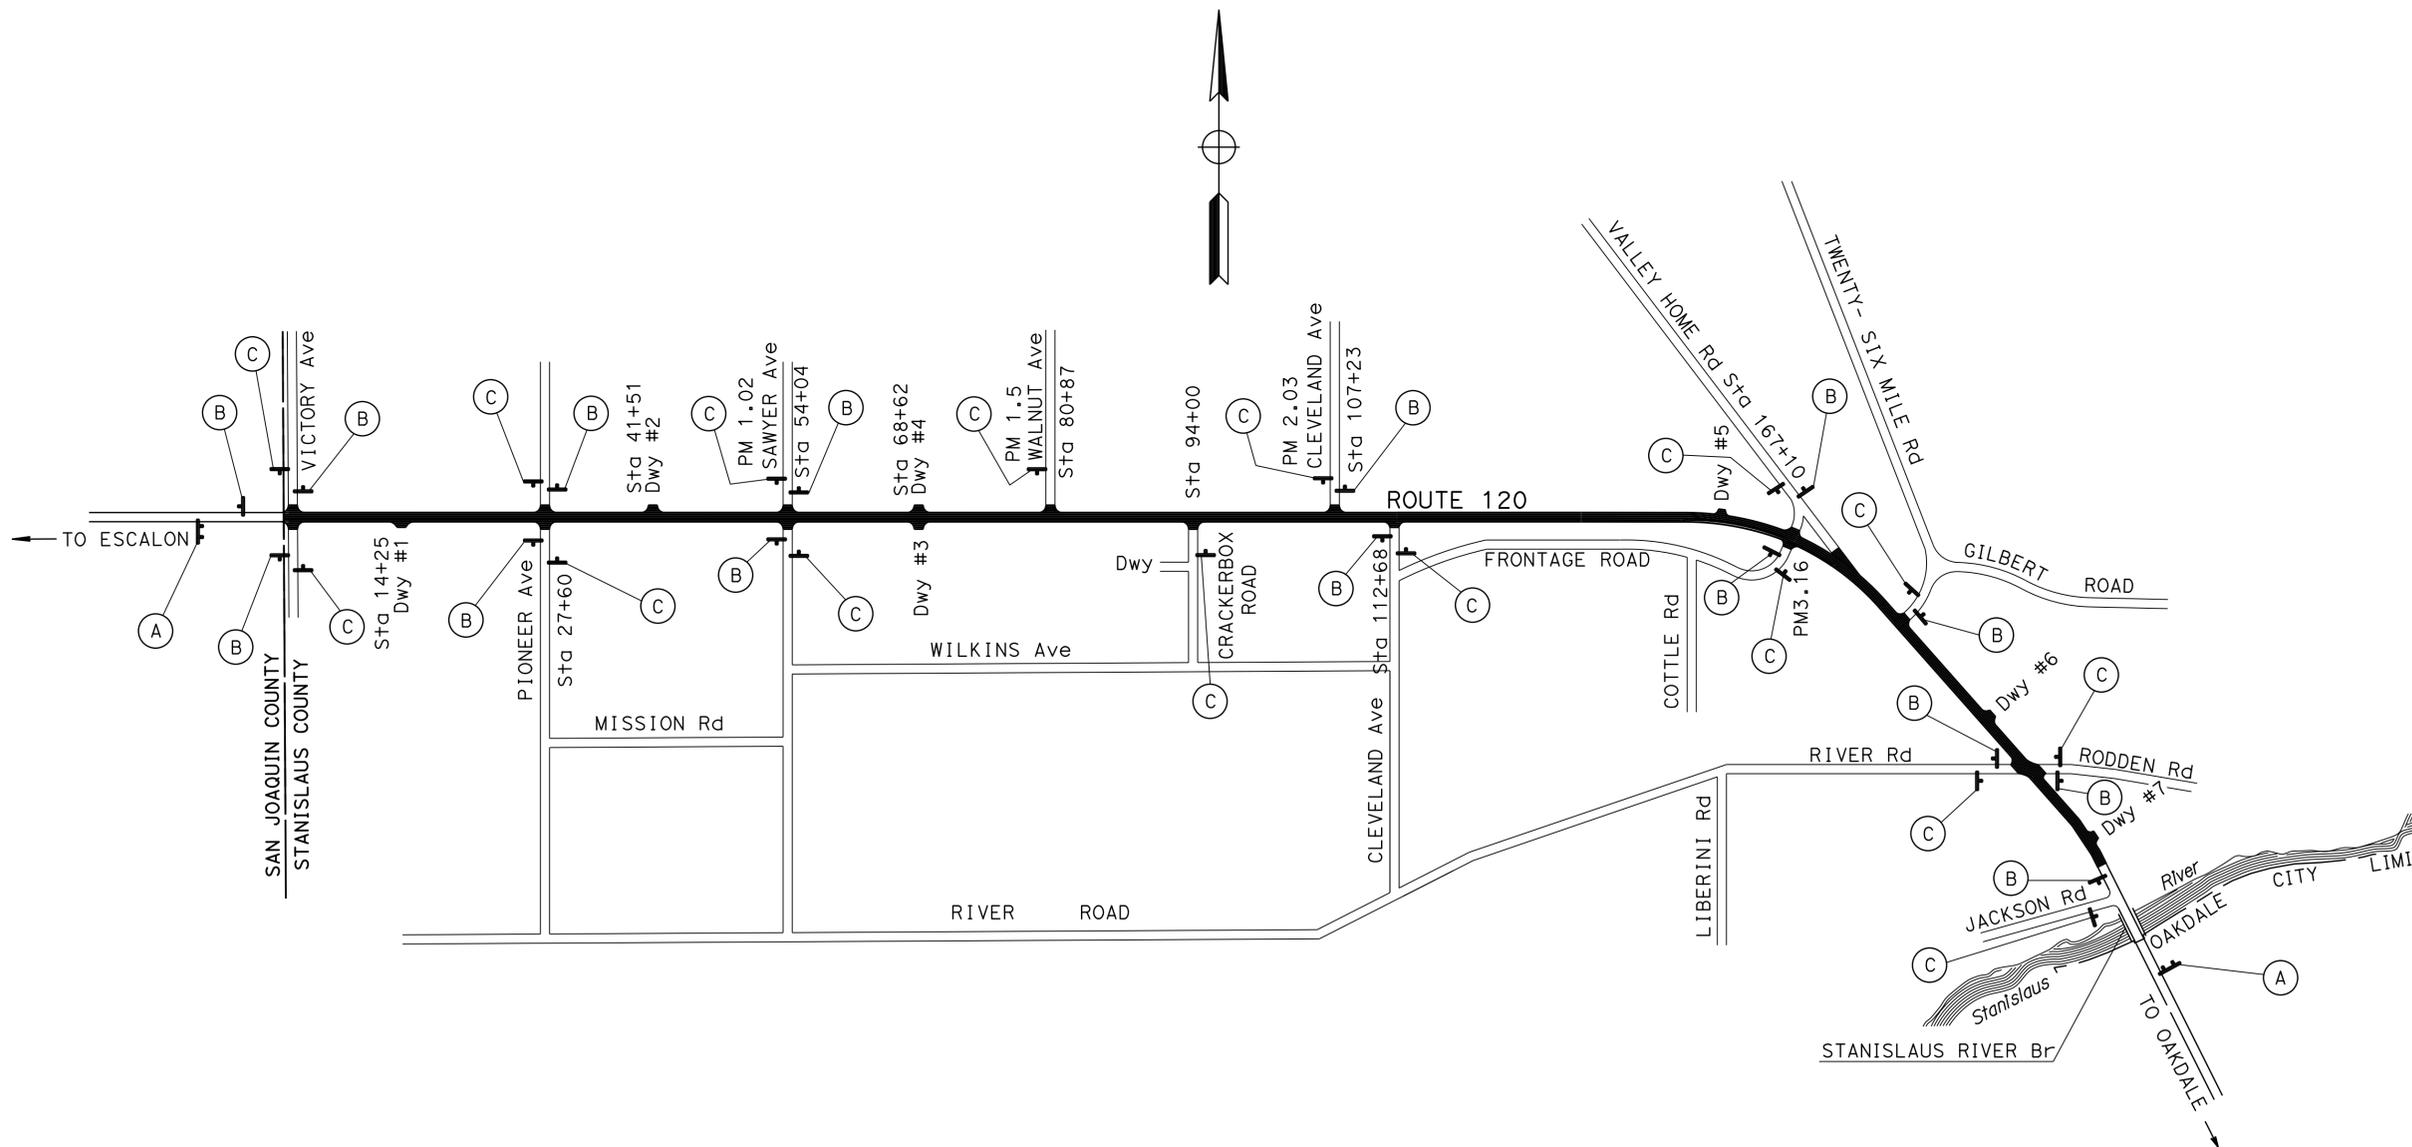

STATE OF CALIFORNIA - DEPARTMENT OF TRANSPORTATION
Caltrans TRAFFIC DESIGN
 FUNCTIONAL SUPERVISOR: MOHAMMED QATAMI
 CALCULATED/DESIGNED BY: [blank] CHECKED BY: [blank]
 RAJINI TEKALKOTE
 HUE NGUYEN
 REVISED BY: [blank] DATE REVISED: [blank]
 RT 1-27-15
 RT 1-07-15

APPROVED FOR CONSTRUCTION AREA SIGN WORK ONLY

CONSTRUCTION AREA SIGNS
 NO SCALE
CS-1

STATE OF CALIFORNIA - DEPARTMENT OF TRANSPORTATION - TRAFFIC DESIGN

FUNCTIONAL SUPERVISOR: MOHAMMED QATAMI

CALCULATED/DESIGNED BY: RAJINI TEKALKOTE

CHECKED BY: HUE NGUYEN

REVISOR: RT

DATE: 1/27/15

Dist	COUNTY	ROUTE	POST MILES TOTAL PROJECT	SHEET No.	TOTAL SHEETS
10	Sta	120	0.0/4.1	9	32

1/23/15
 REGISTERED CIVIL ENGINEER DATE
 1-26-15
 PLANS APPROVAL DATE

HUE NGUYEN
 No. 74484
 Exp. 12/31/15
 CIVIL
 STATE OF CALIFORNIA

THE STATE OF CALIFORNIA OR ITS OFFICERS OR AGENTS SHALL NOT BE RESPONSIBLE FOR THE ACCURACY OR COMPLETENESS OF SCANNED COPIES OF THIS PLAN SHEET.

PAVEMENT DELINEATION QUANTITIES (MAINLINE)

POST MILE	DIRECTION	THERMOPLASTIC TRAFFIC STRIPE (SPRAYABLE)							THERMOPLASTIC PAVEMENT MARKING						PAVEMENT MARKER (RETRO-REFLECTIVE)			REMOVE PAVEMENT MARKER		
		4" YELLOW					4" WHITE		8" WHITE SOLID	CROSSWALK	LIMIT LINE	SIGNAL AHEAD	TYPE III(L) ARROW	TYPE IV(R) ARROW	TYPE VI ARROW	TYPE G	TYPE H		TYPE D	
		DETAIL	DETAIL	DETAIL	DETAIL	DETAIL	DETAIL	DETAIL	DETAIL											SQFT
		6	19	22	29	32	27B	27C	38											
0.0 TO 4.1	EB	8,448	4,890	6,785	235	1,205	20,640	915	1,300	206	32	32	31	630	30	42	55	205	926	1198
	WB						19,975	1,535	250											
		8,448	4,890	6,785	235	1,205	40,615	2,450	1,550	206	32	32	31	630	30	42	67	205	926	
		66,178							1003						1198*			1198*		

* - SUBTOTAL INCLUDED IN THE PAVEMENT DELINEATION QUANTITIES (LOCAL ROADS) TABLE.

PAVEMENT DELINEATION QUANTITIES (LOCAL ROADS)

LOCATION	SIDE	PAINT TRAFFIC STRIPE (2-COAT)				PAINT PAVEMENT MARKING (2-COAT)						PAVEMENT MARKER (RETRO-REFLECTIVE)		REMOVE PAVEMENT MARKER	
		4" YELLOW SOLID		4" WHITE SOLID		CROSSWALK	LIMIT LINE	YIELD	STOP	TYPE III(L) ARROW	TYPE III(R) ARROW	TYPE G	TYPE D		
		DETAIL	DETAIL	DETAIL	DETAIL										SQFT
		21	29	27B	38										
VICTORY Ave	L+	60					26		22						
VICTORY Ave	R+	48					41		22						
PIONEER Ave	L+	48					43		22						
PIONEER Ave	R+	40					32		22						
SAWYER Ave	L+	60					39		22						
SAWYER Ave	R+	48					37		22						
DWY # 4							40								
WALNUT Ave		38					46		22						
CRACKERBOX Rd		38					42		22						
CLEVELAND Ave	L+	38					32		22						
CLEVELAND Ave	R+	38					36		22						
FRONTAGE Rd		52					30		22						
VALLEY HOME Rd			243	292	70		55	24	22			4	12		
26 MILE Rd		84		96			43		22						
DWY # 6							32								
RIVER Rd		62				130									
RODDEN Rd		112		82		58	24								
DWY # 7		72			88		30		44	42	42	5			
SUBTOTAL		838	243	470	158	188	628	24	330	42	42	9	12		
TOTAL THIS SHEET		1709				1254						21		21	
SUBTOTAL MAINLINE												1198		1198	
TOTAL		1709				1254						1219		1219	

ROADSIDE SIGN QUANTITIES

LOCATION	SIGN CODE		RESET ROADSIDE SIGN
	FEDERAL	CALIFORNIA	EA
VALLEY HOME Rd	R1-1		1
	W4-4P		
	R4-7		1
		TYPE N MARKER	
TOTAL			2

PAVEMENT DELINEATION AND SIGN QUANTITIES PDQ-1

STATE OF CALIFORNIA - DEPARTMENT OF TRANSPORTATION
Caltrans
 DESIGN

NOTES:

- 1. ACTUAL LOCATIONS AND DIMENSIONS OF REPAIR FAILED AREA AND RUMBLE STRIP WILL BE DETERMINED BY THE ENGINEER.
- * QUANTITY INCLUDED IN ROADWAY ITEMS TABLE.
- (N) NOT A SEPARATE PAY ITEM, FOR INFORMATION ONLY.

ABBREVIATION:

RHMA-G - RUBBERIZED HOT MIX ASPHALT (GAP GRADED)

Dist	COUNTY	ROUTE	POST MILES TOTAL PROJECT	SHEET No.	TOTAL SHEETS
10	Sta	120	0.0/4.1	10	32

REGISTERED CIVIL ENGINEER DATE 1/23/15
 Richard J. Boyer
 No. 75844
 Exp. 6/30/16
 CIVIL
 1-26-15
 PLANS APPROVAL DATE
THE STATE OF CALIFORNIA OR ITS OFFICERS OR AGENTS SHALL NOT BE RESPONSIBLE FOR THE ACCURACY OR COMPLETENESS OF SCANNED COPIES OF THIS PLAN SHEET.

ROADWAY QUANTITIES

LOCATION	COLD PLANE AC PAVEMENT	HOT MIX ASPHALT (TYPE A)	RUBBERIZED HOT MIX ASPHALT GAP GRADED	TACK COAT	SHOULDER BACKING	REMOVE CONCRETE (MISCELLANEOUS)	MINOR CONCRETE (CURB RAMP)	DETECTABLE WARNING SURFACE	ASPHALT-RUBBER BINDER	PRECOATED SCREENINGS
	SQYD	TON	TON	TON	TON	CY	CY	SQYD	TON	TON
PM 0.0/4.1	98,090.8	13,078.7	6539.4	31	2200				300	2150
REPAIR FAILED AREA	20,561.9	3437.3		6						
LOCAL ROADS		558.0		2						
PRIVATE DRIVEWAYS		15.0		1						
DIKE QUANTITIES		236.0								
CONFORM TAPERS AT INTERSECTIONS	712.3	21.8								
CONFORM TAPERS AT MBGR	106.8		6.0							
CONFORM TAPERS AT CURB AND GUTTER	279.0		6.0							
CONFORM TAPERS AT BEGIN / END Const	296.0		10.0							
RIVER Rd/RODDEN Rd Rte 120 INTERSECTION						4	4			
Sta 10+67.97 LINE "AA", 2.07' R+								12		
Sta 11+02.00 LINE "AA", 2.00' R+								12		
SAFETY EDGE		413.6								
OVER SIDE DRAIN QUANTITIES		4.5								
TOTAL	120,046.8	17,764.9	6561.4	40	2200	4	4	24	300	2150

DIKE QUANTITIES

LOCATION	REMOVE AC DIKE	PLACE HMA DIKE (TYPE E)	PLACE HMA DIKE (TYPE F)	HMA (TYPE A)
PM TO PM	LF	LF	LF	TON
0.0 TO 0.12 R+	64		64	1
0.0 TO 0.12 L+	64		64	1
0.58 TO 1.02 R+	2323	2323		60
1.23 TO 1.50 R+	1426	1426		38
2.12 TO 2.96 L+	4435	4435		116
4.01 TO 4.10 R+	284	284		8
4.01 TO 4.10 L+	284		284	4
4.01 TO 4.10 R+	284	284		8
TOTAL	9164	8752	412	236*

REPAIR FAILED AREA

LOCATION	LENGTH	WIDTH	COLD PLANE AC Pvm†	HMA (TYPE A)
PM	(N)	(N)	SQYD	TON
0.0 TO 0.9 EB	6973'	4'	3099.1	516.5
0.0 TO 0.9 WB	2419'	12'	3225.3	537.6
1.0 TO 3.0 EB	913'	4'	405.7	67.6
1.0 TO 3.0 WB	10670'	4'	4742.2	790.3
3.2 TO 4.0 EB	2951'	4'	1311.5	218.5
3.2 TO 4.0 EB	2565'	12'	3420.0	570.0
3.2 TO 4.0 EB	204'	4'	90.7	22.6
3.2 TO 4.0 WB	5779'	4'	2568.4	431.1
3.2 TO 4.0 WB	1231'	12'	1641.3	273.5
4.0 TO 4.1 EB	130'	4'	57.7	9.6
TOTAL			20,561.9*	3,437.3*

CONFORM TAPERS BEGIN/END CONSTRUCTION

LOCATION	PM	LENGTH	WIDTH	COLD PLANE AC Pvm†	RHMA-G
DESCRIPTION		(N)	(N)	SQYD	TON
ROUTE 120 (BEGIN CONSTRUCTION)	0.00	30'	44'	148	5
ROUTE 120 (END CONSTRUCTION)	4.10	30'	44'	148	5
SUBTOTAL				296*	10*

CONFORM TAPERS AT MBGR

LOCATION	PM	LENGTH	WIDTH	COLD PLANE AC Pvm†	RHMA-G
		(N)	(N)	SQYD	TON
VICTORY AVENUE (R+)	0.0	60'	4'	26.7	1.5
VICTORY AVENUE (L+)	0.0	60'	4'	26.7	1.5
PM 3.31 (R+)		60'	4'	26.7	1.5
Dwy #7 (L+)	4.01	60'	4'	26.7	1.5
SUBTOTAL				106.8*	6.0*

CONFORM TAPERS AT CURB AND GUTTER

LOCATION	SIDE	LENGTH	WIDTH	COLD PLANE AC Pvm†	RHMA-G
PM		(N)	(N)	SQYD	TON
3.16	L+	88'	4'	40	1.5
3.18	R+	156'	8'	139	2.5
3.8 (A1 CURB)	R+/L+	224'	4'	100	2.0
SUBTOTAL				279*	6.0*

SUMMARY OF QUANTITIES

Q-1

LAST REVISION DATE PLOTTED => 09-FEB-2015 TIME PLOTTED => 16:57

Dist	COUNTY	ROUTE	POST MILES TOTAL PROJECT	SHEET No.	TOTAL SHEETS
10	Sta	120	0.0/4.1	12	32

REGISTERED ELECTRICAL ENGINEER	DATE	1/23/15
PLANS APPROVAL DATE	1-26-15	
<small>THE STATE OF CALIFORNIA OR ITS OFFICERS OR AGENTS SHALL NOT BE RESPONSIBLE FOR THE ACCURACY OR COMPLETENESS OF SCANNED COPIES OF THIS PLAN SHEET.</small>		

LEGEND:




- 1 RC Exist PBA, INSTALL LED COUNTDOWN PSF MODULE IN THE Exist HOUSING FOR Ø2P.
- 2 PBA POST AND APS ASSEMBLY FOR Ø2P.
- 3 1½"C, 2#14 (APS), 1-APS CABLE
- 4 PBA POST AND APS ASSEMBLY FOR Ø8P.
- 5 RC Exist PBA, INSTALL LED COUNTDOWN PSF MODULE IN THE Exist HOUSING FOR Ø8P.
- 6 SC Exist TYPE A AND PROPOSED TYPE D LOOP DETECTORS IN Exist PB AS SHOWN IN DETAIL A ON THIS SHEET.
- 7 Exist 3"C, 1-12CSC, 1-9CSC, 2#10 (Ltg), 1-EVUC, 3 DLC, ADD 1 DLC
- 8 Exist 3"C, 5-12CSC, 3-9CSC, 1-3CSC, 2#10 (Ltg), 2#10 (FB), 4-EVUC, 8 DLC, ADD 2 DLC
- 9 Exist 2-3"C, 5-12CSC, 3-9CSC, 1-3CSC, 4-EVUC, 10 DLC, ADD 2 DLC
- 10 Exist 3"C, 4-12CSC, 1-9CSC, 2#10 (Ltg), 2#10 (FB), 3-EVUC, 5 DLC, ADD 1 DLC
- 11 Exist 3"C, 3-12CSC, 1-9CSC, 2#10 (Ltg), 2#10 (FB), 2-EVUC, 5 DLC, ADD 1 DLC
- 12 Exist 1½"C, 3 DLC, ADD 1 DLC
- 13 SC TYPE A AND TYPE D LOOP DETECTORS IN Exist PB AS SHOWN IN DETAIL A ON THIS SHEET.
- 14 AB Exist LOOP DETECTORS AND INSTALL LOOP DETECTORS AS SHOWN.

NOTE:

FOR ACCURATE RIGHT OF WAY DATA, CONTACT RIGHT OF WAY ENGINEERING AT THE DISTRICT OFFICE.

ABBREVIATION:

PSF - PEDESTRIAN SIGNAL FACE

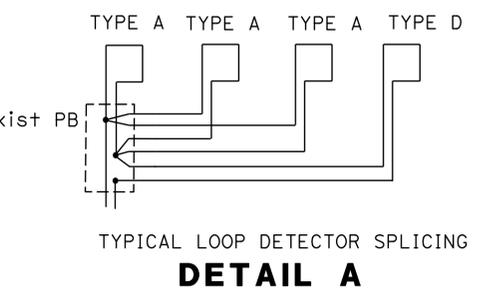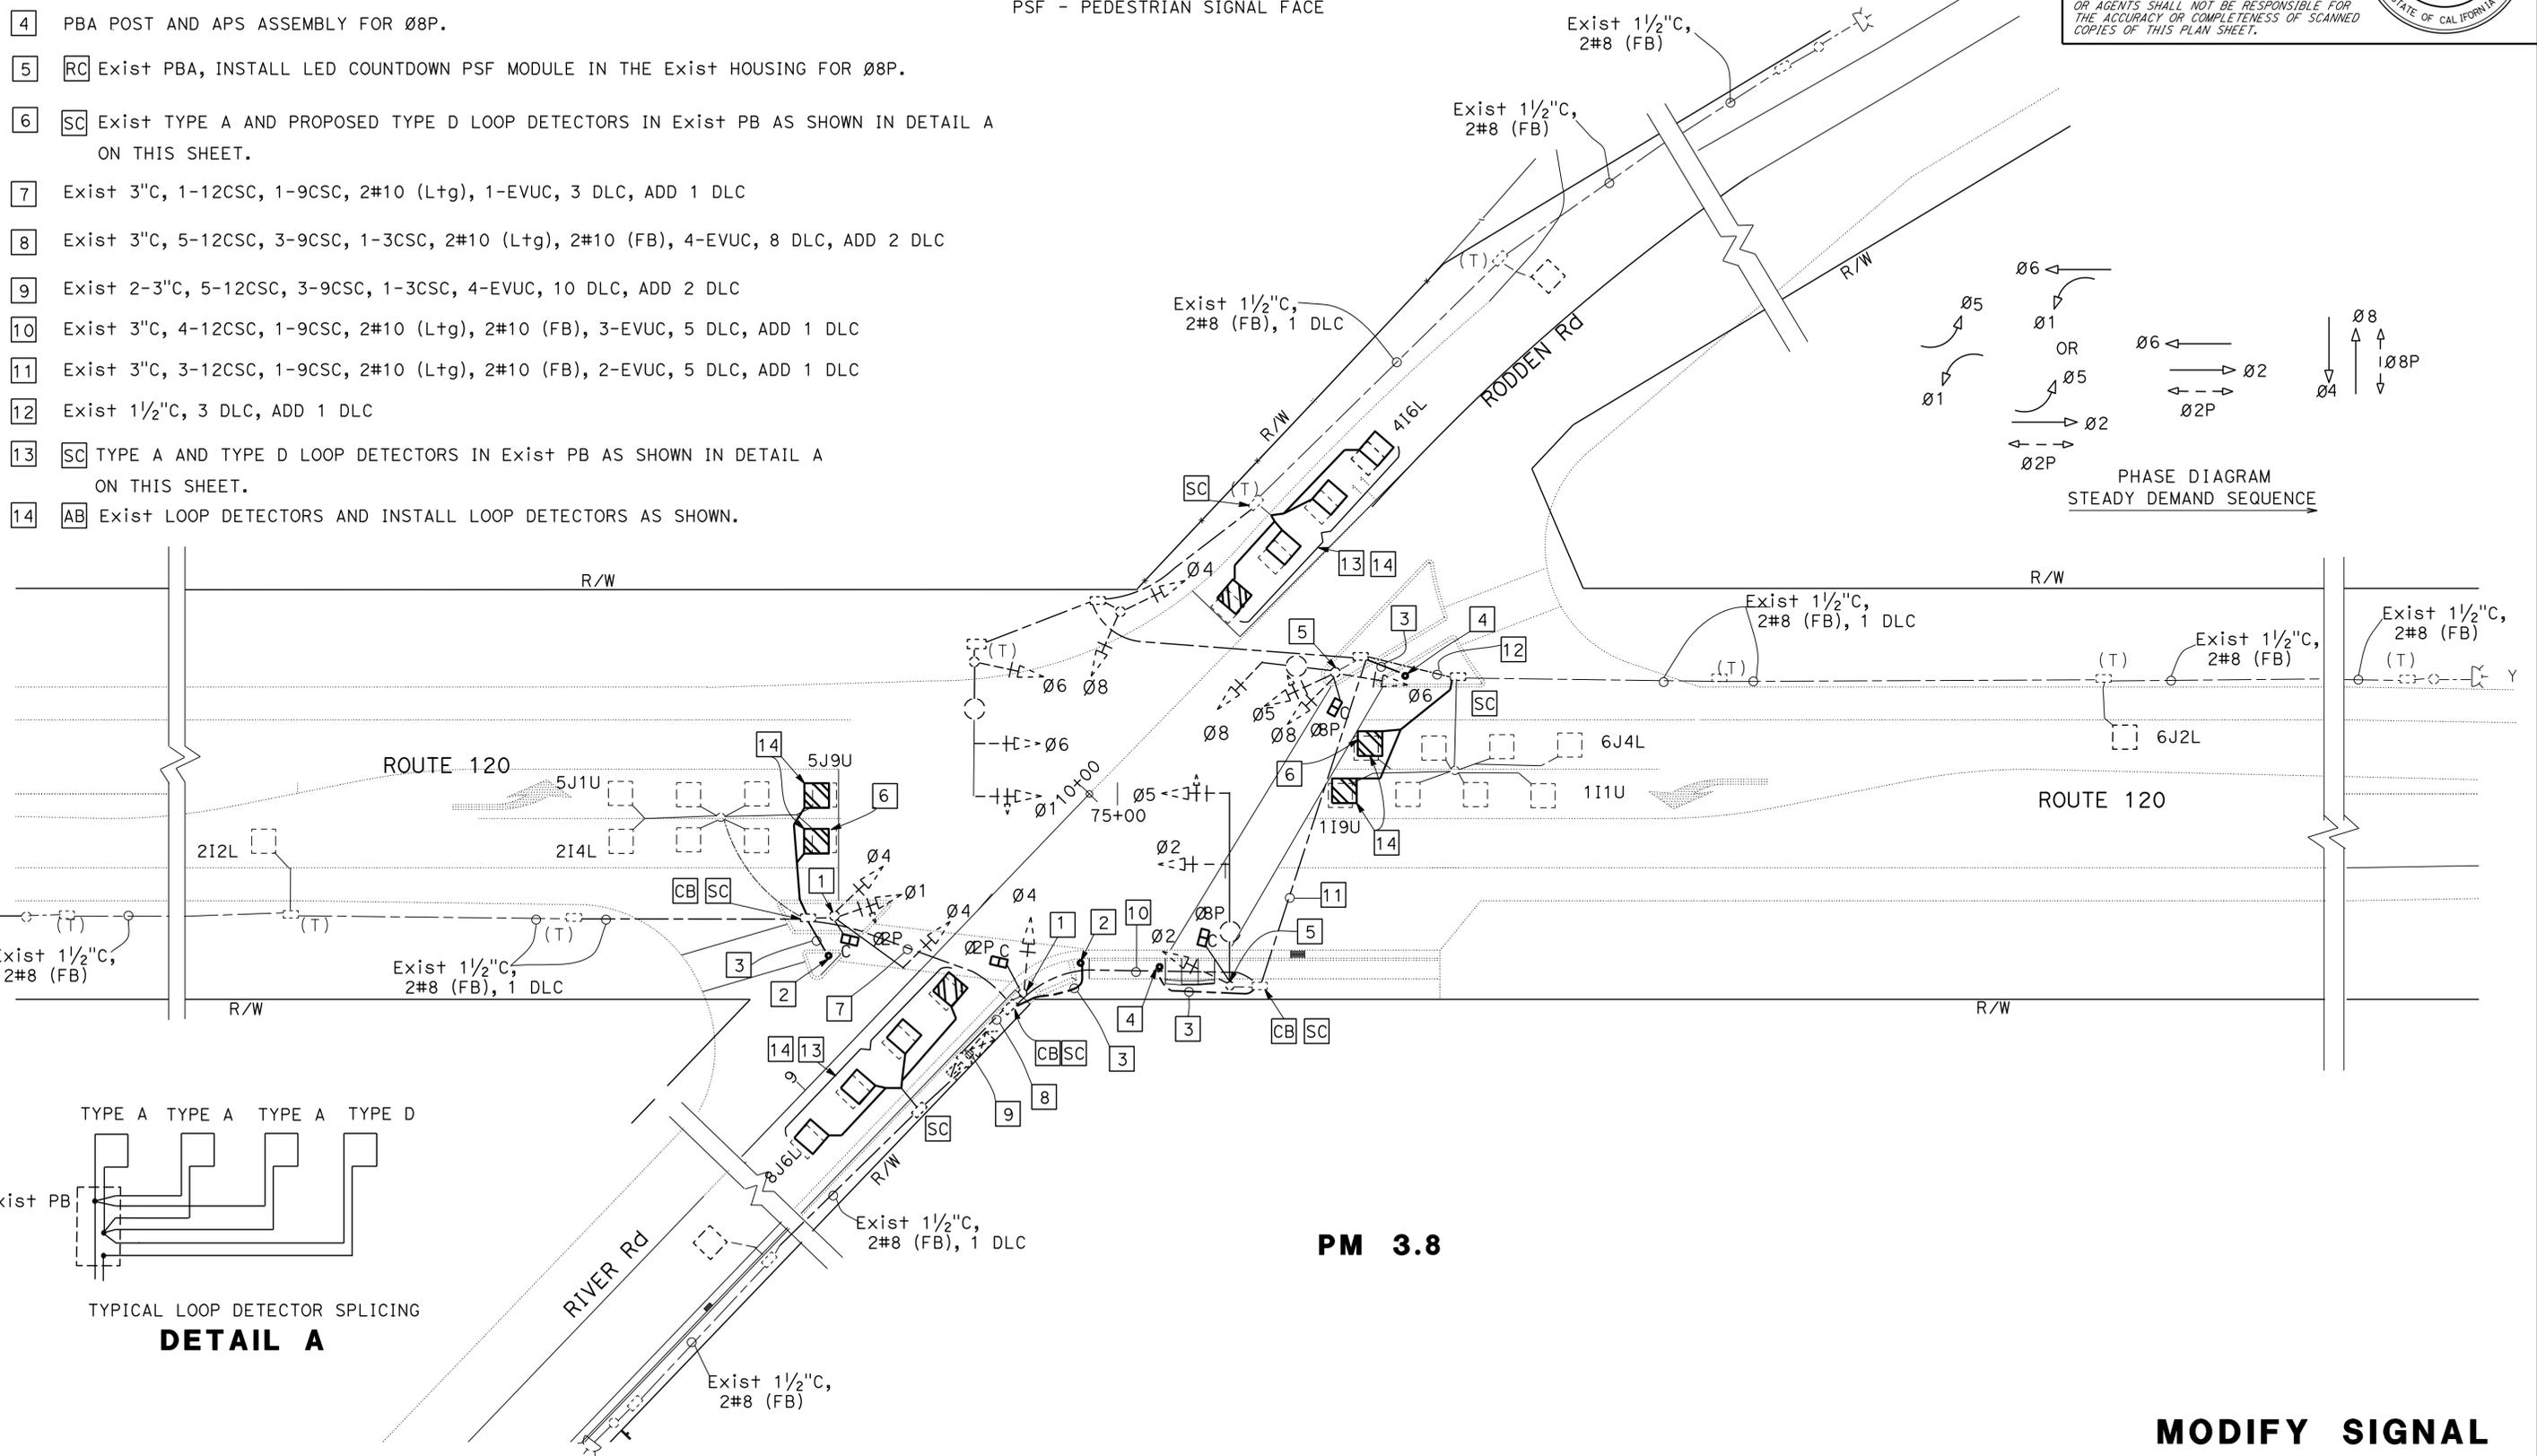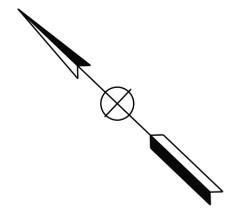

PM 3.8

APPROVED FOR ELECTRICAL WORK ONLY

MODIFY SIGNAL E-1
SCALE: 1"=50'

STATE OF CALIFORNIA - DEPARTMENT OF TRANSPORTATION
Caltrans ELECTRICAL DESIGN
 FUNCTIONAL SUPERVISOR: ALI BAKHDOD
 JASPAL SINGH
 JASPAL SINGH
 JS
 1/27/15
 REVISIONS: 1, 2, 3, 4, 5, 6, 7, 8, 9, 10, 11, 12, 13, 14

STATE OF CALIFORNIA - DEPARTMENT OF TRANSPORTATION
Caltrans® ELECTRICAL DESIGN

FUNCTIONAL SUPERVISOR
 ALT BAKHDOUD

CALCULATED-DESIGNED BY
 CHECKED BY

JASPAL SINGH
 JASPAL SINGH


REVISED BY
 DATE REVISED

JS
 1-27-15


NOTE:

THE QUANTITIES SHOWN IN THE TABLE ARE NOT SEPARATE PAY ITEMS, FOR INFORMATION ONLY.
 FOR COMPLETE ELECTRICAL WORK, SEE ELECTRICAL PLANS.

Dist	COUNTY	ROUTE	POST MILES TOTAL PROJECT	SHEET No.	TOTAL SHEETS
10	S+a	120	0.0/4.1	13	32

  1/23/15
 REGISTERED ELECTRICAL ENGINEER DATE

1-26-15
 PLANS APPROVAL DATE

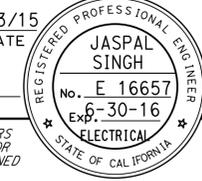

THE STATE OF CALIFORNIA OR ITS OFFICERS OR AGENTS SHALL NOT BE RESPONSIBLE FOR THE ACCURACY OR COMPLETENESS OF SCANNED COPIES OF THIS PLAN SHEET.

MODIFY SIGNAL

SHEET No.	TYPE A LOOP DETECTORS	TYPE D LOOP DETECTORS	PBA POST WITH FOUNDATION	APS ASSEMBLY	LED COUNTDOWN PSF MODULE	APS CABLE	DLC	No.14 CONDUCTOR	1 1/2" C, TYPE 3
	EA						LF		
E-1	6	6	4	4	4	70	210	60	45

ELECTRICAL QUANTITIES

E-2



	M	
Maint	MAINTENANCE	
Max	MAXIMUM	
MB	METAL BEAM	
MBB	METAL BEAM BARRIER	
MBGR	METAL BEAM GUARD RAILING	
Med	MEDIAN	
MGS	MIDWEST GUARDRAIL SYSTEM	
MH	MANHOLE	
Min	MINIMUM	
Misc	MISCELLANEOUS	
Misc I & S	MISCELLANEOUS IRON AND STEEL	
Mkr	MARKER	
Mod	MODIFIED, MODIFY	
Mon	MONUMENT	
MP	METAL PLATE	
MPGR	METAL PLATE GUARD RAILING	
MR	MOVEMENT RATING	
MSE	MECHANICALLY STABILIZED EMBANKMENT	
Mt	MOUNTAIN, MOUNT	
MtI	MATERIAL	
MVP	MAINTENANCE VEHICLE PULLOUT	
	N	
N	NORTH	
NB	NORTHBOUND	
No.	NUMBER (MUST HAVE PERIOD)	
Nos.	NUMBERS (MUST HAVE PERIOD)	
NPS	NOMINAL PIPE SIZE	
NS	NEAR SIDE	
NSP	NEW STANDARD PLAN	
NTS	NOT TO SCALE	
	O	
Obir	OBLITERATE	
OC	OVERCROSSING	
OD	OUTSIDE DIAMETER	
OF	OUTSIDE FACE	
OG	ORIGINAL GROUND	
OGAC	OPEN GRADED ASPHALT CONCRETE	
OGFC	OPEN GRADED FRICTION COURSE	
OH	OVERHEAD	
OHWM	ORDINARY HIGH WATER MARK	
O-O	OUT TO OUT	
Opp	OPPOSITE	
OSD	OVERSIDE DRAIN	
	P	
p	PAGE	
PAP	PERFORATED ALUMINUM PIPE	
PB	PULL BOX	
PC	POINT OF CURVATURE, PRECAST	
PCC	POINT OF COMPOUND CURVE, PORTLAND CEMENT CONCRETE	
PCMS	PORTABLE CHANGEABLE MESSAGE SIGN	
PCP	PERFORATED CONCRETE PIPE, PRESTRESSED CONCRETE PIPE	
PCVC	POINT OF COMPOUND VERTICAL CURVE	
PEC	PERMIT TO ENTER AND CONSTRUCT	
Ped	PEDESTRIAN	
Ped OC	PEDESTRIAN OVERCROSSING	
Ped UC	PEDESTRIAN UNDERCROSSING	
Perm MtI	PERMEABLE MATERIAL	

	P continued	
PG	PROFILE GRADE	
PI	POINT OF INTERSECTION	
PJP	PARTIAL JOINT PENETRATION	
Pkwy	PARKWAY	
PL, PL	PLATE	
P/L	PROPERTY LINE	
PM	POST MILE, TIME FROM NOON TO MIDNIGHT	
PN	PAVING NOTCH	
POC	POINT OF HORIZONTAL CURVE	
POT	POINT OF TANGENT	
POVC	POINT OF VERTICAL CURVE	
PP	PIPE PILE, PLASTIC PIPE, POWER POLE	
PPL	PREFORMED PERMEABLE LINER	
PPP	PERFORATED PLASTIC PIPE	
PRC	POINT OF REVERSE CURVE	
PRF	PAVEMENT REINFORCING FABRIC	
PRVC	POINT OF REVERSE VERTICAL CURVE	
PS&E	PLANS, SPECIFICATIONS AND ESTIMATES	
PS, P/S	PRESTRESSED	
PSP	PERFORATED STEEL PIPE	
PT	POINT OF TANGENCY	
PVC	POLYVINYL CHLORIDE	
Pvmt	PAVEMENT	
	Q	
Qty	QUANTITY	
	R	
R	RADIUS	
R & D	REMOVE AND DISPOSE	
R & S	REMOVE AND SALVAGE	
R/C	RATE OF CHANGE	
RCA	REINFORCED CONCRETE ARCH	
RCB	REINFORCED CONCRETE BOX	
RCP	REINFORCED CONCRETE PIPE	
RCPA	REINFORCED CONCRETE PIPE ARCH	
Rd	ROAD	
Reinf	REINFORCED, REINFORCEMENT, REINFORCING	
Rel	RELOCATE	
Repl	REPLACEMENT	
Ret	RETAINING	
Rev	REVISED, REVISION	
Rdwy	ROADWAY	
RHMA	RUBBERIZED HOT MIX ASPHALT	
Riv	RIVER	
RM	ROAD-MIXED	
RP	RADIUS POINT, REFERENCE POINT	
RR	RAILROAD	
RSP	ROCK SLOPE PROTECTION, REVISED STANDARD PLAN	
Rt	RIGHT	
Rte	ROUTE	
RW	REDWOOD, RETAINING WALL	
R/W	RIGHT OF WAY	
Rwy	RAILWAY	

	S	
S	SOUTH, SUPPLEMENT	
SAE	STRUCTURE APPROACH EMBANKMENT	
Salv	SALVAGE	
SAPP	STRUCTURAL ALUMINUM PLATE PIPE	
SB	SOUTHBOUND	
SC	SAND CUSHION	
SCSP	SLOTTED CORRUGATED STEEL PIPE	
SD	STORM DRAIN	
Sec	SECOND, SECTION	
Sep	SEPARATION	
SG	SUBGRADE	
Shld	SHOULDER	
Sht	SHEET	
Sim	SIMILAR	
SL	STATION LINE	
SM	SELECTED MATERIAL	
Spec	SPECIAL, SPECIFICATIONS	
SPP	SLOTTED PLASTIC PIPE	
SS	SLOPE STAKE	
SSBM	STRAP AND SADDLE BRACKET METHOD	
SSD	STRUCTURAL SECTION DRAIN	
SSPA	STRUCTURAL STEEL PLATE ARCH	
SSPP	STRUCTURAL STEEL PLATE PIPE	
SSPPA	STRUCTURAL STEEL PLATE PIPE ARCH	
SSRP	STEEL SPIRAL RIB PIPE	
St	STREET	
Sta	STATION	
STBB	SINGLE THRIE BEAM BARRIER	
Std	STANDARD	
Str	STRUCTURE	
Surf	SURFACING	
SW	SIDEWALK, SOUND WALL	
Swr	SEWER	
Sym	SYMMETRICAL	
S4S	SURFACE 4 SIDES	
	T	
T	SEMI-TANGENT	
Tan	TANGENT	
TBB	THRIE BEAM BARRIER	
Tbr	TIMBER	
TC	TOP OF CURB	
TCB	TRAFFIC CONTROL BOX	
TCE	TEMPORARY CONSTRUCTION EASEMENT	
TeI	TELEPHONE	
Temp	TEMPORARY	
TG	TOP OF GRADE	
Tot	TOTAL	
TP	TELEPHONE POLE	
TPB	TREATED PERMEABLE BASE	
TPM	TREATED PERMEABLE MATERIAL	
Trans	TRANSITION	

	T continued	
TS	TRANSVERSE, TRAFFIC SIGNAL, TUBULAR STEEL	
Typ	TYPICAL	U
UC	UNDERCROSSING	
UD	UNDERDRAIN	
UG	UNDERGROUND	
UON	UNLESS OTHERWISE NOTED	
UP	UNDERPASS	V
V	VALVE, DESIGN SPEED	
Var	VARIABLE, VARIES	
VC	VERTICAL CURVE	
VCP	VITRIFIED CLAY PIPE	
Vert	VERTICAL	
Via	VIADUCT	
Vol	VOLUME	W
W	WEST, WIDTH	
WB	WESTBOUND	
WH	WEEP HOLE	
WM	WIRE MESH	
WS	WATER SURFACE	
WSP	WELDED STEEL PIPE	
Wt	WEIGHT	
WV	WATER VALVE	
WW	WINGWALL	
WWLOL	WINGWALL LAYOUT LINE	X
X Sec	CROSS SECTION	
Xing	CROSSING	Y
Yr	YEAR	
Yrs	YEARS	

Dist	COUNTY	ROUTE	POST MILES TOTAL PROJECT	SHEET No.	TOTAL SHEETS
10	Sta	120	0.0/4.1	14	32



Grace M. Tsushima
 REGISTERED CIVIL ENGINEER
 July 19, 2013
 PLANS APPROVAL DATE

THE STATE OF CALIFORNIA OR ITS OFFICERS OR AGENTS SHALL NOT BE RESPONSIBLE FOR THE ACCURACY OR COMPLETENESS OF SCANNED COPIES OF THIS PLAN SHEET.

TO ACCOMPANY PLANS DATED 1-26-15

UNIT OF MEASUREMENT SYMBOLS:

Some of the symbols used in the project plan quantity tables and in the Bid Item List are:

SYMBOL USED	DEFINITIONS
ACRE	ACRE
CF	CUBIC FOOT
CY	CUBIC YARD
EA	EACH
GAL	GALLON
LB	POUND
LF	LINEAR FOOT
SQFT	SQUARE FOOT
SQYD	SQUARE YARD
STA	100 FEET
TAB	TABLET
TON	2,000 POUNDS

Some of the symbols used in the plans other than in the project plan quantity tables are:

SYMBOL USED	DEFINITIONS
ksi	KIPS PER SQUARE INCH
ksf	KIPS PER SQUARE FOOT
psi	POUNDS PER SQUARE INCH
psf	POUNDS PER SQUARE FOOT
lb/ft ³ , pcf	POUNDS PER CUBIC FOOT
tsf	TONS PER SQUARE FOOT
mph, MPH *	MILES PER HOUR
ø	NOMINAL DIAMETER
oz	OUNCE
lb	POUND
kíp	1,000 POUNDS
cal	CALORIE
ft	FOOT OR FEET
gal	GALLON

* For use on a sign panel only

STATE OF CALIFORNIA
DEPARTMENT OF TRANSPORTATION

**ABBREVIATIONS
(SHEET 2 OF 2)**

NO SCALE

RSP A10B DATED JULY 19, 2013 SUPERSEDES STANDARD PLAN A10B
DATED MAY 20, 2011 - PAGE 2 OF THE STANDARD PLANS BOOK DATED 2010.


2010 REVISED STANDARD PLAN RSP A10B

Dist	COUNTY	ROUTE	POST MILES TOTAL PROJECT	SHEET No.	TOTAL SHEETS
10	Sta	120	0.0/4.1	15	32


Roberto L. McLaughlin
 REGISTERED CIVIL ENGINEER
 April 20, 2012
 PLANS APPROVAL DATE
 THE STATE OF CALIFORNIA OR ITS OFFICERS OR AGENTS SHALL NOT BE RESPONSIBLE FOR THE ACCURACY OR COMPLETENESS OF SCANNED COPIES OF THIS PLAN SHEET.

REGISTERED PROFESSIONAL ENGINEER
 Roberto L. McLaughlin
 No. C40375
 Exp. 3-31-13
 CIVIL
 STATE OF CALIFORNIA


TO ACCOMPANY PLANS DATED 1-26-15

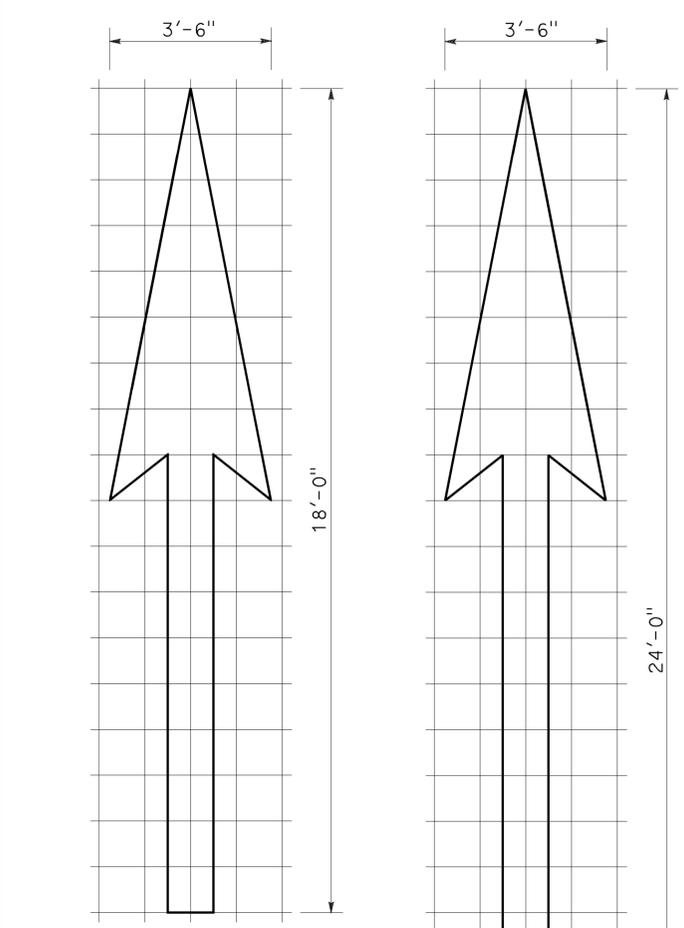


TYPE I 18'-0" ARROW
A=25 ft²

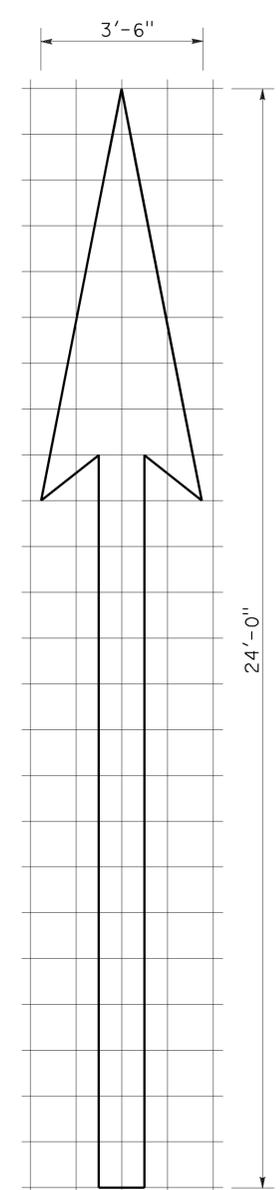


TYPE I 24'-0" ARROW
A=31 ft²

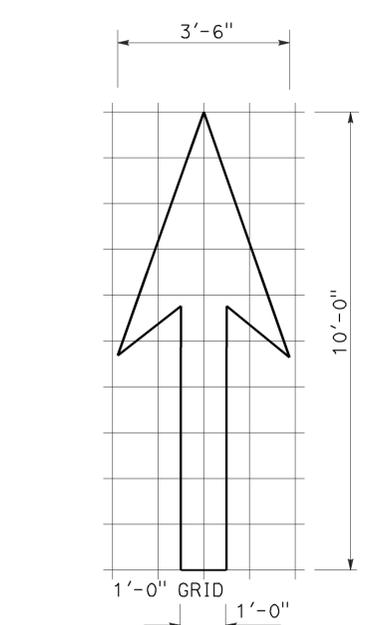


TYPE I 10'-0" ARROW
A=14 ft²

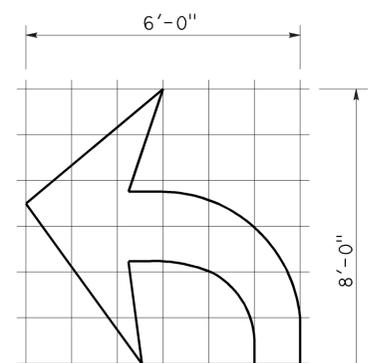


TYPE IV (L) ARROW
A=15 ft²
(For Type IV (R) arrow, use mirror image)

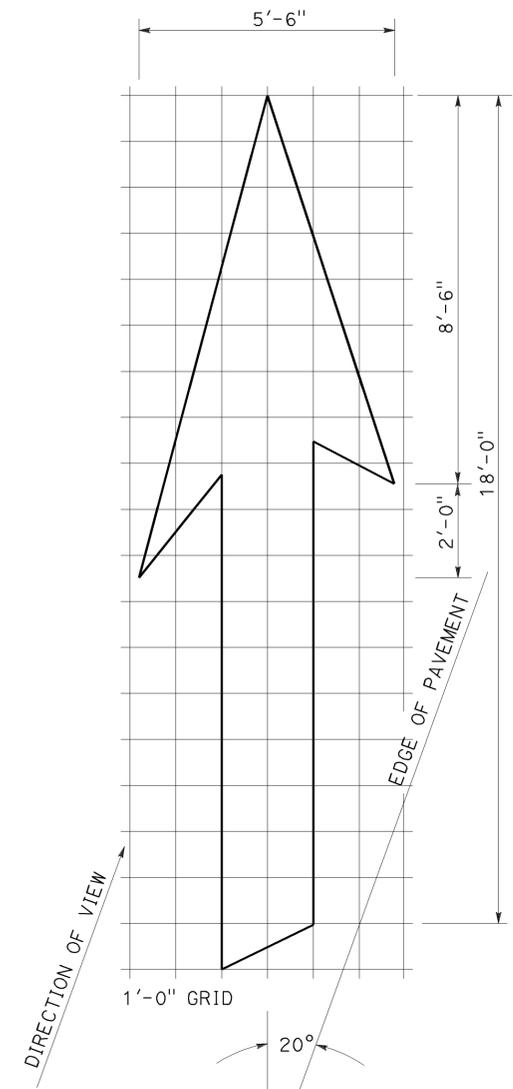


TYPE VI ARROW
A=42 ft²
Right lane drop arrow
(For left lane, use mirror image)

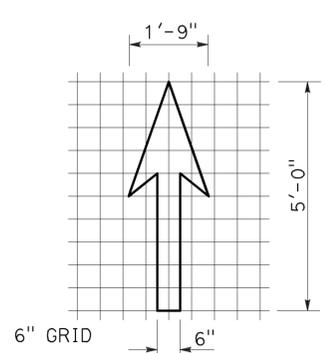


BIKE LANE ARROW
A=3.5 ft²

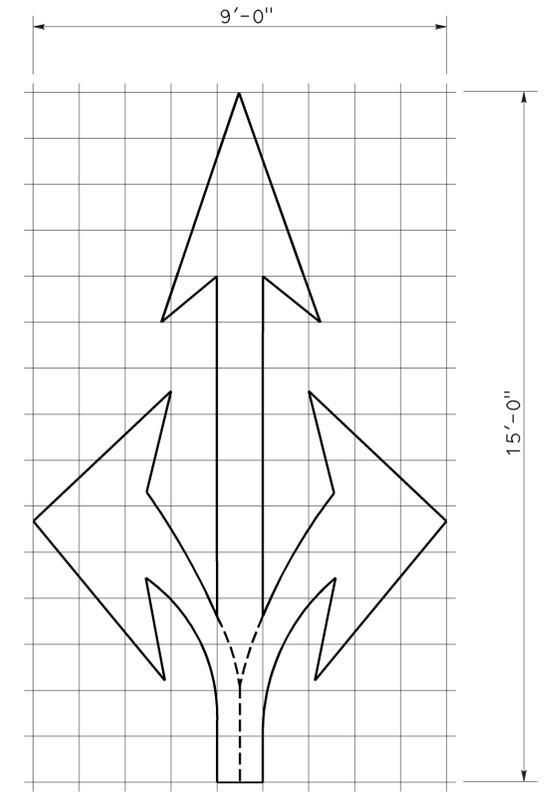

TYPE VIII ARROW
A=36 ft²

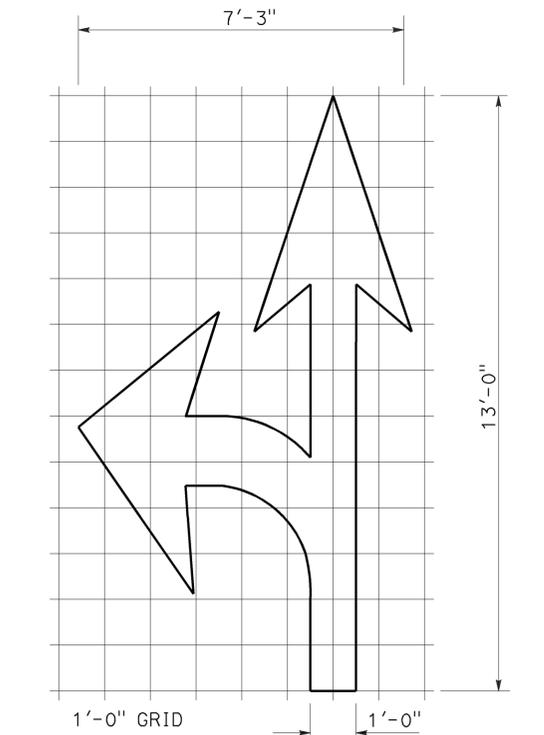

TYPE VII (L) ARROW
A=27 ft²
(For Type VII (R) arrow, use mirror image)

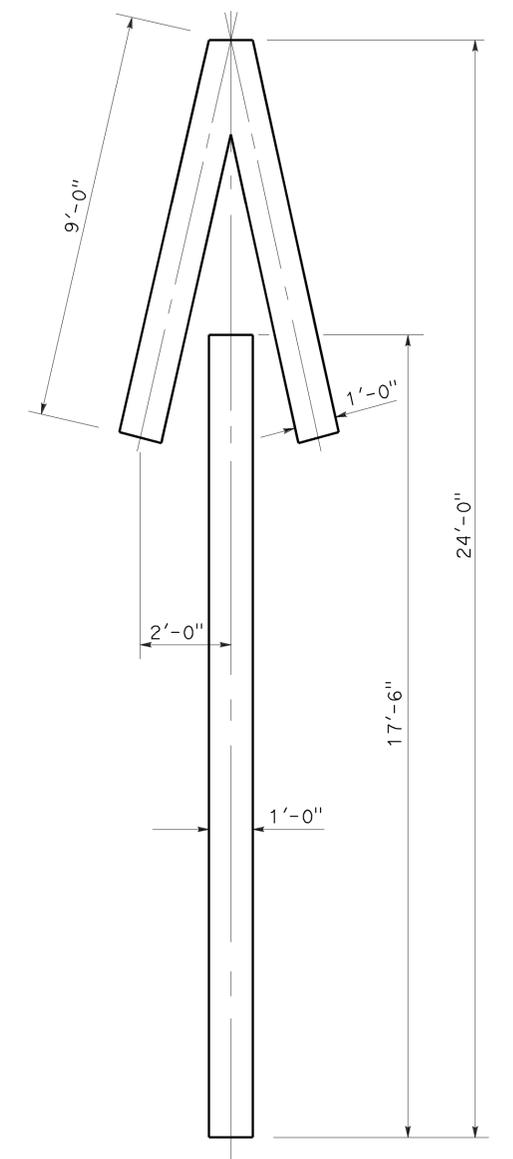

TYPE V ARROW
A=33 ft²

NOTE:
Minor variations in dimensions may be accepted by the Engineer.


STATE OF CALIFORNIA
DEPARTMENT OF TRANSPORTATION
**PAVEMENT MARKINGS
ARROWS**
NO SCALE

RSP A24A DATED APRIL 20, 2012 SUPERSEDES STANDARD PLAN A24A DATED MAY 20, 2011 - PAGE 13 OF THE STANDARD PLANS BOOK DATED 2010.


REVISED STANDARD PLAN RSP A24A

2010 REVISED STANDARD PLAN RSP A24A


TO ACCOMPANY PLANS DATED 1-26-15

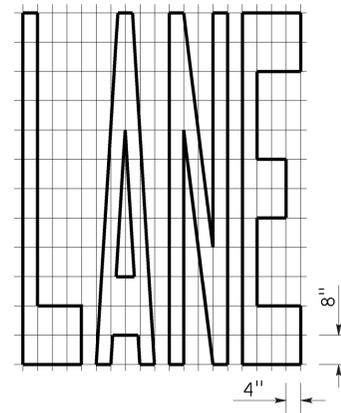


A=24 ft²

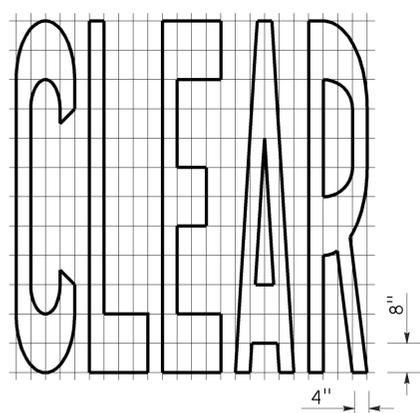


A=27 ft²

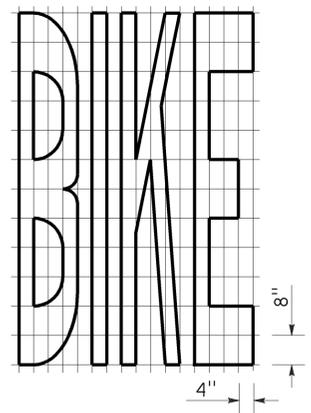


A=21 ft²

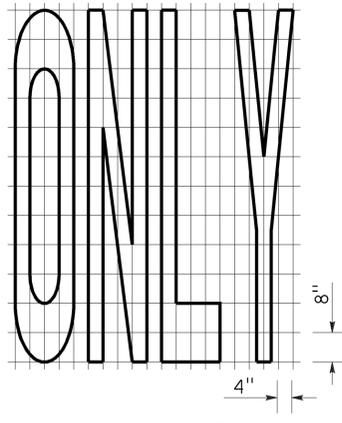


A=22 ft²

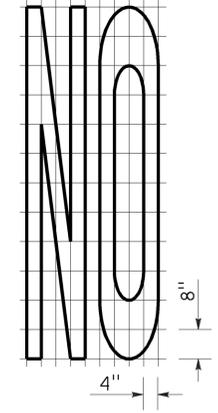


A=14 ft²

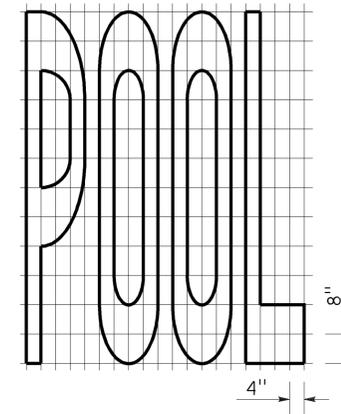


A=23 ft²

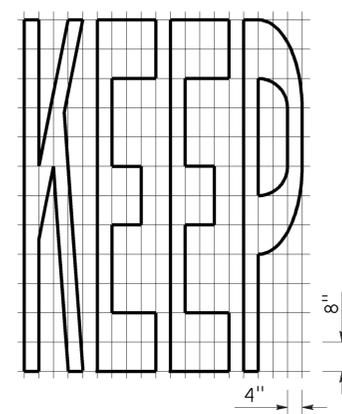


A=24 ft²

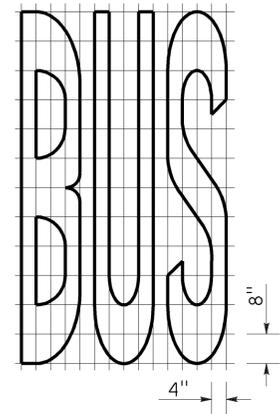

A=20 ft²


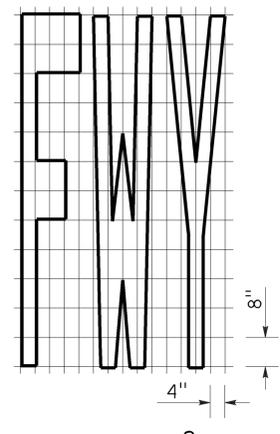


A=16 ft²

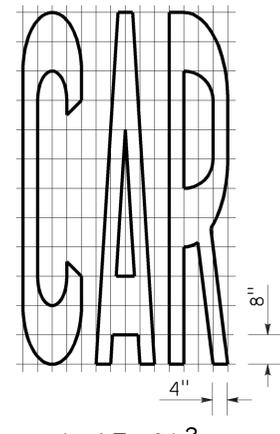


A=17 ft²


WORD MARKINGS			
ITEM	ft ²	ITEM	ft ²
LANE	24	NO	14
POOL	23	BIKE	21
CAR	17	BUS	20
CLEAR	27	ONLY	22
KEEP	24	FWY	16

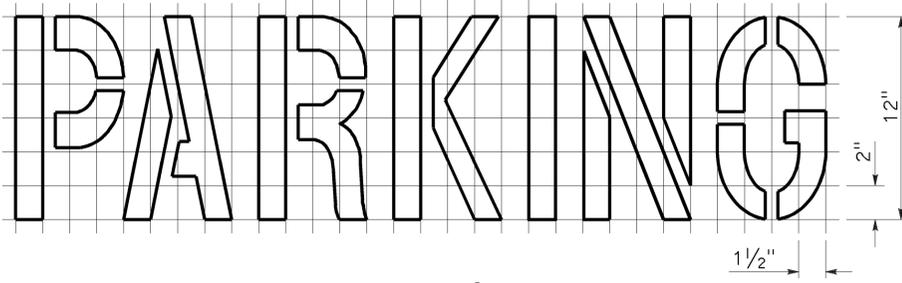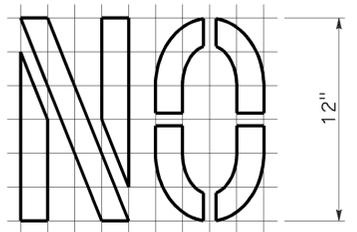

A=2 ft²
See Notes 6 and 7

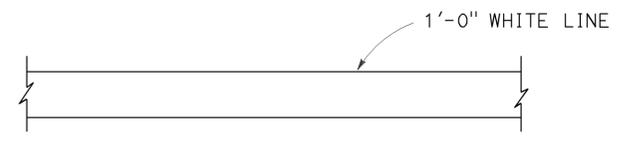

LIMIT LINE (STOP LINE)

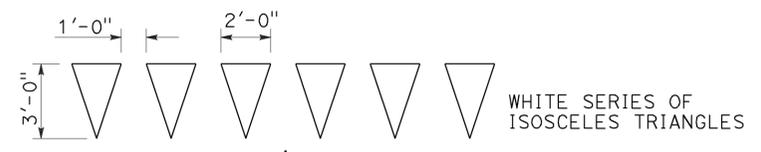

DIRECTION OF TRAVEL
YIELD LINE

NOTES:

1. If a message consists of more than one word, it should read "UP", i.e., the first word should be nearest the driver.
2. The space between words should be at least four times the height of the characters for low speed roads, but not more than ten times the height of the characters. The space may be reduced appropriately where there is limited space because of local conditions.
3. Minor variations in dimensions may be accepted by the Engineer.
4. Portions of a letter, number or symbol may be separated by connecting segments not to exceed 2" in width.
5. The words "NO PARKING" pavement marking is to be used for parking facilities. For typical locations of markings, see Standard Plans A90A and A90B.
6. The words "NO PARKING", shall be painted in white letters no less than 1'-0" high on a contrasting background and located so that it is visible to traffic enforcement officials.


STATE OF CALIFORNIA
DEPARTMENT OF TRANSPORTATION

**PAVEMENT MARKINGS
WORDS, LIMIT AND YIELD LINES**





NO SCALE

RSP A24E DATED JULY 20, 2012 SUPERSEDES STANDARD PLAN A24E
DATED MAY 20, 2011 - PAGE 17 OF THE STANDARD PLANS BOOK DATED 2010.

DIST	COUNTY	ROUTE	POST MILES TOTAL PROJECT	SHEET No.	TOTAL SHEETS
10	Sta	120	0.0/4.1	17	32

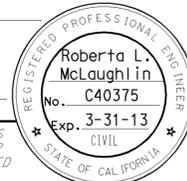 REGISTERED CIVIL ENGINEER		
July 20, 2012 PLANS APPROVAL DATE		
<small>THE STATE OF CALIFORNIA OR ITS OFFICERS OR AGENTS SHALL NOT BE RESPONSIBLE FOR THE ACCURACY OR COMPLETENESS OF SCANNED COPIES OF THIS PLAN SHEET.</small>		


TO ACCOMPANY PLANS DATED 1-26-15

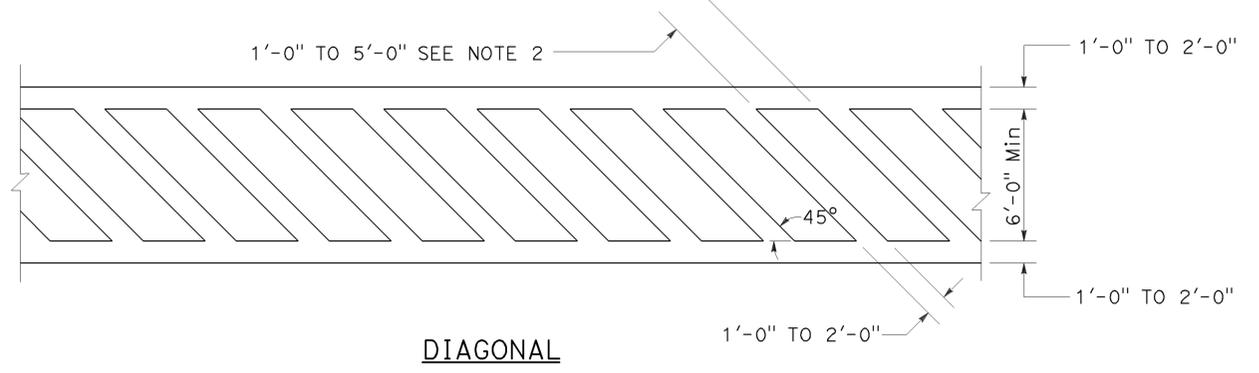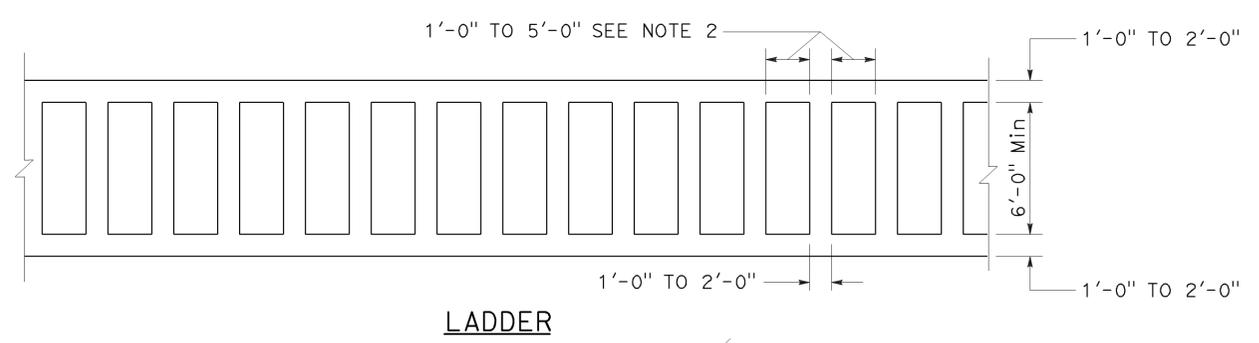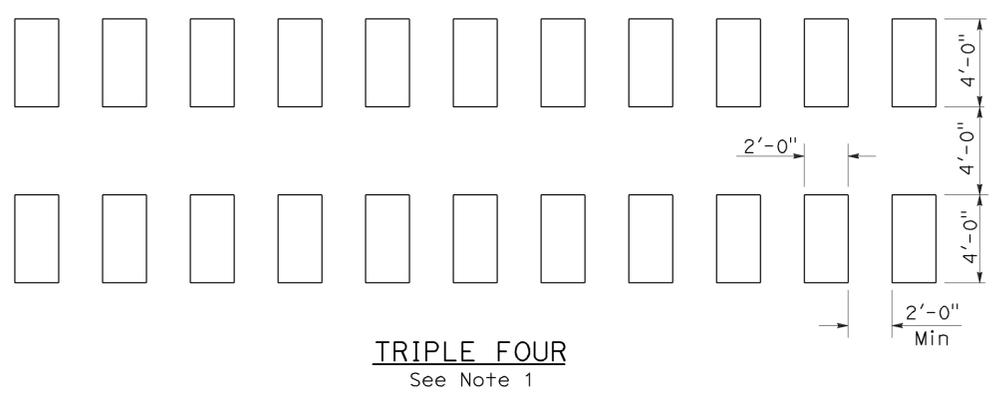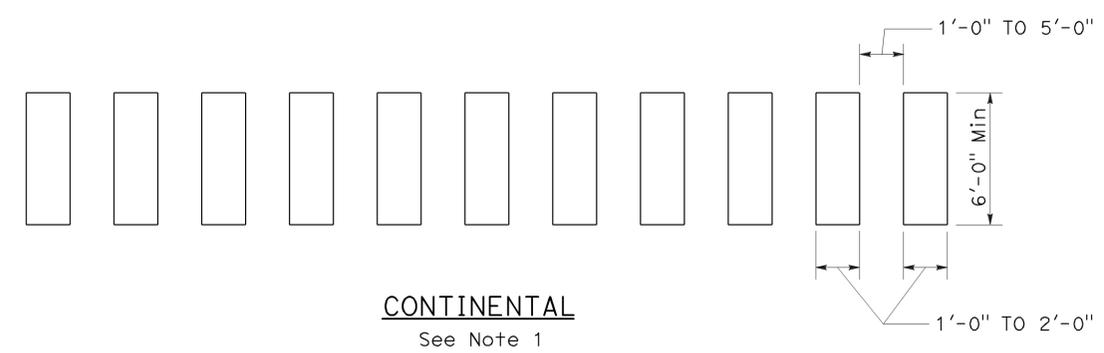

HIGHER VISIBILITY CROSSWALKS

NOTES:

1. Spaces between markings should be placed in wheel tracks of each lane.
2. Spacings not to exceed 2.5 times width of longitudinal line.
3. All crosswalk markings must be white except for those near schools must be yellow.

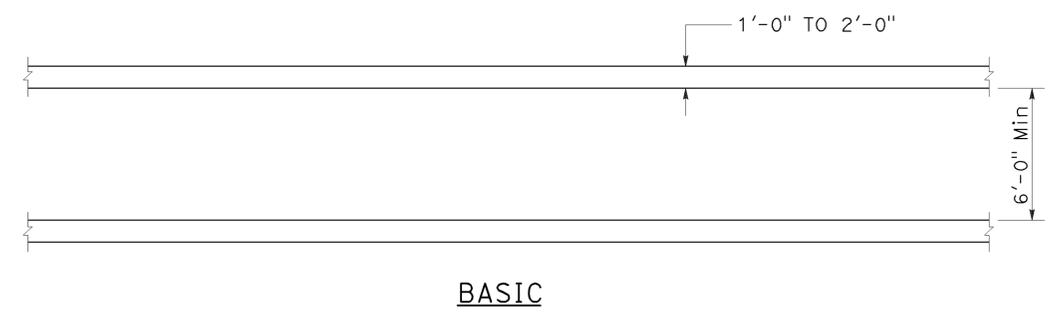


BASIC

STATE OF CALIFORNIA
DEPARTMENT OF TRANSPORTATION
**PAVEMENT MARKINGS
CROSSWALKS**


NO SCALE
RSP A24F DATED JULY 20, 2012 SUPPLEMENTS THE
STANDARD PLANS BOOK DATED 2010.




TO ACCOMPANY PLANS DATED 1-26-15

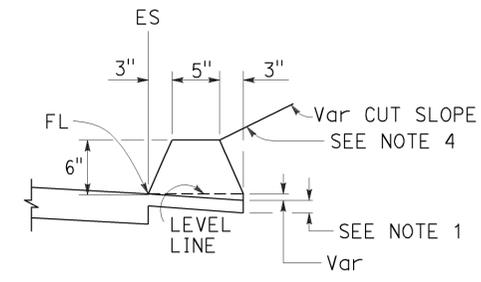


TYPE A
See Note 3

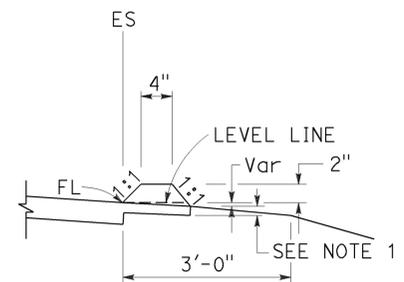


TYPE C

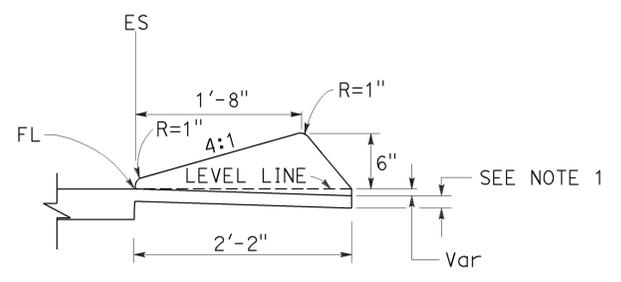

TYPE D

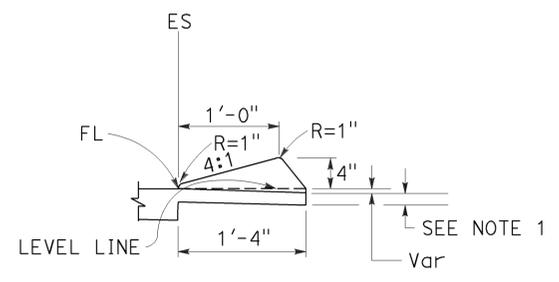


TYPE E

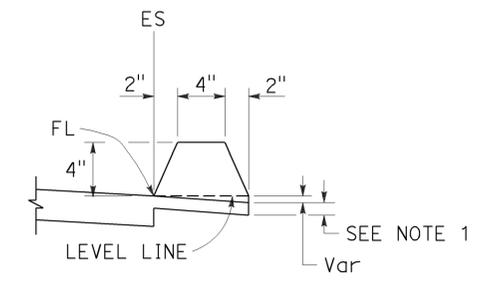


TYPE F
See Note 5


DIKES

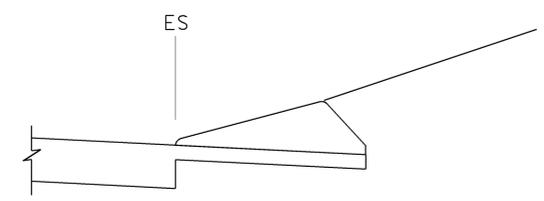


CASE C-1
Cut Slope

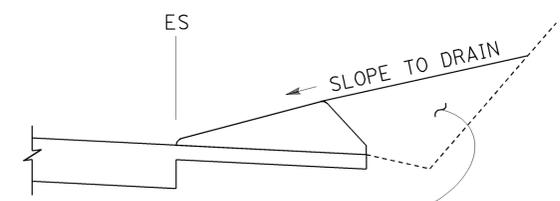

CASE C-2
Cut Slope

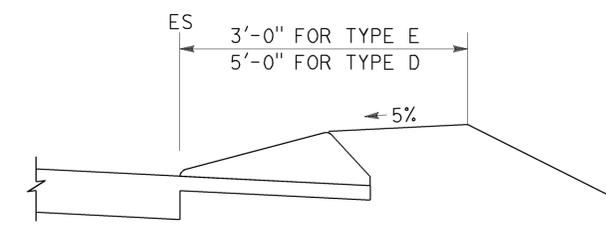

CASE F

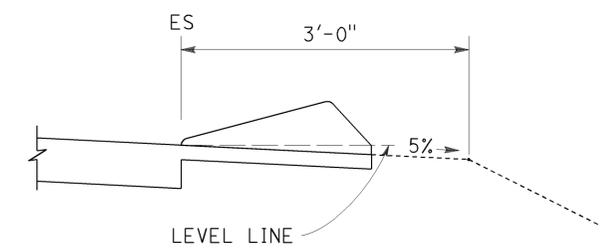

CASE R
See Note 2

TYPE D AND E BACKFILL DETAILS

NOTES:

1. For HMA shoulders only, extend top layer of HMA placed on the shoulder under dike with no joint at the ES. For projects with OGFC shoulders, do not extend OGFC under dike. See project plans for modified dike detail.
2. Case R applies to retrofit only projects where restrictive conditions do not provide enough width for Case F backfill.
3. Type A dike only to be used where restrictive slope conditions do not provide enough width to use Type D or Type E dike.
4. Fill and compact with excavated material to top of dike.
5. Use Type F dike, where dike is required with guard railing installations. See Revised Standard Plan RSP A77N4 for dike positioning details.

DIKE QUANTITIES

TYPE	CUBIC YARDS PER LINEAR FOOT
A	0.0135
C	0.0038
D	0.0293
E	0.0130
F	0.0066

Quantities based on 5% cross slope.

STATE OF CALIFORNIA
DEPARTMENT OF TRANSPORTATION

HOT MIX ASPHALT DIKES

NO SCALE

RSP A87B DATED JULY 19, 2013 SUPERSEDES STANDARD PLAN A87B
DATED MAY 20, 2011 - PAGE 120 OF THE STANDARD PLANS BOOK DATED 2010.

REVISED STANDARD PLAN RSP A87B

2010 REVISED STANDARD PLAN RSP A87B


Dist	COUNTY	ROUTE	POST MILES TOTAL PROJECT	SHEET No.	TOTAL SHEETS
10	Sta	120	0.0/4.1	19	32

H. David Cordova
REGISTERED CIVIL ENGINEER


March 21, 2014
PLANS APPROVAL DATE

THE STATE OF CALIFORNIA OR ITS OFFICERS OR AGENTS SHALL NOT BE RESPONSIBLE FOR THE ACCURACY OR COMPLETENESS OF SCANNED COPIES OF THIS PLAN SHEET.


Hector David Cordova
REGISTERED PROFESSIONAL ENGINEER
No. C41957
Exp. 3-31-14
CIVIL
STATE OF CALIFORNIA

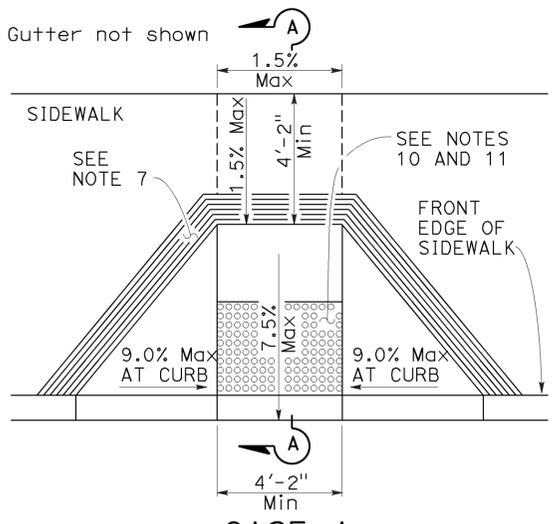


CASE A

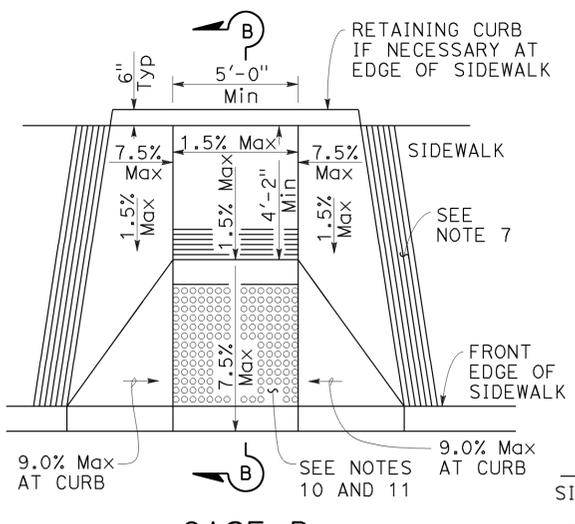


CASE B

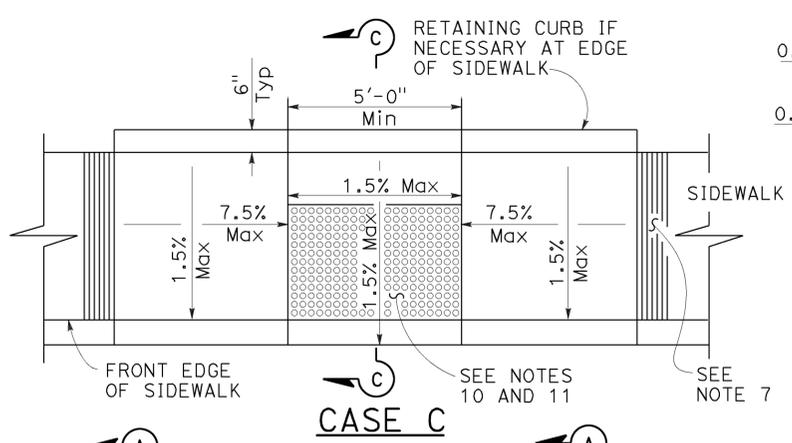


CASE C

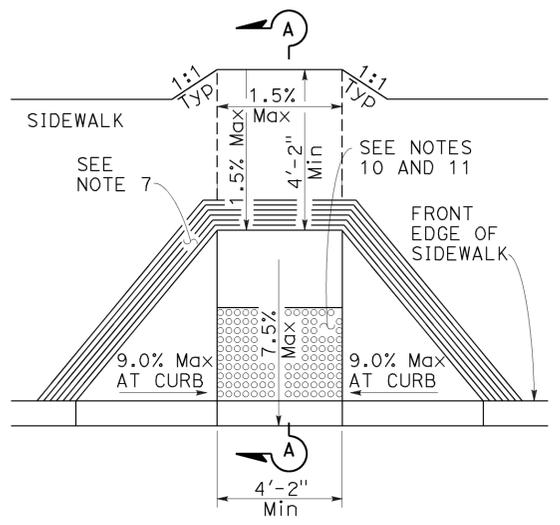


CASE D

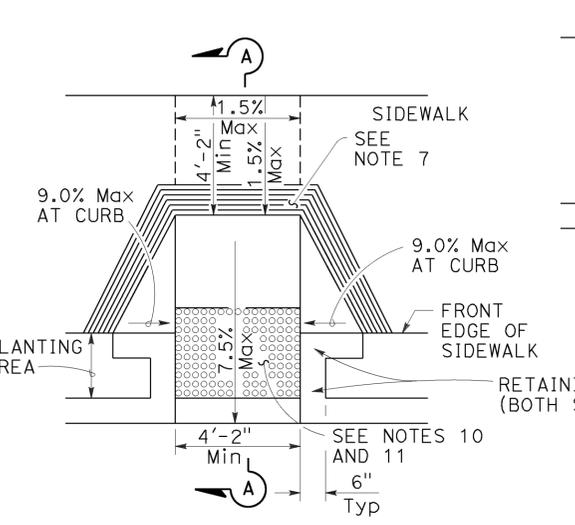


CASE E

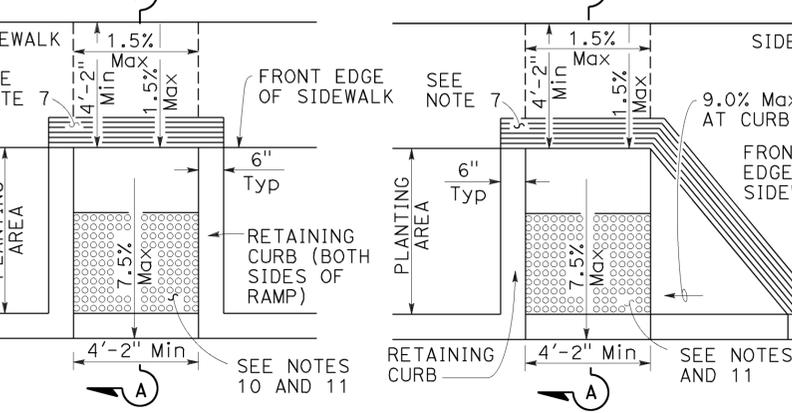

CASE F

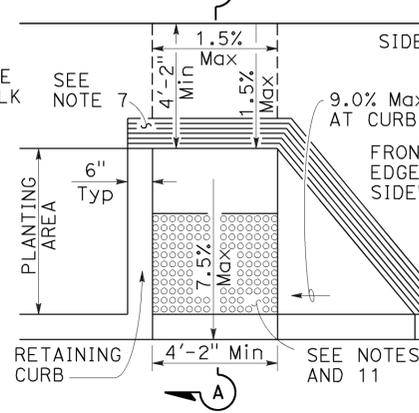


CASE G

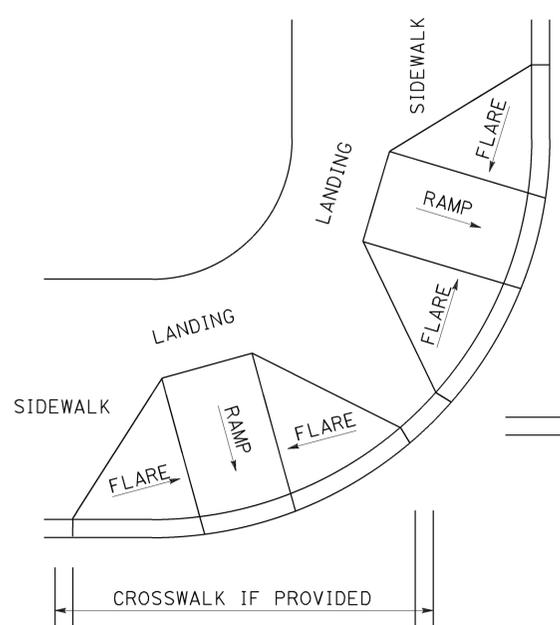

DETAIL A

TYPICAL TWO-RAMP CORNER INSTALLATION


See Note 1

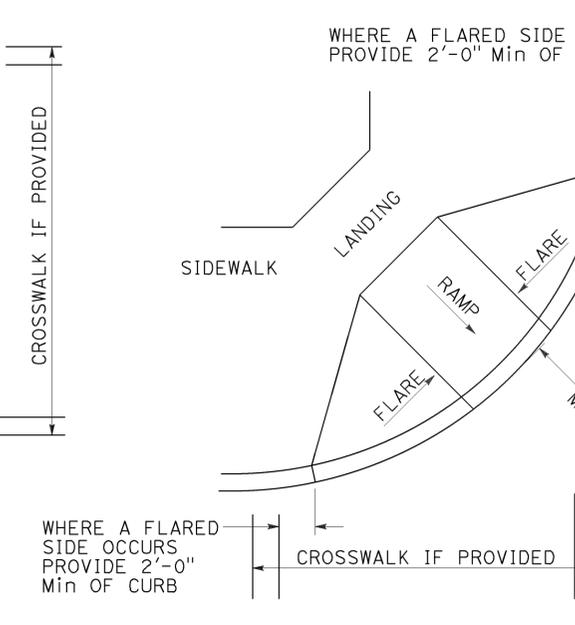


DETAIL B

TYPICAL ONE-RAMP CORNER INSTALLATION


See Notes 1 and 3

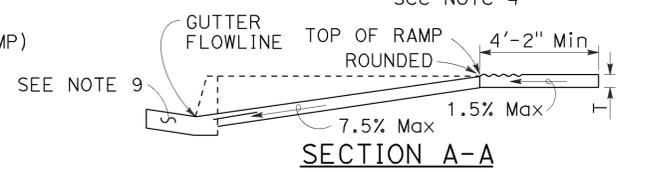


SECTION A-A

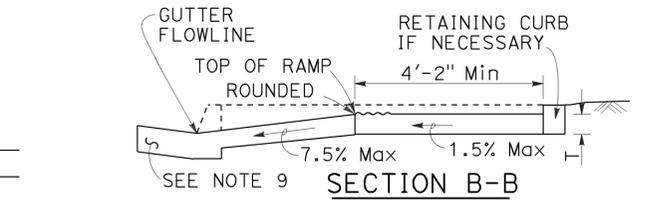


SECTION B-B

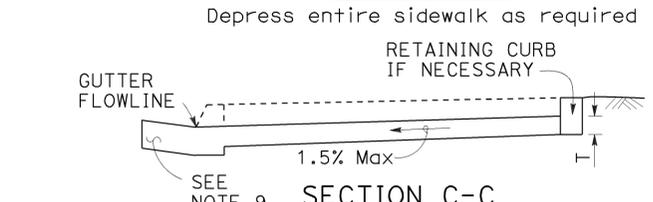


SECTION C-C

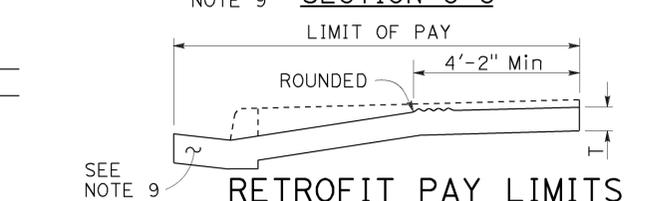

RETROFIT PAY LIMITS

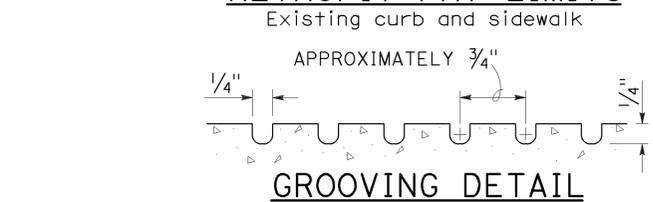

GROOVING DETAIL

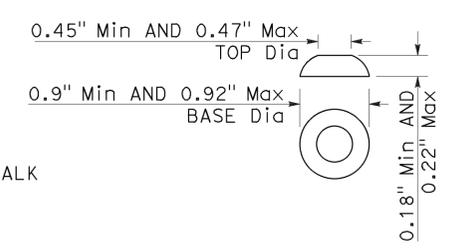

RAISED TRUNCATED DOME

NOTES:

- As site conditions dictate, Case A through Case G curb ramps may be used for corner installations similar to those shown in Detail A and Detail B. The case of curb ramps used in Detail A do not have to be the same. Case A through Case G curb ramps also may be used at mid block locations, as site conditions dictate.
- If distance from curb to back of sidewalk is too short to accommodate ramp and 4'-2" platform (landing) as shown in Case A, the sidewalk may be depressed longitudinally as in Case B, or C or may be widened as in Case D.
- When ramp is located in center of curb return, crosswalk configuration must be similar to that shown for Detail B.
- As site conditions dictate, the retaining curb side and the flared side of the Case G ramp shall be constructed in reversed position.
- If located on a curve, the sides of the ramp need not be parallel, but the minimum width of the ramp shall be 4'-2".
- Side slope of ramp flares vary uniformly from a maximum of 9.0% at curb to conform with longitudinal sidewalk slope adjacent to top of the ramp, except in Case C and Case F.
- The curb ramp shall be outlined, as shown, with a 1'-0" wide border with 1/4" grooves approximately 3/4" on center. See grooving detail.
- Transitions from ramps and landing to walks, gutters or streets shall be flush (no lip) and free of abrupt changes.
- Counter slopes of adjoining gutters and road surfaces immediately adjacent to and within 24 inches of the curb ramp shall not be steeper than 1:20 (5.0%). Gutter pan slope shall not exceed 1" of depth for each 2'-0" of width.
- Curb ramps shall have a detectable warning surface that extends the full width and 3'-0" depth of the ramp. A 4'-0" wide detectable warning surface may be used on a 4'-2" wide curb ramp. Detectable Warning Surfaces shall conform to the requirements in the Standard Specifications.
- The edge of the detectable warning surface nearest the street shall be between 6" and 8" from the gutter flowline.
- Sidewalk and ramp thickness, "T", shall be 3/2" minimum.
- Utility pull boxes, manholes, vaults and all other utility facilities within the boundaries of the curb ramp will be relocated or adjusted to grade by the owner prior to, or in conjunction with, curb ramp construction.
- Detectable warning surface may have to be cut to allow removal of utility covers while maintaining full detectable warning width and depth.



RAISED TRUNCATED DOME PATTERN (IN-LINE) DETECTABLE WARNING SURFACE

See Note 10

CURB RAMP DETAILS
NO SCALE

RSP A88A DATED MARCH 21, 2014 SUPERSEDES RSP A88A DATED JULY 19, 2013 AND STANDARD PLAN A88A DATED MAY 20, 2011 - PAGE 121 OF THE STANDARD PLANS BOOK DATED 2010.

2010 REVISED STANDARD PLAN RSP A88A

Dist	COUNTY	ROUTE	POST MILES TOTAL PROJECT	SHEET No.	TOTAL SHEETS
10	Sta	120	0.0/4.1	20	32

H. David Cordova
REGISTERED CIVIL ENGINEER

March 21, 2014
PLANS APPROVAL DATE

Hector David Cordova
No. C41957
Exp. 3-31-14
CIVIL
STATE OF CALIFORNIA







THE STATE OF CALIFORNIA OR ITS OFFICERS OR AGENTS SHALL NOT BE RESPONSIBLE FOR THE ACCURACY OR COMPLETENESS OF SCANNED COPIES OF THIS PLAN SHEET.

TO ACCOMPANY PLANS DATED 1-26-15

NOTES:

1. Sidewalk, ramp and passageway thickness, "T", shall be 3 1/2" minimum.
2. For details of grooving used with Case CM curb ramp, see Revised Standard Plan RSP A88A.
3. For details of detectable warning surfaces, see Revised Standard Plan RSP A88A.
4. Where an island passageway length is greater than or equal to 6'-0", but less than 8'-0", each detectable warning surface shall extend the full width and 2'-0" depth of the passageway length. Where an island passageway length is greater than or equal to 8'-0", each detectable warning surface shall extend the full width and 3'-0" depth of the passageway length. A 4'-0" wide detectable warning surface may be used on a 4'-2" wide island passageway.
5. For Case CM curb ramp, the edge of the detectable warning surface nearest the street shall be between 6" and 8" from the gutter flowline.
6. Transitions from ramps to walks, gutters or streets shall be flush (no lip) and free of abrupt changes.
7. Utility pull boxes, manholes, vaults and all other utility facilities within the boundaries of the curb ramp will be relocated or adjusted to grade by the owner prior to, or in conjunction with, curb ramp construction.
8. Detectable warning surface may have to be cut to allow removal of utility covers while maintaining full detectable warning width and depth.
9. For additional curb ramp details, see Revised Standard Plan RSP A88A.

Gutter not shown

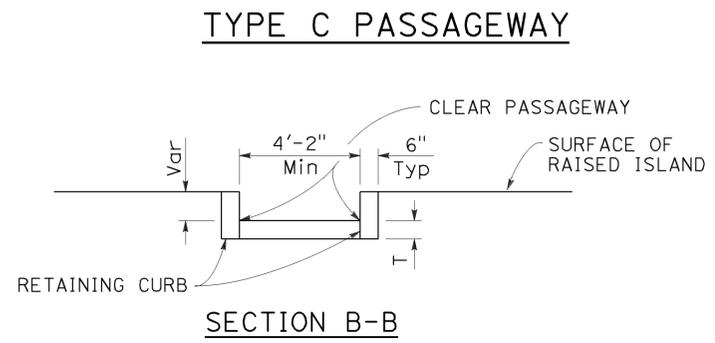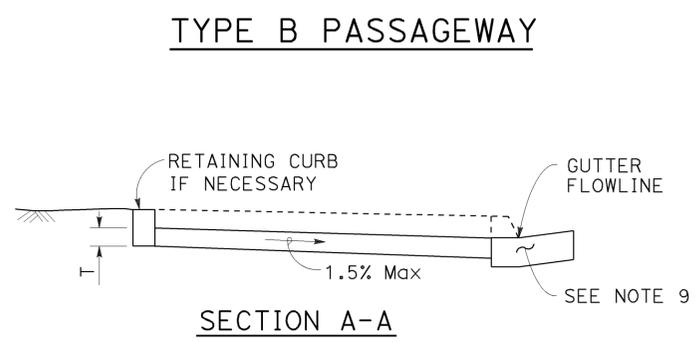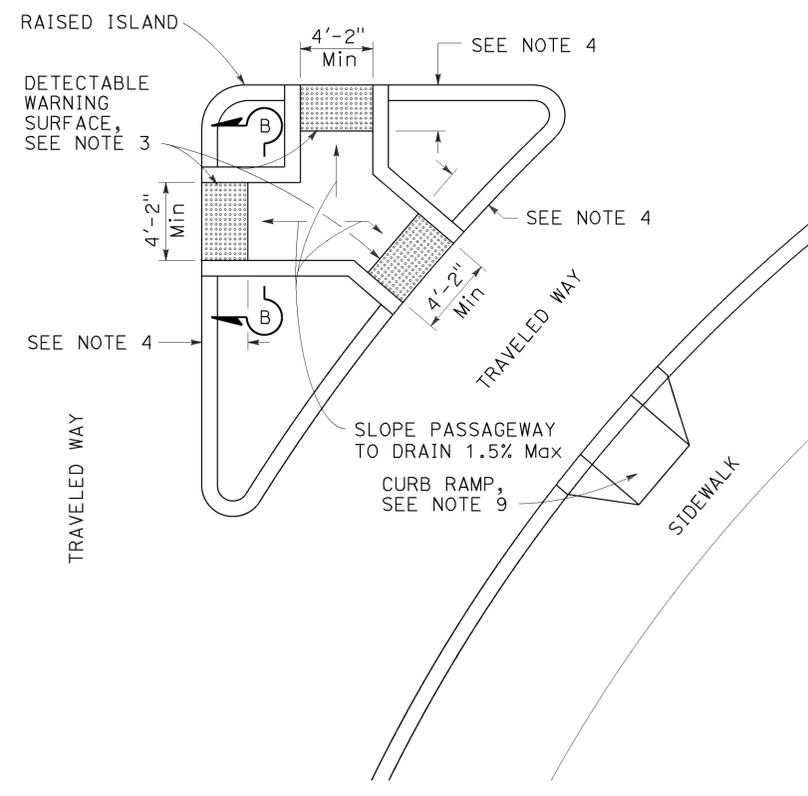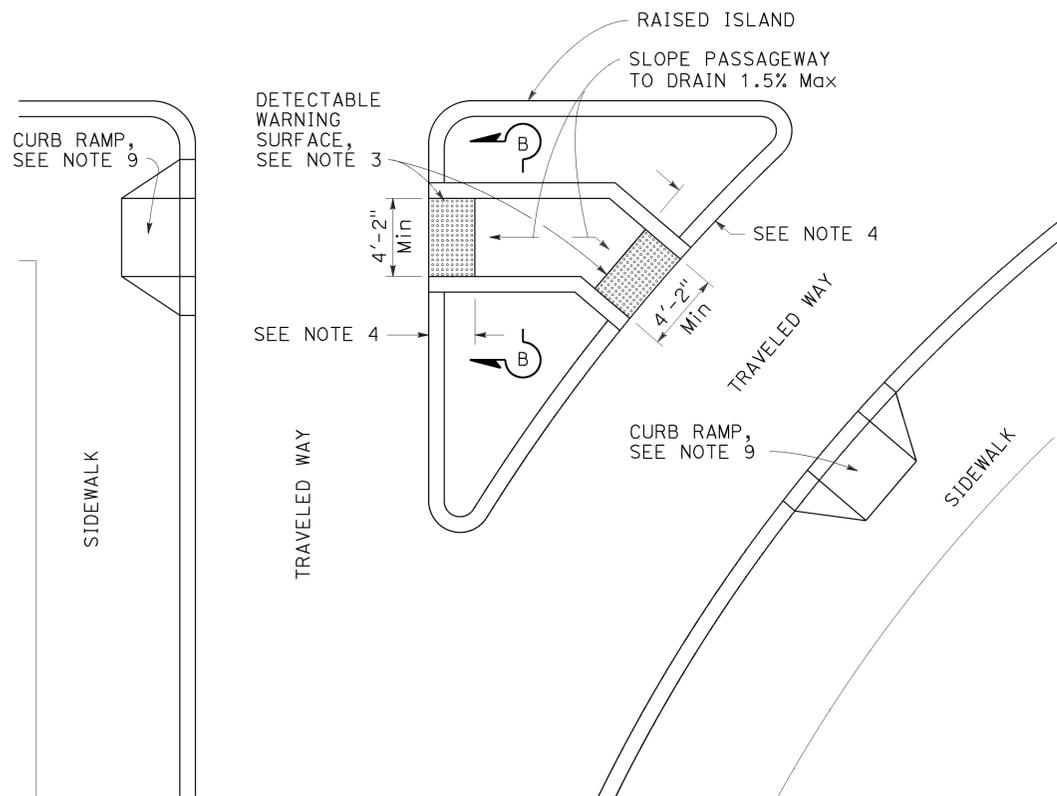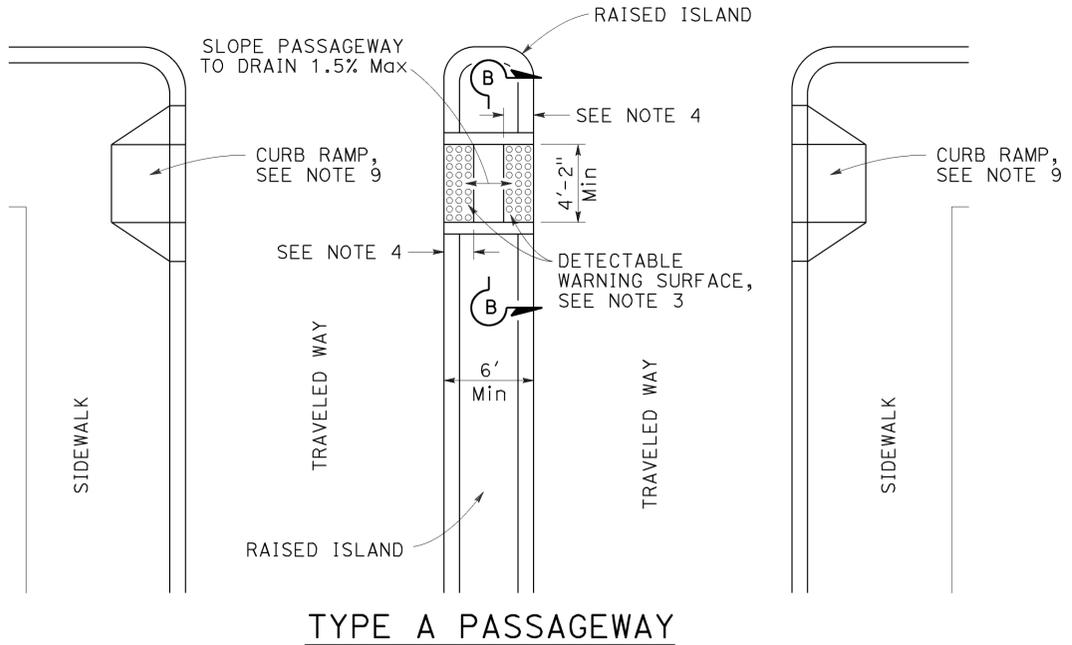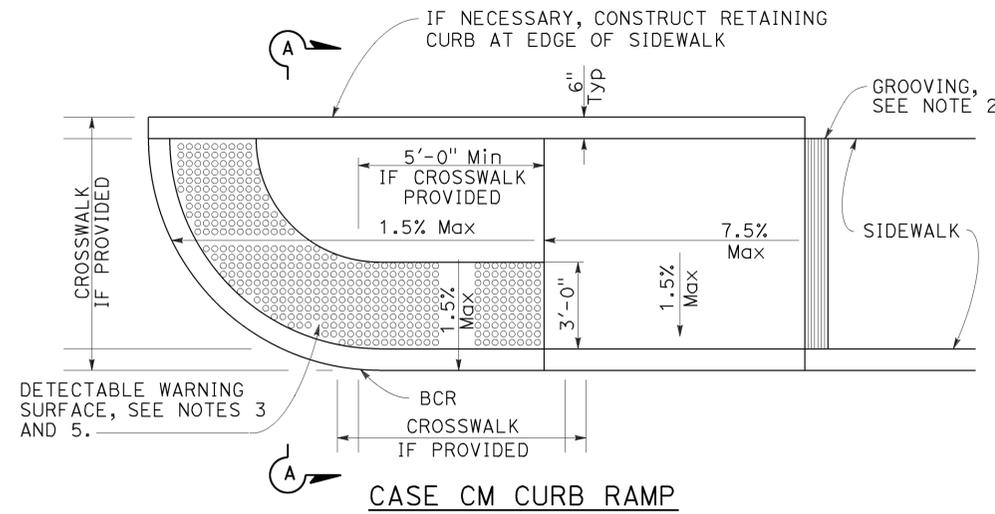

STATE OF CALIFORNIA
DEPARTMENT OF TRANSPORTATION

CURB RAMP AND ISLAND PASSAGEWAY DETAILS

NO SCALE

RSP A88B DATED MARCH 21, 2014 SUPERSEDES RSP A88B DATED JULY 19, 2013 AND STANDARD PLAN A88B DATED MAY 20, 2011 - PAGE 122 OF THE STANDARD PLANS BOOK DATED 2010.

2010 REVISED STANDARD PLAN RSP A88B

TO ACCOMPANY PLANS DATED 1-26-15

TABLE 1

TAPER LENGTH CRITERIA AND CHANNELIZING DEVICE SPACING							
SPEED (S)	MINIMUM TAPER LENGTH * FOR WIDTH OF OFFSET 12 FEET (W)				MAXIMUM CHANNELIZING DEVICE SPACING		
	TANGENT 2L	MERGING L	SHIFTING L/2	SHOULDER L/3	X	Y	Z **
					TAPER	TANGENT	CONFLICT
mph	ft	ft	ft	ft	ft	ft	ft
20	160	80	40	27	20	40	10
25	250	125	63	42	25	50	12
30	360	180	90	60	30	60	15
35	490	245	123	82	35	70	17
40	640	320	160	107	40	80	20
45	1080	540	270	180	45	90	22
50	1200	600	300	200	50	100	25
55	1320	660	330	220	55	110	27
60	1440	720	360	240	60	120	30
65	1560	780	390	260	65	130	32
70	1680	840	420	280	70	140	35

* - For other offsets, use the following merging taper length formula for L:
 For speed of 40 mph or less, $L = WS^2/60$
 For speed of 45 mph or more, $L = WS$

Where: L = Taper length in feet
 W = Width of offset in feet
 S = Posted speed limit, off-peak 85th-percentile speed prior to work starting, or the anticipated operating speed in mph

** - Use for taper and tangent sections where there are no pavement markings or where there is a conflict between existing pavement markings and channelizers (CA).

TABLE 2

LONGITUDINAL BUFFER SPACE AND FLAGGER STATION SPACING				
SPEED *	Min D **	DOWNGRADE Min D ***		
		-3%	-6%	-9%
		ft	ft	ft
20	115	116	120	126
25	155	158	165	173
30	200	205	215	227
35	250	257	271	287
40	305	315	333	354
45	360	378	400	427
50	425	446	474	507
55	495	520	553	593
60	570	598	638	686
65	645	682	728	785
70	730	771	825	891

* - Speed is posted speed limit, off-peak 85th-percentile speed prior to work starting, or the anticipated operating speed in mph
 ** - Longitudinal buffer space or flagger station spacing
 *** - Use on sustained downgrade steeper than -3 percent and longer than 1 mile.

TABLE 3

ADVANCE WARNING SIGN SPACING			
ROAD TYPE	DISTANCE BETWEEN SIGNS *		
	A	B	C
	ft	ft	ft
URBAN - 25 mph OR LESS	100	100	100
URBAN - MORE THAN 25 mph TO 40 mph	250	250	250
URBAN - MORE THAN 40 mph	350	350	350
RURAL	500	500	500
EXPRESSWAY / FREEWAY	1000	1500	2640

* - The distances are approximate, are intended for guidance purposes only, and should be applied with engineering judgment. These distances should be adjusted by the Engineer for field conditions, if necessary, by increasing or decreasing the recommended distances.

STATE OF CALIFORNIA
 DEPARTMENT OF TRANSPORTATION

TRAFFIC CONTROL SYSTEM TABLES FOR LANE AND RAMP CLOSURES

NO SCALE

RSP T9 DATED JULY 19, 2013 SUPERSEDES RSP T9 DATED APRIL 19, 2013 THAT SUPPLEMENTS THE STANDARD PLANS BOOK DATED 2010.

2010 REVISED STANDARD PLAN RSP T9

NOTES:

See Revised Standard Plan RSP T9 for tables.

Use cone spacing X for taper segment, Y for tangent segment or Z for conflict situations, as appropriate, per Table 1, unless X, Y, or Z cone spacing is shown on this sheet.

Unless otherwise specified in the special provisions, all temporary warning signs shall have black legend on fluorescent orange background.

California codes are designated by (CA). Otherwise, Federal (MUTCD) codes are shown.

Dist	COUNTY	ROUTE	POST MILES TOTAL PROJECT	SHEET No.	TOTAL SHEETS
10	Sta	120	0.0/4.1	22	32

Devinder Singh
REGISTERED CIVIL ENGINEER


October 17, 2014
PLANS APPROVAL DATE

Devinder Singh
No. C50470
Exp. 6-30-15
CIVIL
STATE OF CALIFORNIA

THE STATE OF CALIFORNIA OR ITS OFFICERS OR AGENTS SHALL NOT BE RESPONSIBLE FOR THE ACCURACY OR COMPLETENESS OF SCANNED COPIES OF THIS PLAN SHEET.


TYPICAL LANE CLOSURE WITH REVERSIBLE CONTROL

TO ACCOMPANY PLANS DATED 1-26-15

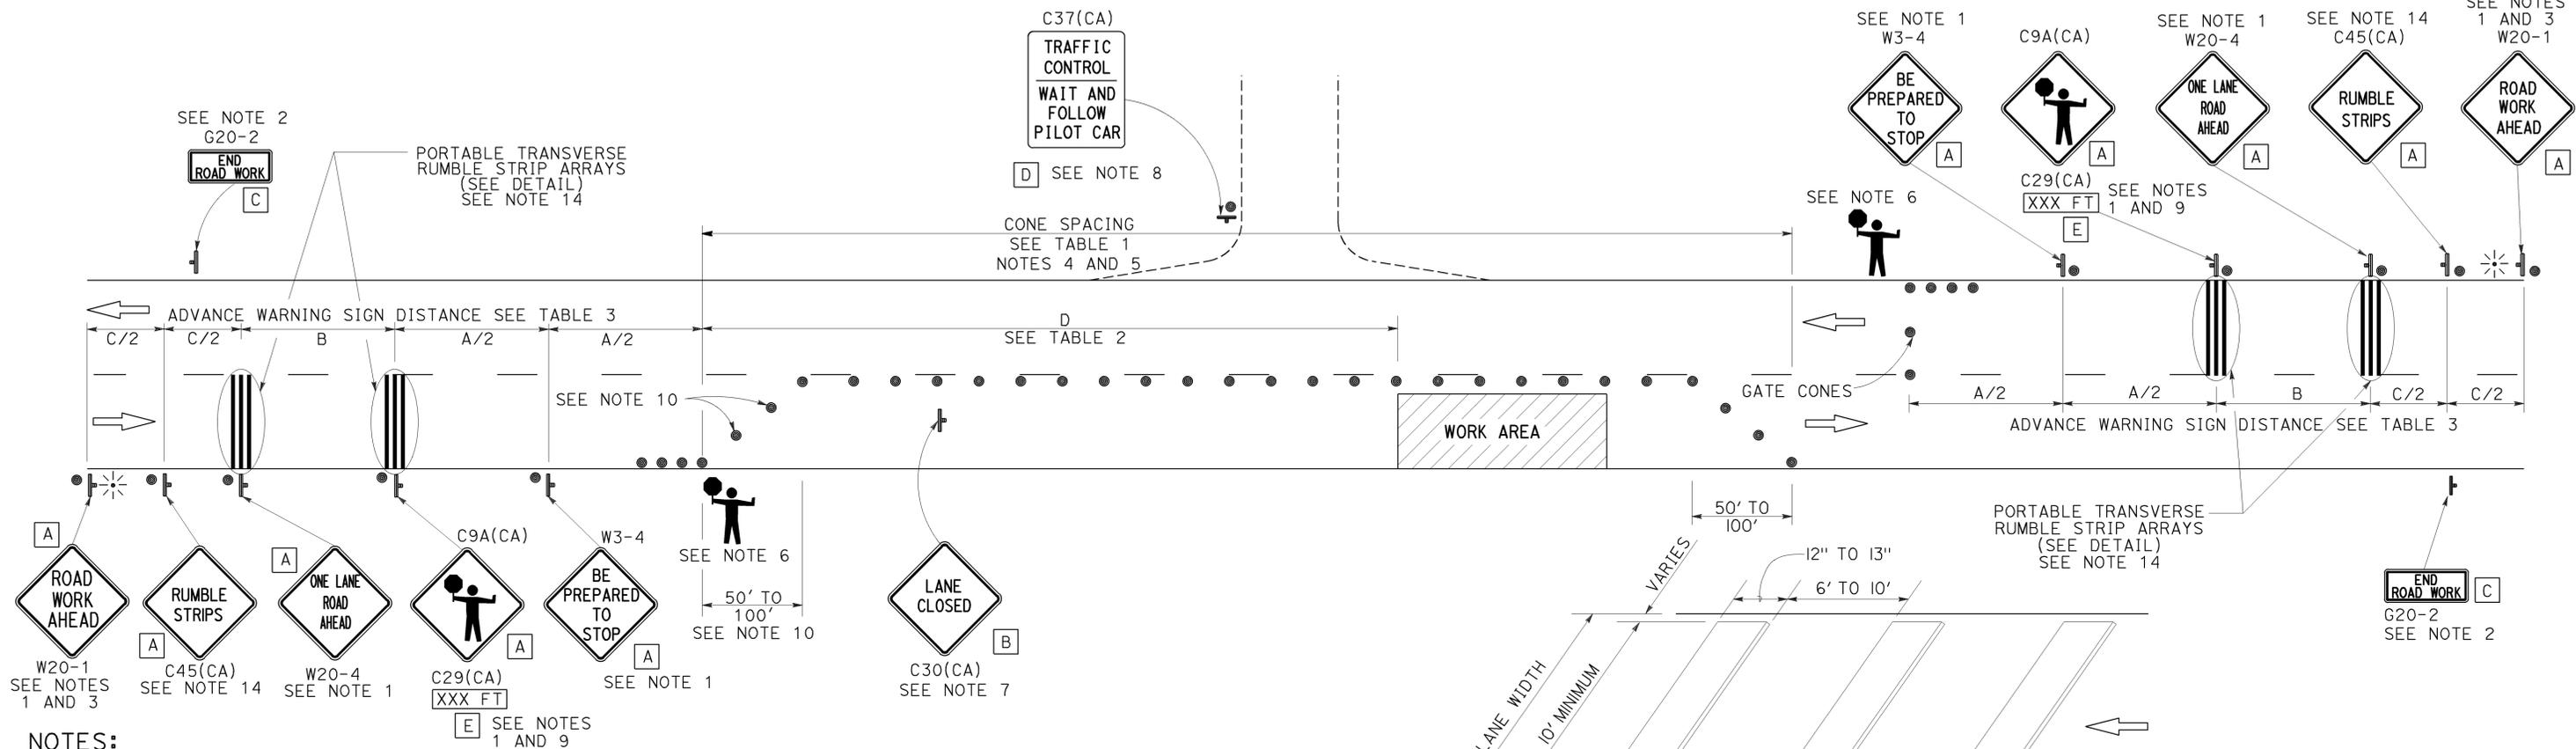

NOTES:

- Each advance warning sign in each direction of travel shall be equipped with at least two flags for daytime closure. Each flag shall be at least 16" x 16" in size and shall be orange or fluorescent red-orange in color. Flashing beacons shall be placed at the locations indicated for lane closure during hours of darkness.
- A G20-2 "END ROAD WORK" sign, as appropriate, shall be placed at the end of the lane control unless the end of work area is obvious, or ends within a larger project's limits.
- If the W20-1 sign would follow within 2000' of a stationary W20-1 or G20-1 "ROAD WORK NEXT _____ MILES", use a W20-4 sign for the first advance warning sign.
- All cones used for lane closures during the hours of darkness shall be fitted with retroreflective bands (or sleeves) as specified in the specifications.
- Portable delineators, placed at one-half the spacing indicated for traffic cones, may be used instead of cones for daytime closures only.
- Additional advance flaggers may be required. Flagger should stand in a conspicuous place, be visible to approaching traffic as well as approaching vehicles after the first vehicle has stopped. During the hours of darkness, the flagging-station and flagger shall be illuminated and clearly visible to approaching traffic. The illumination footprint of the lighting on the ground shall be at least 20' in diameter. Place a minimum of four cones at 50' intervals in advance of flagger station as shown.
- Place C30(CA) "LANE CLOSED" sign at 500' to 1000' intervals throughout extended work areas. They are optional if the work area is visible from the flagger station.
- When a pilot car is used, place a C37(CA) "TRAFFIC CONTROL-WAIT AND FOLLOW PILOT CAR" sign with black legend on white background at all intersections, driveways and alleys without a flagger within traffic control area. Signs shall be clean and visible at all times. Where traffic can not be effectively self-regulated, at least one flagger shall be used at each intersection within traffic control area.
- An optional C29(CA) sign may be placed below the C9A(CA) sign.
- Either traffic cones or barricades shall be placed on the taper. Barricades shall be Type I, II, or III.
- The color of the portable transverse rumble strips shall be black or orange. Use 2 arrays, each array shall consist of 3 rumble strips.
- Portable transverse rumble strips shall not be placed on sharp horizontal or vertical curves nor shall they be placed through pedestrian crossings.
- If the portable transverse rumble strips become out of alignment (skewed) by more than 6 inches, measured from one end to the other, they shall be readjusted to bring the placement back to the original location.
- Portable transverse rumble strips are not required if any one of the following conditions is satisfied:
 - Work duration occupies a location for four hours or less
 - Posted speed limit is below 45 MPH
 - Work is of emergency nature
 - Work zone is in snow or icy weather conditions

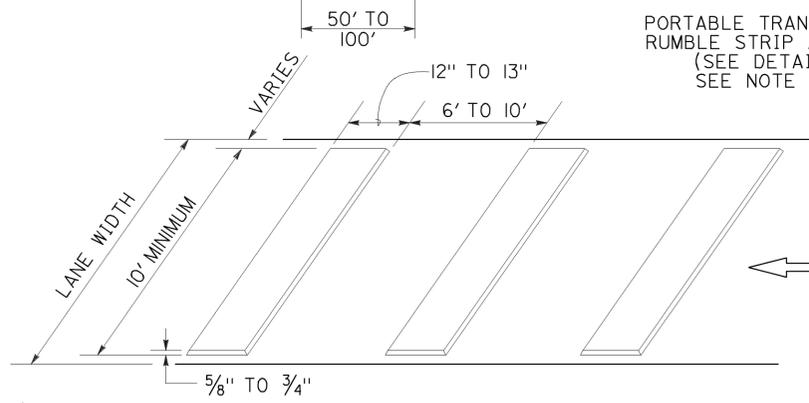

SIGN PANEL SIZE (Min)

- A 48" x 48"
- B 30" x 30"
- C 36" x 18"
- D 36" x 42"
- E 20" x 7"

LEGEND

- TRAFFIC CONE
- ⊥ TEMPORARY TRAFFIC CONTROL SIGN
- ⚡ PORTABLE FLASHING BEACON
- 🚧 FLAGGER

STATE OF CALIFORNIA
DEPARTMENT OF TRANSPORTATION

**TRAFFIC CONTROL SYSTEM
FOR LANE CLOSURE ON
TWO LANE CONVENTIONAL
HIGHWAYS**


NO SCALE

RSP T13 DATED OCTOBER 17, 2014 SUPERSEDES RSP T13 DATED JULY 18, 2014
AND RSP T13 DATED APRIL 19, 2013 AND STANDARD PLAN T13 DATED
MAY 20, 2011 - PAGE 241 OF THE STANDARD PLANS BOOK DATED 2010.

REVISED STANDARD PLAN RSP T13

2010 REVISED STANDARD PLAN RSP T13

TO ACCOMPANY PLANS DATED 1-26-15

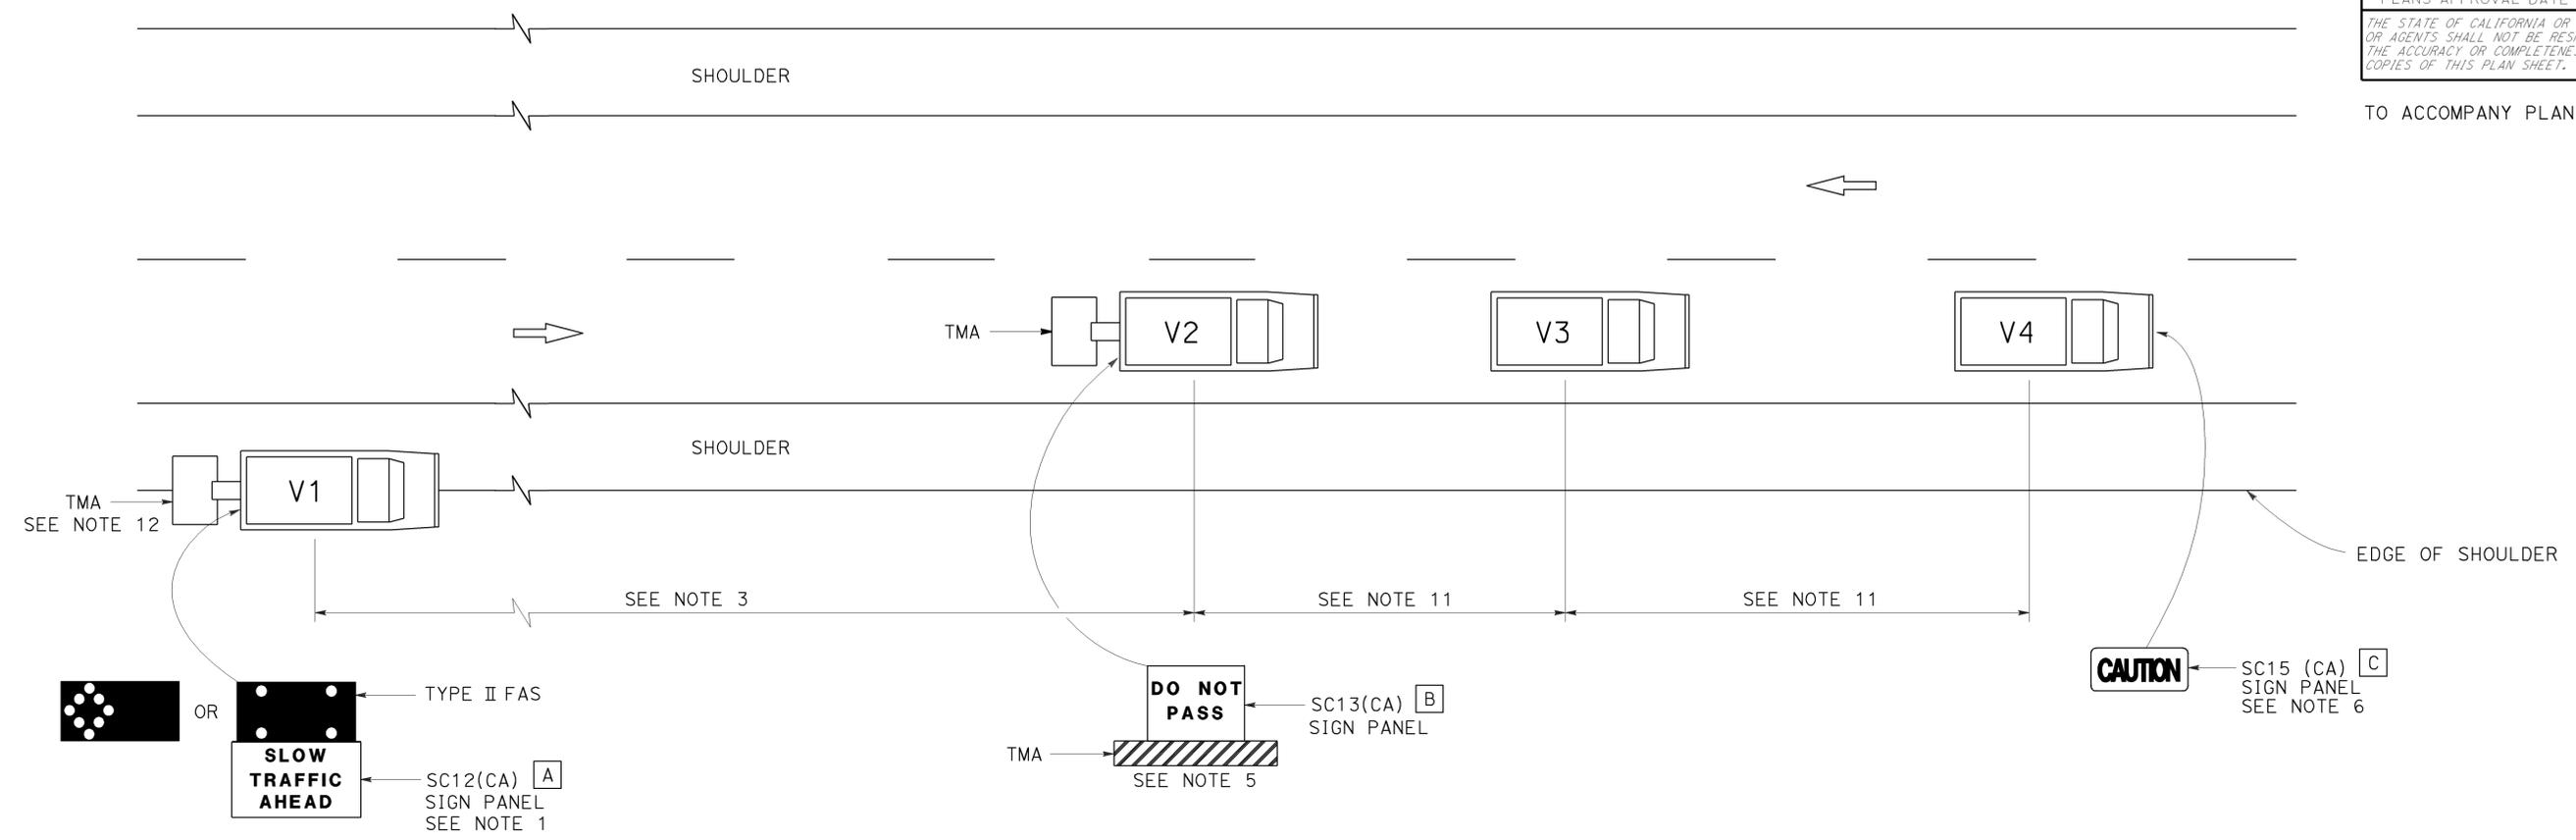

NOTES:

1. Either a changeable message sign or a SC12(CA) "SLOW TRAFFIC AHEAD" sign shall be mounted on the rear of sign vehicle V1. The changeable message sign shall be sequenced to show the "CAUTION" message first, follow by the "SLOW TRAFFIC AHEAD" message. A Type II flashing arrow sign may be used with the SC12(CA) sign panel.
2. Sign vehicle V1 should be positioned where highly visible when shoulders are not available.
3. If traffic queues develop, sign vehicle V1 should be positioned upstream from the end of queue.
4. Vehicle-mounted sign panels shall have Type III or above retroreflective sheeting, black on white, or black on fluorescent orange, with 6" minimum series D letters per Caltrans sign specifications.
5. Shadow vehicle shall be equipped with a truck-mounted attenuator. The sign panel shown shall be mounted on the rear of shadow vehicle V2. The message "LANE CLOSED" may be used in place of the "DO NOT PASS" message.
6. The sign panel shown shall be mounted on the front of sign vehicle V4, facing opposing traffic.
7. All vehicles shall be equipped with flashing or rotating amber lights.
8. Sign vehicle V4 will not be required when the work and vehicles V2 and V3 are 2' or more from the centerline of the highway during the work or application operations.
9. All vehicles used for lane closures shall be equipped with two-way radios and the vehicle operators shall maintain communication during the work or application operation.
10. This plan shall not be used where workers would be on foot in the work area. Use a stationary type lane closure (Revised Standard Plan T13) for this condition.
11. Minimize spacing between vehicles V2 and V3 and vehicles V3 and V4 to deter road users from driving in between them.
12. If sign vehicle V1 encroaches into the traffic lane due to insufficient shoulder width, sign vehicle V1 shall be equipped with a truck-mounted attenuator. Sign vehicle V1 shall stay as close to the edge of shoulder as practicable.

LEGEND

- V1 SIGN VEHICLE
- V2 SHADOW VEHICLE
- V3 WORK/APPLICATION VEHICLE
- V4 SIGN VEHICLE
- TMA TRUCK-MOUNTED ATTENUATOR
-  FLASHING ARROW SIGN (FAS) IN FLASHING CAUTION MODE
-  FLASHING ARROW SIGN (FAS) IN ALTERNATING DIAMOND CAUTION

SIGN PANEL SIZE (Min)

- A 72" x 42"
- B 54" x 42"
- C 54" x 24"

STATE OF CALIFORNIA
 DEPARTMENT OF TRANSPORTATION
**TRAFFIC CONTROL SYSTEM
 FOR MOVING LANE CLOSURE
 ON TWO LANE HIGHWAYS**
 NO SCALE

RSP T17 DATED APRIL 19, 2013 SUPERSEDES STANDARD PLAN T17
 DATED MAY 20, 2011 - PAGE 245 OF THE STANDARD PLANS BOOK DATED 2010.

REVISED STANDARD PLAN RSP T17

2010 REVISED STANDARD PLAN RSP T17

LEGEND:

AB	ABANDON. IF APPLIED TO CONDUIT, REMOVE CONDUCTORS
BC	INSTALL PULL BOX IN EXISTING CONDUIT RUN
BP	PEDESTRIAN BARRICADE, TYPE AS INDICATED ON PLAN
CB	INSTALL CONDUIT INTO EXISTING PULL BOX
CC	CONNECT NEW AND EXISTING CONDUIT. REMOVE EXISTING CONDUCTORS AND INSTALL CONDUCTORS AS INDICATED
CF	CONDUIT TO REMAIN FOR FUTURE USE. REMOVE CONDUCTORS. INSTALL PULL TAPE
DH	DETECTOR HANDHOLE
FA	FOUNDATION TO BE ABANDONED
IS	INSTALL SIGN ON SIGNAL MAST ARM
NS	NO SLIP BASE ON STANDARD
PEC	PHOTOELECTRIC CONTROL
PEU	PHOTOELECTRIC UNIT
RC	EQUIPMENT OR MATERIAL TO BE REMOVED AND BECOME THE PROPERTY OF THE CONTRACTOR
RE	REMOVE ELECTROLIER, FUSES AND BALLAST. TAPE ENDS OF CONDUCTORS
RL	RELOCATE EQUIPMENT
RR	REMOVE AND REUSE EQUIPMENT
RS	REMOVE AND SALVAGE EQUIPMENT
SC	SPLICE NEW TO EXISTING CONDUCTORS
SD	SERVICE DISCONNECT
TSP	TELEPHONE SERVICE POINT

MISCELLANEOUS ELECTROLIERS

<u>NEW</u>	<u>EXISTING</u>	
		LUMINAIRE ON WOOD POLE
		NON-STANDARD ELECTROLIER (SEE PROJECT NOTES OR PROJECT PLANS)
		CITY ELECTROLIER
		ELECTROLIER FOUNDATION (FUTURE INSTALLATION)

NOTES:

- HPS luminaires shall be 310 W HPS when installed on Type 21, 21D, 30, 31 and 32 Standards, unless otherwise specified. HPS luminaires shall be 200 W when installed on other type standards or poles, unless otherwise specified.
- LED luminaires shall be 235 W when installed on Type 21, 21D, 30, 31 and 32 Standards, unless otherwise specified. LED luminaires shall be 165 W when installed on other type standards or poles, unless otherwise specified.
- Luminaires shall be the cutoff type, ANSI Type III medium cutoff lighting distribution, unless otherwise specified.

ABBREVIATIONS

APS	ACCESSIBLE PEDESTRIAN SIGNAL	M/M	MULTIPLE TO MULTIPLE TRANSFORMER
BBS	BATTERY BACKUP SYSTEM	Mtg	MOUNTING
BC	BOLT CIRCLE	MV	MERCURY VAPOR LIGHTING FIXTURE
BPB	BICYCLE PUSH BUTTON	MVDS	MICROWAVE VEHICLE DETECTION SYSTEM
C	CONDUIT	N	NEUTRAL (GROUNDED CONDUCTOR)
CB	CIRCUIT BREAKER	NB	NEUTRAL BUS
CCTV	CLOSED CIRCUIT TELEVISION	NC	NORMALLY CLOSE
Ck+	CIRCUIT	NO	NORMALLY OPEN
CMS	CHANGEABLE MESSAGE SIGN	P	CIRCUIT BREAKER'S POLE
Ctid	CALTRANS IDENTIFICATION	PB	PULL BOX
Comm	COMMUNICATION	PBA	PUSH BUTTON ASSEMBLY
DLC	LOOP DETECTOR LEAD-IN CABLE	PEC	PHOTOELECTRIC CONTROL
EMS	EXTINGUISHABLE MESSAGE SIGN	Ped	PEDESTRIAN
EVUC	EMERGENCY VEHICLE UNIT CABLE	PEU	PHOTOELECTRIC UNIT
EVUD	EMERGENCY VEHICLE UNIT DETECTOR	PT	CONDUIT WITH PULL TAPE
FB	FLASHING BEACON	RE	RELOCATED EQUIPMENT
FBCA	FLASHING BEACON CONTROL ASSEMBLY	RM	RAMP METERING
FBS	FLASHING BEACON WITH SLIP BASE	RWIS	ROADSIDE WEATHER INFORMATION SYSTEM
FO	FIBER OPTIC	SB	SLIP BASE
G	EQUIPMENT GROUNDING CONDUCTOR	SIC	SIGNAL INTERCONNECT CABLE
GB	GROUND BUS	Sig	SIGNAL
GFCI	GROUND FAULT CIRCUIT INTERRUPTER	SMA	SIGNAL MAST ARM
HAR	HIGHWAY ADVISORY RADIO	SNS	STREET NAME SIGN
Hex	HEXAGONAL	SP	SERVICE POINT
HPS	HIGH PRESSURE SODIUM	TDC	TELEPHONE DEMARCATION CABINET
IISNS	INTERNALLY ILLUMINATED STREET NAME SIGN	TMS	TRAFFIC MONITORING STATION
ISL	INDUCTION SIGN LIGHTING	TOS	TRAFFIC OPERATIONS SYSTEM
LED	LIGHT EMITTING DIODE	Veh	VEHICLE
LMA	LUMINAIRE MAST ARM	VIVDS	VIDEO IMAGE VEHICLE DETECTION SYSTEM
LPS	LOW PRESSURE SODIUM	WIM	WEIGH-IN-MOTION
Ltg	LIGHTING	Xfmr	TRANSFORMER
Lum	LUMINAIRE		
M	METERED		
MAT	MAST ARM MOUNTING TOP ATTACHMENT		
MAS	MAST ARM MOUNTING SIDE ATTACHMENT		

STANDARD ELECTROLIER

<u>NEW</u>	<u>EXISTING</u>	<u>STANDARD TYPE</u>
		15
		15D
		15 STRUCTURE
		15D STRUCTURE
		21
		21D
		21 STRUCTURE
		21D STRUCTURE
		30
		31
		32

Dist	COUNTY	ROUTE	POST MILES TOTAL PROJECT	SHEET No.	TOTAL SHEETS
10	Sta	120	0.0/4.1	24	32

Theresa Gabriel
REGISTERED ELECTRICAL ENGINEER

July 19, 2013
PLANS APPROVAL DATE

Theresa Aziz Gabriel
No. E15129
Exp. 6-30-14
ELECTRICAL
STATE OF CALIFORNIA

THE STATE OF CALIFORNIA OR ITS OFFICERS OR AGENTS SHALL NOT BE RESPONSIBLE FOR THE ACCURACY OR COMPLETENESS OF SCANNED COPIES OF THIS PLAN SHEET.

TO ACCOMPANY PLANS DATED 1-26-15

SOFFIT AND WALL MOUNTED LUMINAIRES

- PENDANT, 70 W HPS UNLESS OTHERWISE SPECIFIED
- FLUSH, 70 W HPS UNLESS OTHERWISE SPECIFIED
- WALL SURFACE, 70 W HPS UNLESS OTHERWISE SPECIFIED
- EXISTING SOFFIT OR WALL LUMINAIRE TO REMAIN UNMODIFIED
- EXISTING SOFFIT OR WALL LUMINAIRE TO BE MODIFIED AS SPECIFIED

NOTE:

Arrow indicates "street side" of luminaire.

COMMONLY USED SYMBOLS FOR UNITED STATES CUSTOMARY UNITS OF MEASUREMENT:

SYMBOL USED	DEFINITIONS
Ω	OHMS
min	MINUTE
s	SECOND
bps	BITS PER SECOND
Bps	BYTES PER SECOND
A	AMPERE
V	VOLT
V(dc)	VOLT (DIRECT CURRENT)
V(ac)	VOLT (ALTERNATING CURRENT)
FC	FOOT - CANDLE
W	WATTS
VA	VOLT-AMPERE
M	MEGA
k	KILO
m	MILLI
μ	MICRO
P	PICO
Hz	HERTZ

STATE OF CALIFORNIA
DEPARTMENT OF TRANSPORTATION

**ELECTRICAL SYSTEMS
(LEGEND AND ABBREVIATIONS)**

NO SCALE

RSP ES-1A DATED JULY 19, 2013 SUPERSEDES STANDARD PLAN ES-1A DATED MAY 20, 2011 - PAGE 425 OF THE STANDARD PLANS BOOK DATED 2010.

REVISED STANDARD PLAN RSP ES-1A

2010 REVISED STANDARD PLAN RSP ES-1A

Dist	COUNTY	ROUTE	POST MILES TOTAL PROJECT	SHEET No.	TOTAL SHEETS
10	Sta	120	0.0/4.1	25	32

Theresa Gabriel
REGISTERED ELECTRICAL ENGINEER

July 19, 2013
PLANS APPROVAL DATE

Theresa Aziz Gabriel
No. E15129
Exp. 6-30-14
ELECTRICAL
STATE OF CALIFORNIA

THE STATE OF CALIFORNIA OR ITS OFFICERS OR AGENTS SHALL NOT BE RESPONSIBLE FOR THE ACCURACY OR COMPLETENESS OF SCANNED COPIES OF THIS PLAN SHEET.

TO ACCOMPANY PLANS DATED 1-26-15

CONDUIT

NEW	EXISTING	
---	---	LIGHTING CONDUIT, UNLESS OTHERWISE INDICATED OR NOTED
---	---	TRAFFIC SIGNAL CONDUIT
---C---	---c---	COMMUNICATION CONDUIT
---T---	---t---	TELEPHONE CONDUIT
---F---	---f---	FIRE ALARM CONDUIT
---FO---	---fo---	FIBER OPTIC CONDUIT
---	---	CONDUIT TERMINATION
		CONDUIT RISER ATTACHED TO THE STRUCTURE OR SERVICE POLE


SIGNAL EQUIPMENT

NEW	EXISTING	
		PEDESTRIAN SIGNAL HEAD "C" INDICATES COUNTDOWN PEDESTRIAN HEAD
		PUSH BUTTON ASSEMBLY POST
		PEDESTRIAN BARRICADE
		VEHICLE SIGNAL HEAD (WITH BACKPLATE AND 3-SECTIONS: RED, YELLOW AND GREEN)
		VEHICLE SIGNAL HEAD WITH ANGLE VISOR
		MODIFICATIONS OF BASIC SYMBOL: "L" INDICATES ALL NON-ARROW SECTIONS LOUVERED "LG" INDICATES LOUVERED GREEN SECTION ONLY "PV" INDICATES ALL 12" SECTIONS PROGRAMMED VISIBILITY "8" INDICATES ALL 8" SECTIONS (ONLY WHEN SPECIFIED)
		VEHICLE SIGNAL HEAD CONSISTING OF RED, YELLOW AND GREEN LEFT ARROW SECTIONS
		VEHICLE SIGNAL HEAD CONSISTING OF RED AND YELLOW SECTIONS WITH AN UP GREEN ARROW SECTION
		VEHICLE SIGNAL HEAD (5 SECTION) CONSISTING OF RED, YELLOW AND GREEN SECTIONS WITH YELLOW AND GREEN RIGHT ARROW SECTIONS
		TYPE 15TS STANDARD WITH VEHICLE SIGNAL HEAD AND LUMINAIRE
		TYPE 21TS STANDARD WITH VEHICLE SIGNAL HEAD AND LUMINAIRE
		STANDARD WITH LUMINAIRE AND SIGNAL MAST ARMS AND ATTACHED VEHICLE SIGNAL HEADS
		TYPE 1 STANDARD WITH ATTACHED VEHICLE SIGNAL HEADS
		STANDARD WITH A SIGNAL MAST ARM, ATTACHED VEHICLE SIGNAL HEADS AND INTERNALLY ILLUMINATED STREET NAME SIGN
		CONTROLLER ASSEMBLY. DOOR INDICATES FRONT OF CABINET

SERVICE EQUIPMENT

NEW	EXISTING	
---OH---	---oh---	OVERHEAD LINES
		WOOD POLE, "U" INDICATES UTILITY OWNED
		POLE GUY WITH ANCHOR
		UTILITY TRANSFORMER - GROUND MOUNTED
		SERVICE EQUIPMENT ENCLOSURE TYPE. DOOR INDICATES FRONT OF ENCLOSURE
		TELEPHONE DEMARCATION CABINET

 POLE-MOUNTED SERVICE DESIGNATION



FLASHING BEACON

NEW	EXISTING	
		FLASHING BEACON (ONE VEHICLE SIGNAL HEAD WITH BACKPLATE AND VISOR) "R" INDICATES RED INDICATION, "Y" INDICATES YELLOW INDICATION
		FLASHING BEACON WITH TYPE 15-FBS STANDARD AND A SIGN.
		FLASHING BEACON WITH TYPES 9, 9A OR 9B SIGN UNLESS OTHERWISE SPECIFIED OR INDICATED

SIGNAL EQUIPMENT Cont

NEW	EXISTING	
		GUARD POST
		TYPE 1 STANDARD WITH RAMP METERING SIGN
		OPTICAL DETECTOR FOR THE EMERGENCY VEHICLE DETECTION SYSTEM

NOTES:

- All signal sections shall be 12" unless shown otherwise.
- Signal heads shall be provided with backplates unless shown otherwise.

ILLUMINATED OVERHEAD SIGN

NEW	EXISTING	
		SINGLE POST, SINGLE ILLUMINATED SIGN, BALANCED BUTTERFLY
		SINGLE POST, DOUBLE ILLUMINATED SIGN, BALANCED BUTTERFLY
		SINGLE POST, SINGLE ILLUMINATED SIGN, FULL CANTILEVER
		DOUBLE POST, SINGLE ILLUMINATED SIGN
		SINGLE ILLUMINATED SIGN MOUNTED ON STRUCTURE
		DOUBLE POST, SINGLE ILLUMINATED SIGN WITH ELECTROLIER

STATE OF CALIFORNIA
DEPARTMENT OF TRANSPORTATION

**ELECTRICAL SYSTEMS
(LEGEND AND ABBREVIATIONS)**

NO SCALE

RSP ES-1B DATED JULY 19, 2013 SUPERSEDES STANDARD PLAN ES-1B DATED MAY 20, 2011 - PAGE 426 OF THE STANDARD PLANS BOOK DATED 2010.


REVISED STANDARD PLAN RSP ES-1B

2010 REVISED STANDARD PLAN RSP ES-1B


TO ACCOMPANY PLANS DATED 1-26-15

EQUIPMENT IDENTIFICATION


ILLUMINATED SIGN IDENTIFICATION NUMBER:

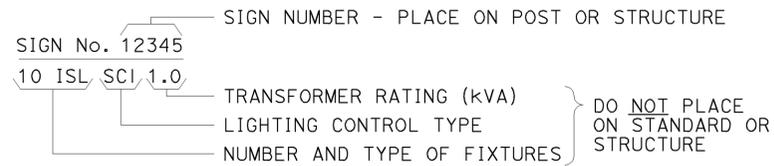


ELECTROLIER OR EQUIPMENT IDENTIFICATION NUMBER:

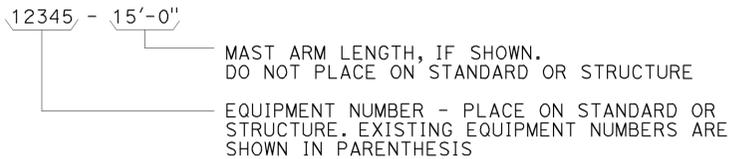


CONDUIT AND CONDUCTOR IDENTIFICATION:

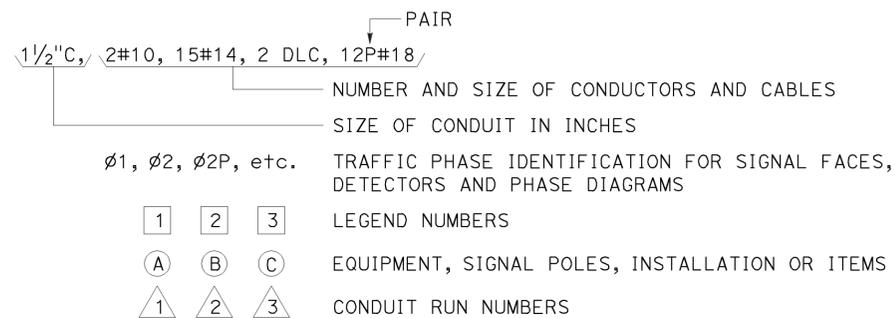


SIGNAL AND LIGHTING STANDARD (TYPICAL DESIGNATION):

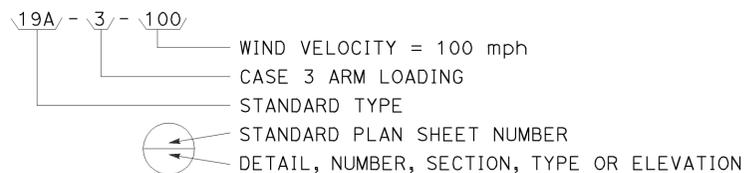


MISCELLANEOUS EQUIPMENT

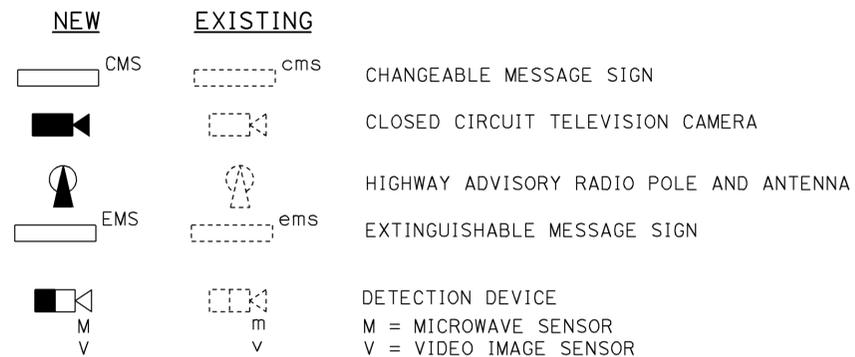



WIRING DIAGRAM LEGEND

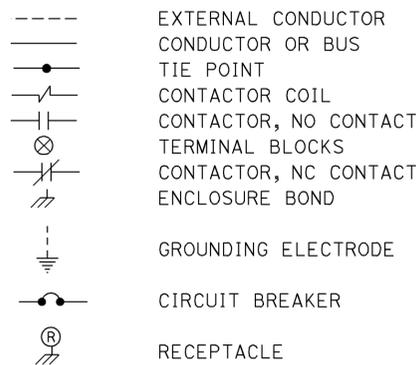

PULL BOXES

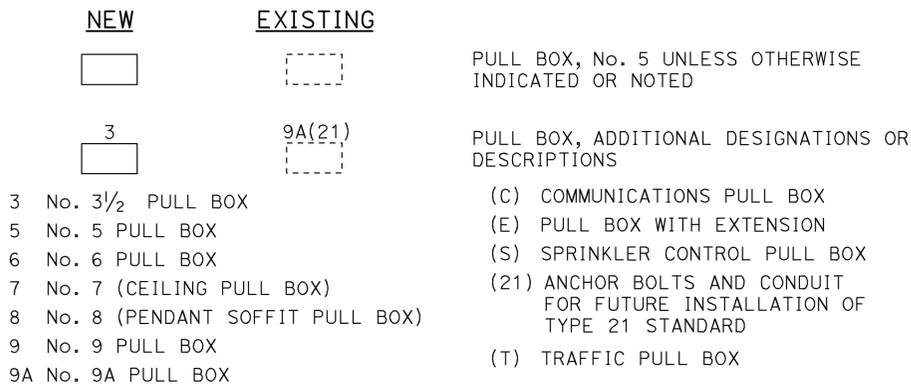

VEHICLE DETECTORS

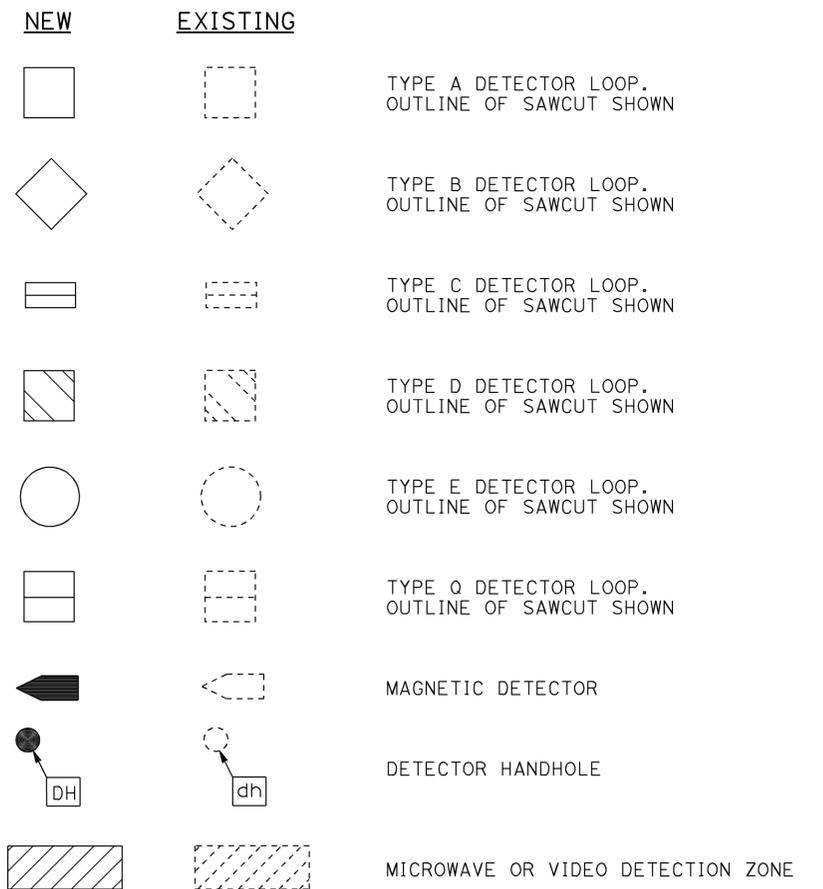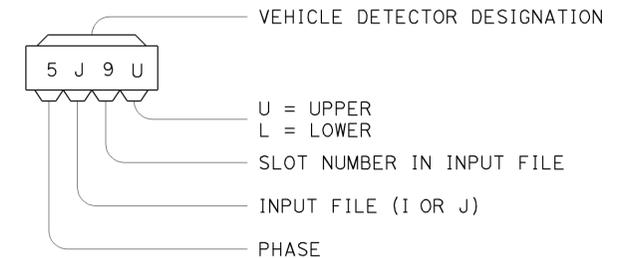

STATE OF CALIFORNIA
DEPARTMENT OF TRANSPORTATION

ELECTRICAL SYSTEMS (LEGEND AND ABBREVIATIONS)

NO SCALE

RSP ES-1C DATED JULY 19, 2013 SUPERSEDES STANDARD PLAN ES-1C DATED MAY 20, 2011 - PAGE 427 OF THE STANDARD PLANS BOOK DATED 2010.

REVISED STANDARD PLAN RSP ES-1C


2010 REVISED STANDARD PLAN RSP ES-1C

Dist	COUNTY	ROUTE	POST MILES TOTAL PROJECT	SHEET No.	TOTAL SHEETS
10	Sta	120	0.0/4.1	27	32


Theresa Gabriel
 REGISTERED ELECTRICAL ENGINEER
 October 17, 2014
 PLANS APPROVAL DATE

THE STATE OF CALIFORNIA OR ITS OFFICERS OR AGENTS SHALL NOT BE RESPONSIBLE FOR THE ACCURACY OR COMPLETENESS OF SCANNED COPIES OF THIS PLAN SHEET.

TO ACCOMPANY PLANS DATED 1-26-15

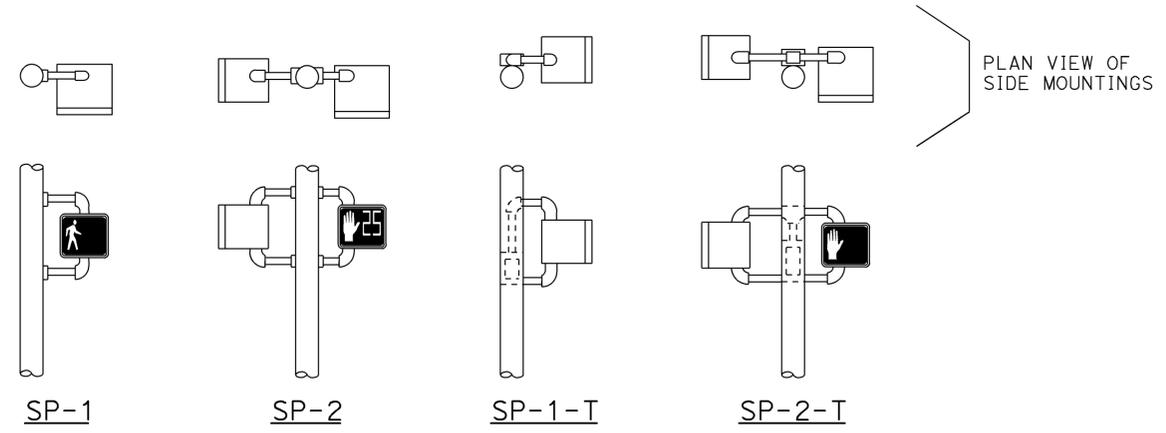

SIDE MOUNTINGS

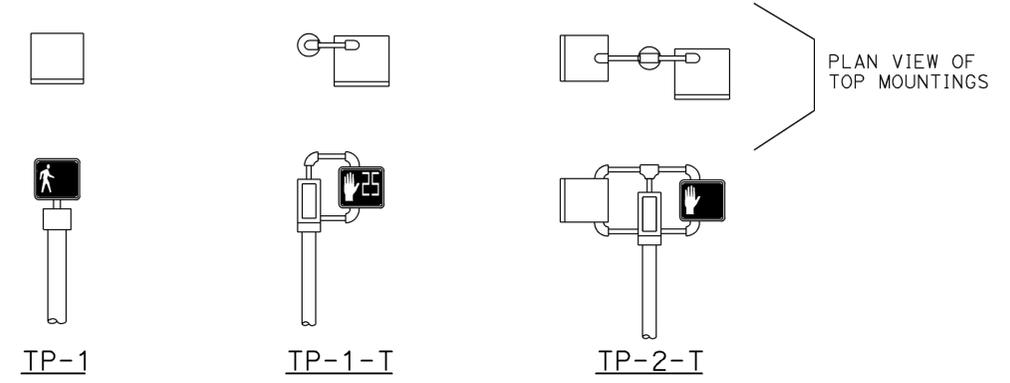

TOP MOUNTINGS

PEDESTRIAN SIGNALS AND MOUNTINGS

DETAIL A



PERSON WALKING INTERVAL FLASHING UPRaised HAND INTERVAL STEADY UPRaised HAND INTERVAL

PEDESTRIAN SIGNAL MODULE WITH COUNTDOWN

DETAIL B



PERSON WALKING INTERVAL STEADY UPRaised HAND INTERVAL

PEDESTRIAN SIGNAL MODULE WITHOUT COUNTDOWN

DETAIL C

NOTES:

1. Mounting shall be oriented to provide maximum horizontal clearance to adjacent roadway.
2. Bracket arms shall be long enough to permit proper alignment of signals.
3. See Standard Plan ES-4D for attachment fittings details.

ABBREVIATIONS:

- 1, 2 NUMBER OF SIGNAL FACES
- SP SIDE MOUNTED PEDESTRIAN SIGNAL
- T TERMINAL COMPARTMENT
- TP TOP MOUNTED PEDESTRIAN SIGNAL

STATE OF CALIFORNIA
DEPARTMENT OF TRANSPORTATION
**ELECTRICAL SYSTEMS
(PEDESTRIAN SIGNAL)**

NO SCALE

RSP ES-4B DATED OCTOBER 17, 2014 SUPERSEDES RSP ES-4B DATED JULY 19, 2013 AND STANDARD PLAN ES-4B DATED MAY 20, 2011 - PAGE 444 OF THE STANDARD PLANS BOOK DATED 2010.

REVISED STANDARD PLAN RSP ES-4B



2010 REVISED STANDARD PLAN RSP ES-4B

Dist	COUNTY	ROUTE	POST MILES TOTAL PROJECT	SHEET No.	TOTAL SHEETS
10	Sta	120	0.0/4.1	28	32


Theresa Gabriel
 REGISTERED ELECTRICAL ENGINEER
 July 19, 2013
 PLANS APPROVAL DATE
 Theresa Aziz Gabriel
 No. E15129
 Exp. 6-30-14
 ELECTRICAL
 STATE OF CALIFORNIA

THE STATE OF CALIFORNIA OR ITS OFFICERS OR AGENTS SHALL NOT BE RESPONSIBLE FOR THE ACCURACY OR COMPLETENESS OF SCANNED COPIES OF THIS PLAN SHEET.

TO ACCOMPANY PLANS DATED 1-26-15

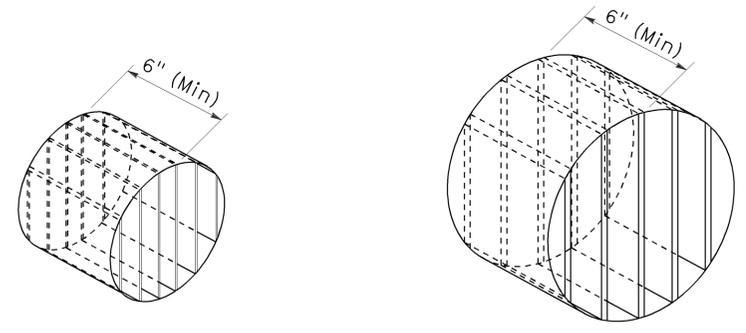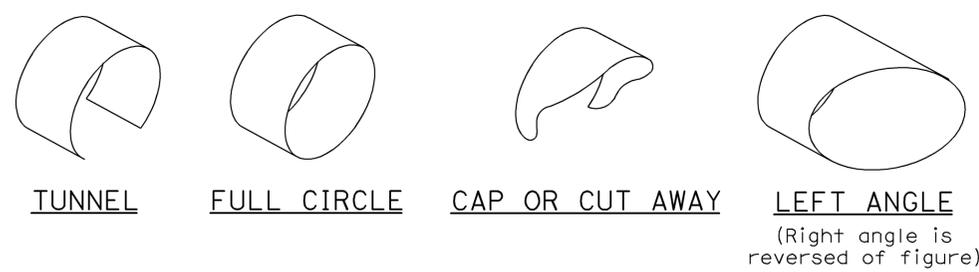


ISOMETRIC VIEW ISOMETRIC VIEW

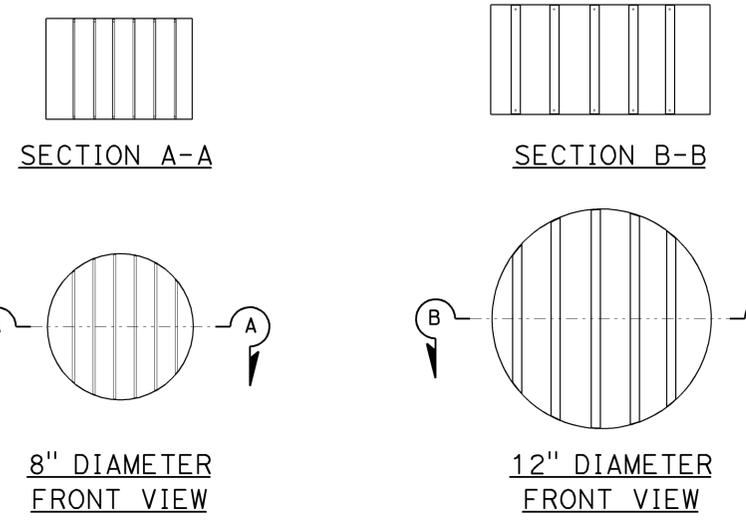

8" DIAMETER FRONT VIEW 12" DIAMETER FRONT VIEW

DIRECTIONAL LOUVER


Directional louvers shall be oriented as directed by the Engineer and secured in place with one plated brass machine screw and nut.

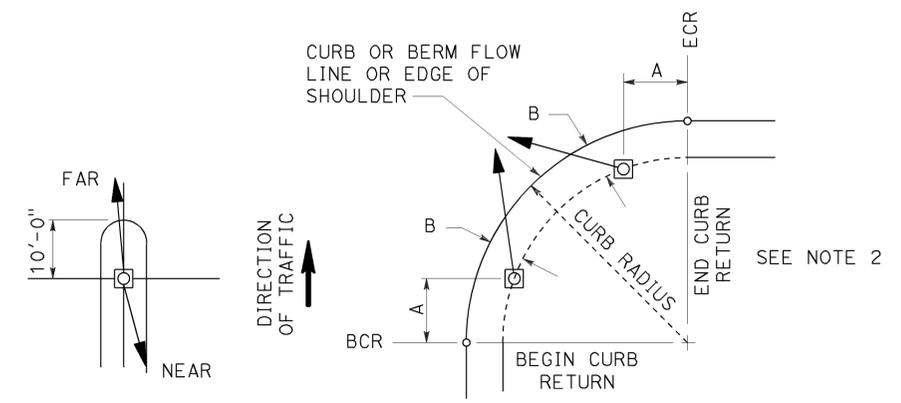

NOTES:

1. Typical signal pole placement unless dimensioned on plans.
2. For A and B dimensions, see Pole Schedule, or as directed by the Engineer.


SIGNAL STANDARD PLACEMENT DIMENSIONS AND EQUIPMENT LOCATIONS

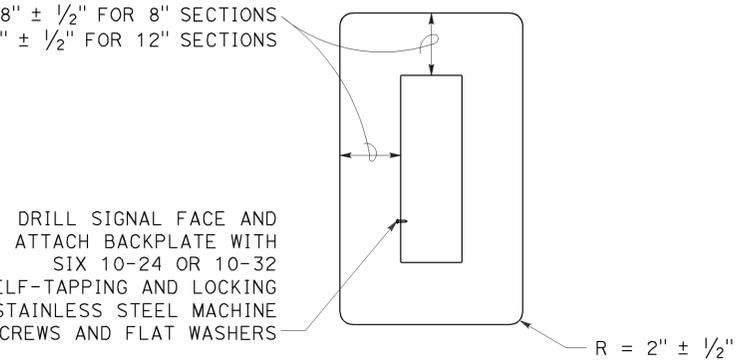

8" AND 12" SECTIONS

BACKPLATE

1/16" minimum thickness
3001-14 aluminum or plastic when specified

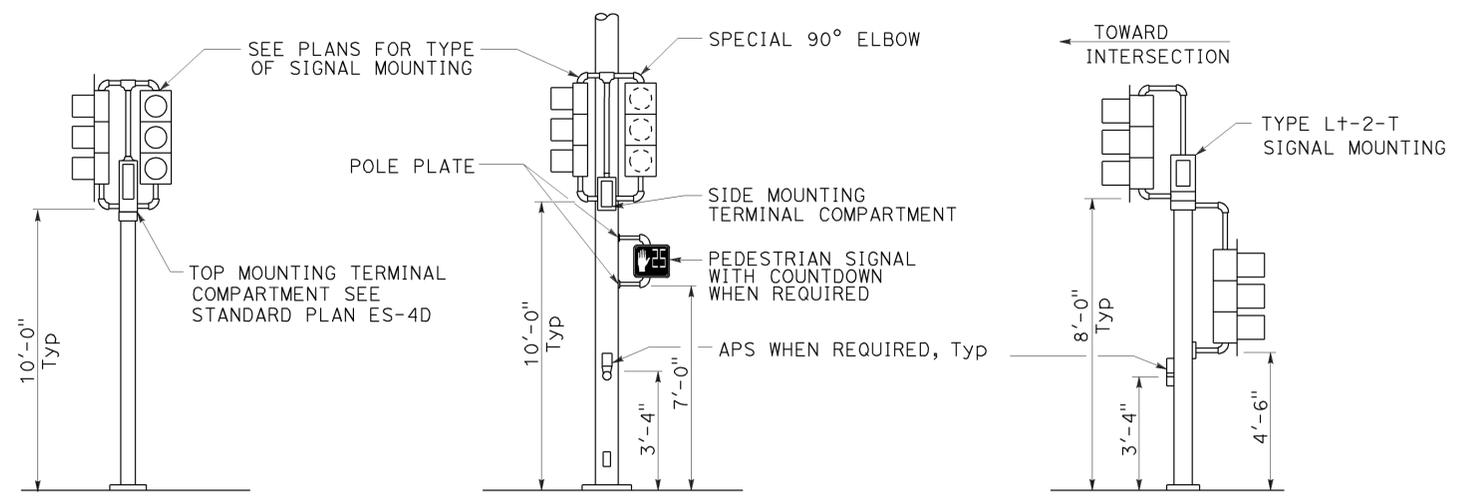

TOP MOUNTED SIGNALS (TV)

SIDE MOUNTED SIGNALS (SV AND SP)


LEFT TURN LANE SIGNAL

Type 1-A, 1-B, 1-C and 1-D standard as indicated on the plans

Normally used on standards with luminaire or signal mast arm

Type 1-A, 1-B, 1-C and 1-D standard as indicated on plans


TYPICAL SIGNAL INSTALLATIONS

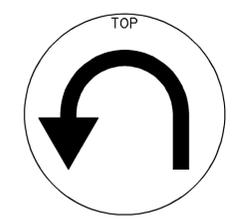


U-TURN



BICYCLE

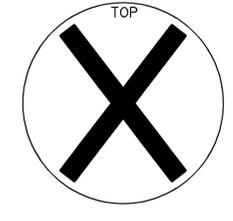

LANE CONTROL

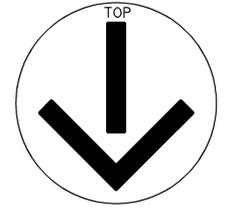

LANE CONTROL

SIGNAL FACES

STATE OF CALIFORNIA
DEPARTMENT OF TRANSPORTATION

ELECTRICAL SYSTEMS (VEHICULAR SIGNAL HEADS AND MOUNTINGS)

NO SCALE

RSP ES-4C DATED JULY 19, 2013 SUPERSEDES STANDARD PLAN ES-04C DATED MAY 20, 2011 - PAGE 445 OF THE STANDARD PLANS BOOK DATED 2010.

REVISED STANDARD PLAN RSP ES-4C


2010 REVISED STANDARD PLAN RSP ES-4C

Dist	COUNTY	ROUTE	POST MILES TOTAL PROJECT	SHEET No.	TOTAL SHEETS
10	Sta	120	0.0/4.1	29	32


Theresa Gabriel
 REGISTERED ELECTRICAL ENGINEER
 July 19, 2013
 PLANS APPROVAL DATE
THE STATE OF CALIFORNIA OR ITS OFFICERS OR AGENTS SHALL NOT BE RESPONSIBLE FOR THE ACCURACY OR COMPLETENESS OF SCANNED COPIES OF THIS PLAN SHEET.

REGISTERED PROFESSIONAL ENGINEER
 Theresa Aziz Gabriel
 No. E15129
 Exp. 6-30-14
 ELECTRICAL
 STATE OF CALIFORNIA


TO ACCOMPANY PLANS DATED 1-26-15

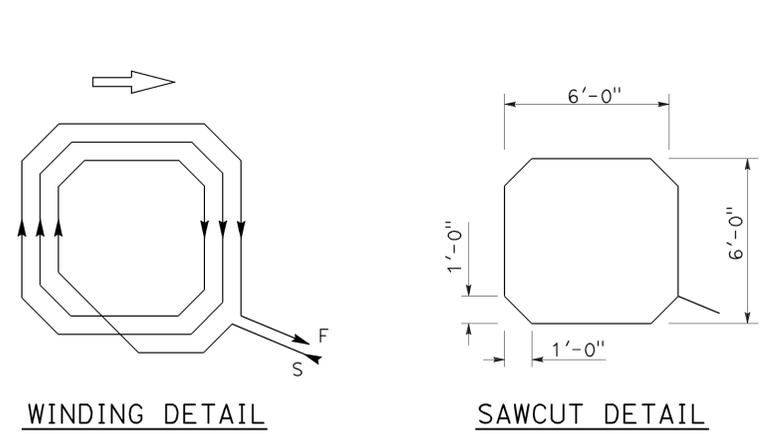


WINDING DETAIL
SAWCUT DETAIL
TYPE A LOOP DETECTOR CONFIGURATION

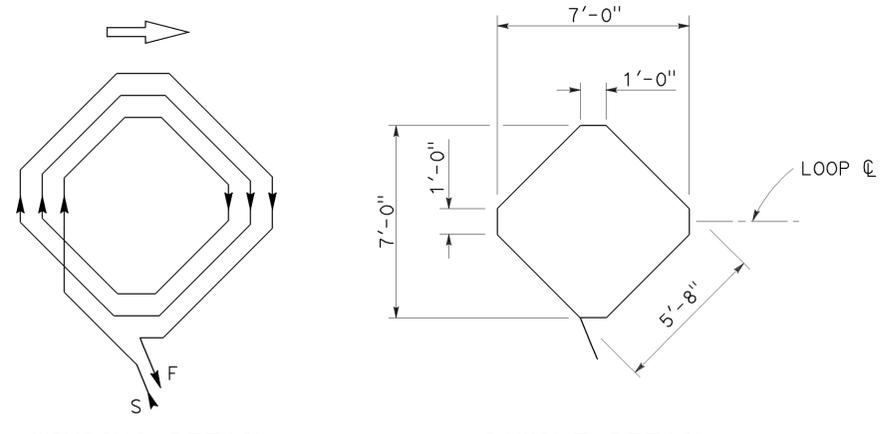


WINDING DETAIL
SAWCUT DETAIL
TYPE B LOOP DETECTOR CONFIGURATION

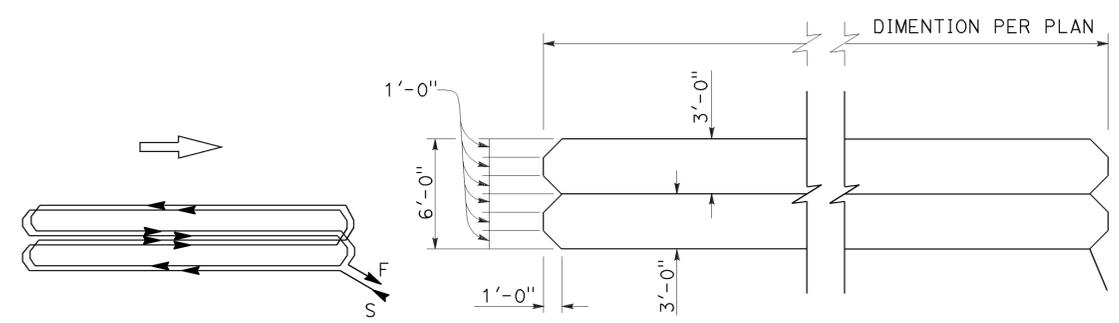


WINDING DETAIL
SAWCUT DETAIL
TYPE C LOOP DETECTOR CONFIGURATION

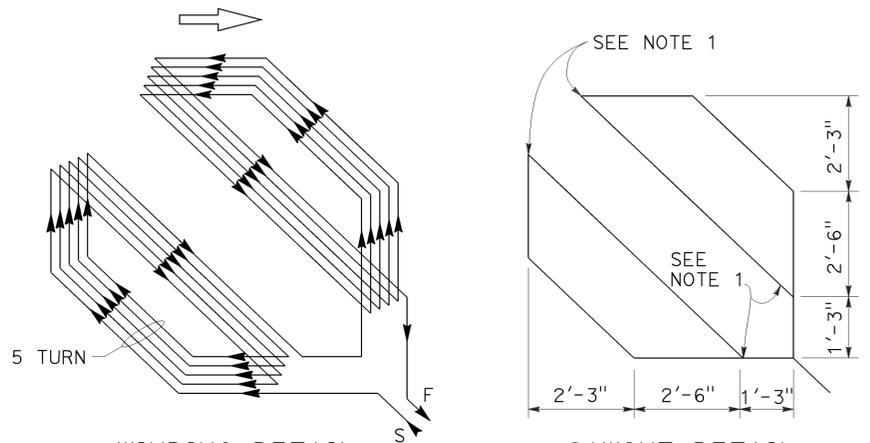


WINDING DETAIL
SAWCUT DETAIL
TYPE D LOOP DETECTOR CONFIGURATION

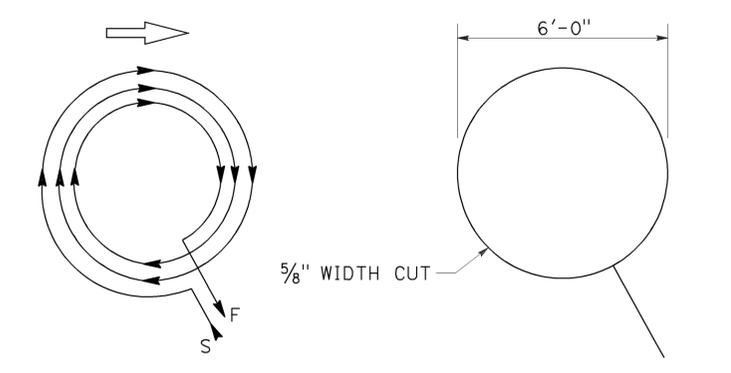

WINDING DETAIL
SAWCUT DETAIL
TYPE E LOOP DETECTOR CONFIGURATION

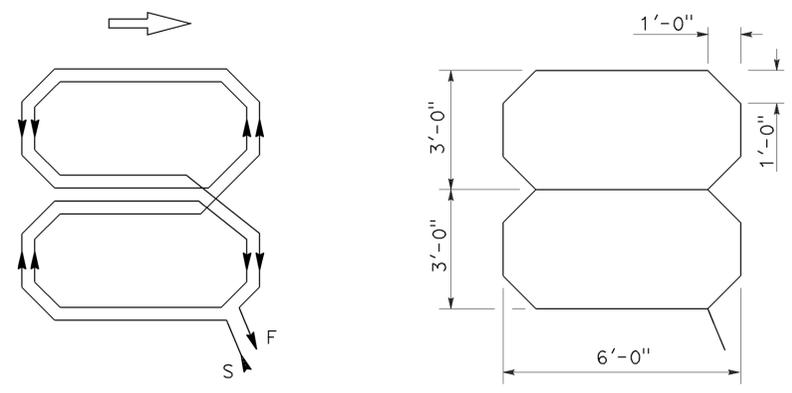

WINDING DETAIL
SAWCUT DETAIL
TYPE Q LOOP DETECTOR CONFIGURATION

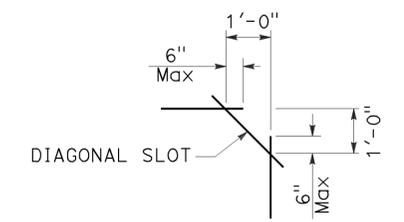

PLAN VIEW OF DIAGONAL SLOT AT CORNERS

- NOTES:**
1. Round corners of acute angle sawcuts to prevent damage to conductors.
 2. Typical distance separating loops from edge to edge is 10' for Type A, B, D and E installation in single lane.

STATE OF CALIFORNIA
DEPARTMENT OF TRANSPORTATION
ELECTRICAL SYSTEMS (DETECTORS)
NO SCALE

RSP ES-5B DATED JULY 19, 2013 SUPERSEDES STANDARD PLAN ES-5B DATED MAY 20, 2011 - PAGE 449 OF THE STANDARD PLANS BOOK DATED 2010.

2010 REVISED STANDARD PLAN RSP ES-5B

Dist	COUNTY	ROUTE	POST MILES TOTAL PROJECT	SHEET No.	TOTAL SHEETS
10	Sta	120	0.0/4.1	30	32

Theresa Gabriel
 REGISTERED ELECTRICAL ENGINEER
 July 19, 2013
 PLANS APPROVAL DATE


THE STATE OF CALIFORNIA OR ITS OFFICERS
 OR AGENTS SHALL NOT BE RESPONSIBLE FOR
 THE ACCURACY OR COMPLETENESS OF SCANNED
 COPIES OF THIS PLAN SHEET.

REGISTERED PROFESSIONAL ENGINEER
 Theresa
 Aziz Gabriel
 No. E15129
 Exp. 6-30-14
 ELECTRICAL
 STATE OF CALIFORNIA


TO ACCOMPANY PLANS DATED 1-26-15

NOTES:


1. Back casting shape to fit curvature of pole.
2. Provide cover fitting for top of post, when PBA is mounted on push button assembly post.
3. Install push button on crosswalk side of standard.
4. Use R10 series regulatory signs and plaques for pedestrian and bicycle facilities.

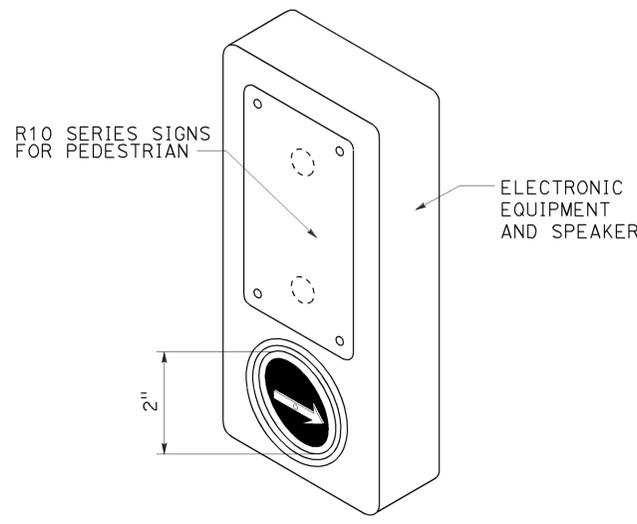



ACCESSIBLE PEDESTRIAN SIGNAL
DETAIL A
 (See note 1 to 4)

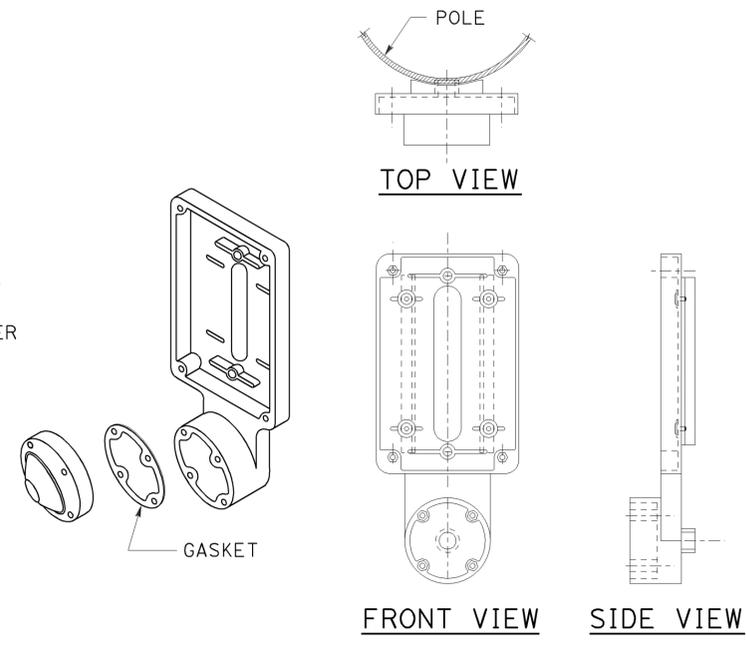


TYPE B PUSH BUTTON ASSEMBLY
DETAIL B
 (See note 1 to 4)

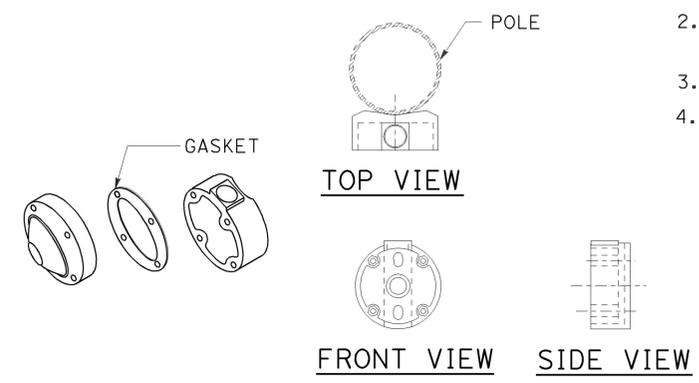

TYPE C PUSH BUTTON ASSEMBLY
DETAIL C
 (See note 1 to 4)

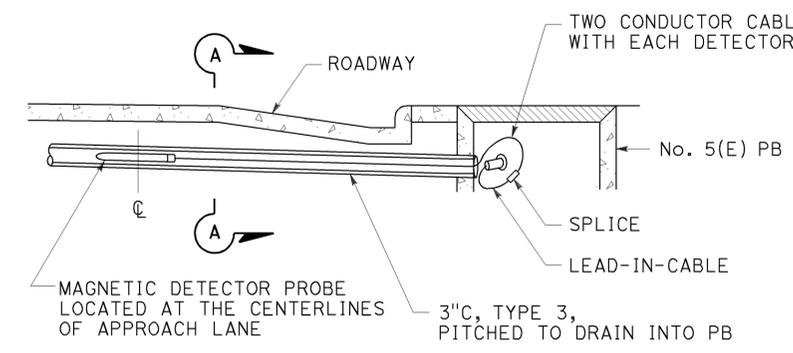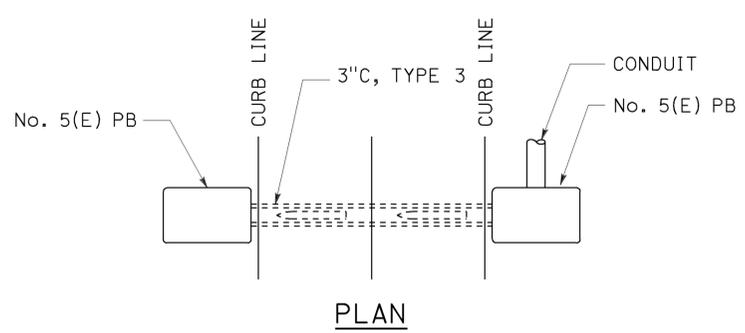

MAGNETIC VEHICLE DETECTOR
INSTALLATION DETAILS
DETAIL D

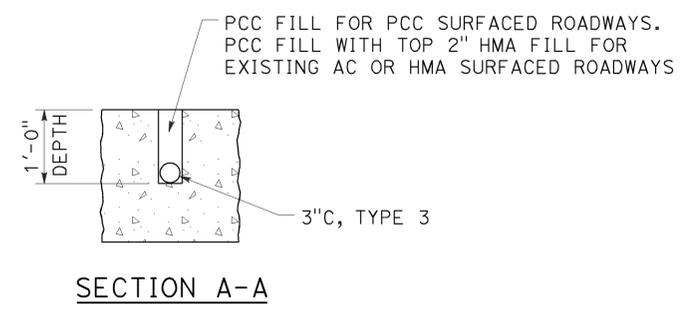

STATE OF CALIFORNIA
 DEPARTMENT OF TRANSPORTATION
ELECTRICAL SYSTEMS
(ACCESSIBLE PEDESTRIAN SIGNAL,
PUSH BUTTON ASSEMBLIES AND
MAGNETIC VEHICLE DETECTOR)
 NO SCALE

RSP ES-5C DATED JULY 19, 2013 SUPERSEDES STANDARD PLAN ES-5C
 DATED MAY 20, 2011 - PAGE 450 OF THE STANDARD PLANS BOOK DATED 2010.

REVISED STANDARD PLAN RSP ES-5C


2010 REVISED STANDARD PLAN RSP ES-5C

Dist	COUNTY	ROUTE	POST MILES TOTAL PROJECT	SHEET No.	TOTAL SHEETS
10	Sta	120	0.0/4.1	31	32


Theresa Gabriel
 REGISTERED ELECTRICAL ENGINEER
 July 19, 2013
 PLANS APPROVAL DATE
THE STATE OF CALIFORNIA OR ITS OFFICERS OR AGENTS SHALL NOT BE RESPONSIBLE FOR THE ACCURACY OR COMPLETENESS OF SCANNED COPIES OF THIS PLAN SHEET.

TO ACCOMPANY PLANS DATED 1-26-15


2010 REVISED STANDARD PLAN RSP ES-5D

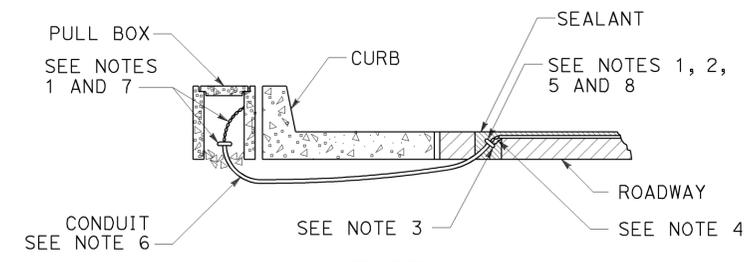


**TYPE A
CURB TERMINATION DETAIL**

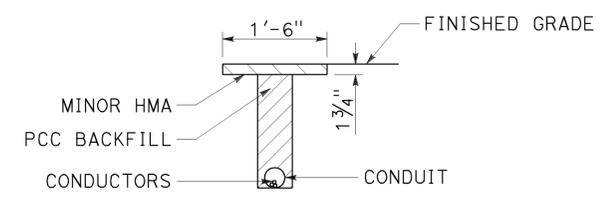

**"T" TRENCH
DETAIL T**

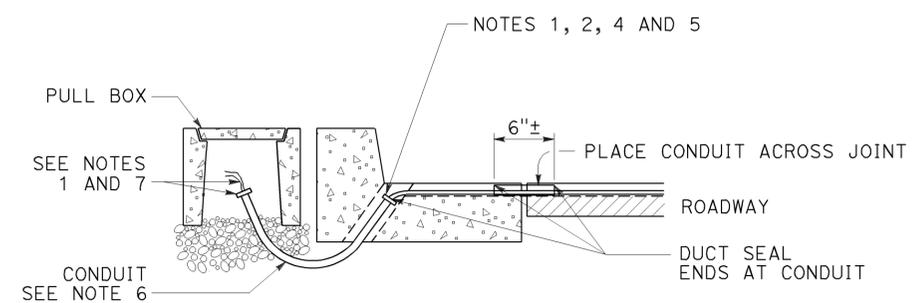

CROSS SECTION

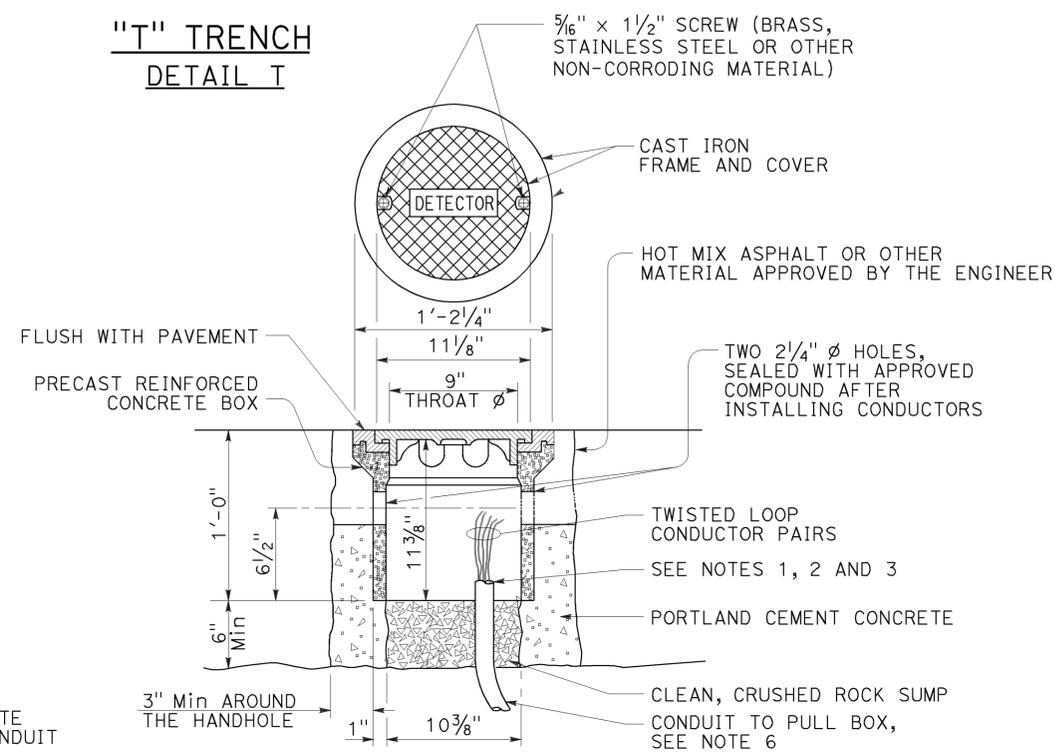


DETECTOR HANDHOLE DETAIL




PLAN VIEW

SECTION C-C


**TYPE B
CURB TERMINATION DETAIL**

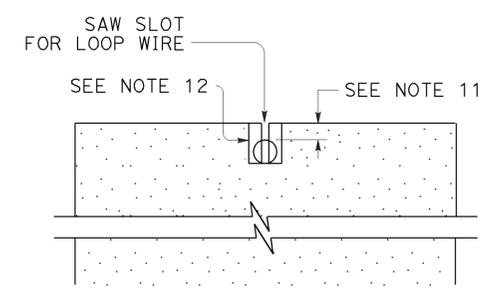


SECTION A-A

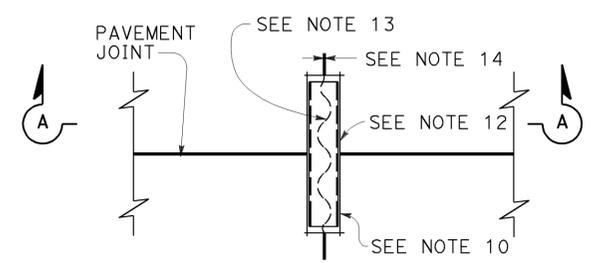


**PLAN VIEW
TYPICAL LOOP LEAD-IN DETAIL
AT PAVEMENT JOINT**

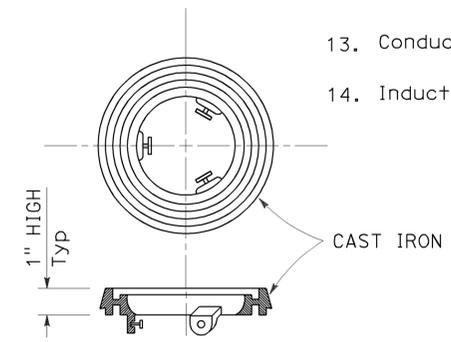

LOCKING GRADE RING

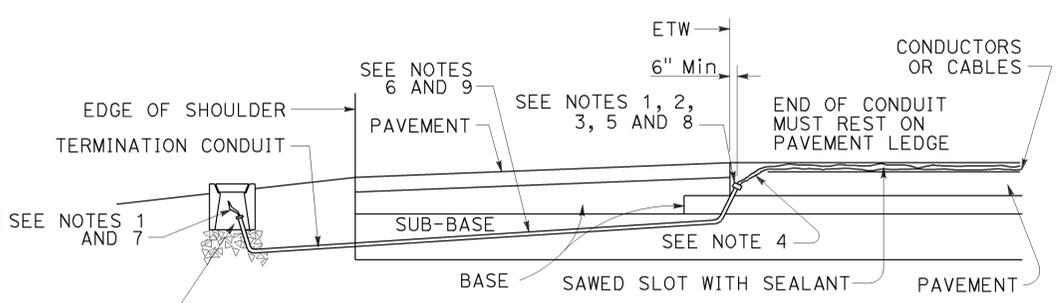

CROSS SECTION

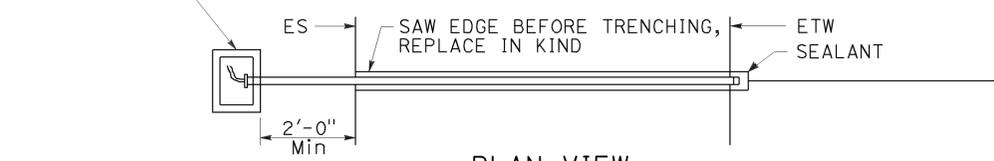

**PLAN VIEW
SHOULDER TERMINATION DETAILS**


NOTES:

- Bushing shall be used at end of conduit.
- Tape detector conductors or cables 3" each side of bushings.
- Install duct seal compound to each end of termination conduit before installing sealant.
- Round all sharp edges where detector conductors or cables have to pass.
- End of conduit shall be 3/8" below roadway surface.
- | | |
|-----------------|-----------------|
| Conduit size | Loop conductors |
| 1"C minimum | 1 to 2 pairs |
| 1 1/2"C minimum | 3 to 4 pairs |
| 2"C minimum | 5 or more pairs |
- Splice detector conductors or cables to detector lead-in-cable.
- Location of detector handhole when shown on plans.
- When the shoulder and traveled way are paved with the same material and there is no joint between them, the conduit shall extend only 2'-0" into the shoulder pavement.
- 3/4"C, Type 3 conduit 6" long minimum, plug both ends with duct compound to keep out sealant.
- 1/2" Minimum between top of conduit and pavement surface.
- Sawcut shall not exceed 1" in width and 1/8" longer than conduit to be installed.
- Conductors with 1/2" minimum slack inside conduit.
- Inductive loop detector saw slot.

STATE OF CALIFORNIA
DEPARTMENT OF TRANSPORTATION
**ELECTRICAL SYSTEMS
(CURB TERMINATION
AND HANDHOLE)**
NO SCALE

RSP ES-5D DATED JULY 19, 2013 SUPERSEDES STANDARD PLAN ES-5D DATED MAY 20, 2011 - PAGE 451 OF THE STANDARD PLANS BOOK DATED 2010.


REVISED STANDARD PLAN RSP ES-5D

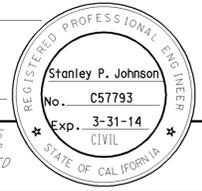


NOTES:

- For additional notes, details and data for Type 15TS and Type 21TS Standards, see Standard Plan ES-6A.
- Handhole shall be located on the downstream side of traffic.


TO ACCOMPANY PLANS DATED 1-26-15

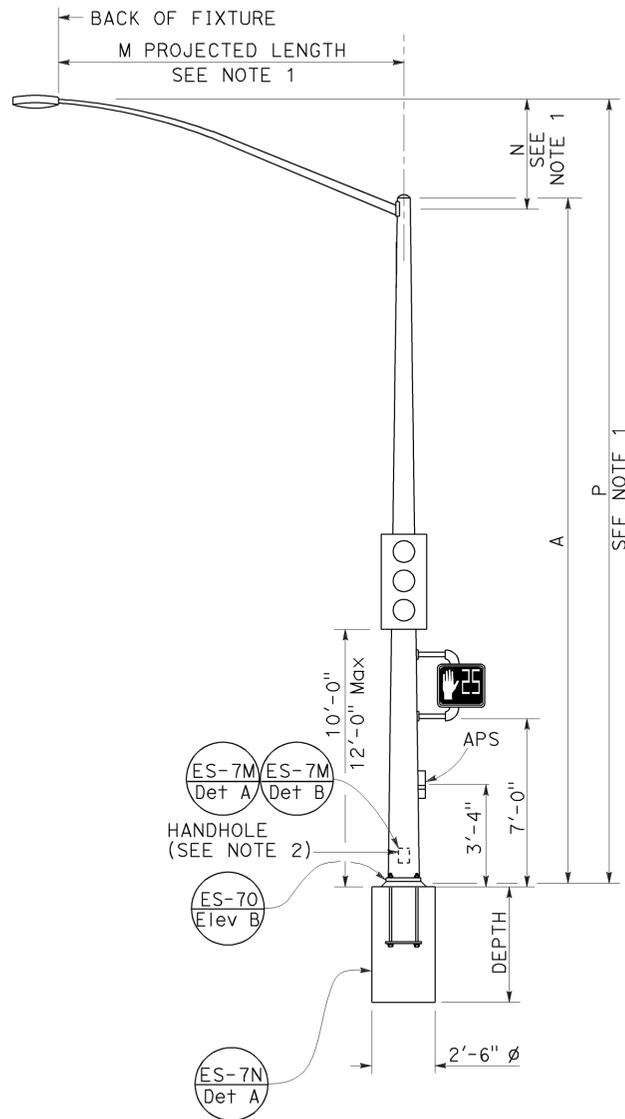


TYPE 15TS AND 21TS STANDARD
ELEVATION A
 (See Note 1)

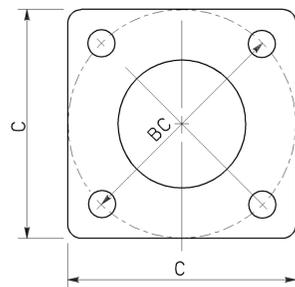


BASE PLATE
TYPE 15TS AND 21TS
DETAIL A

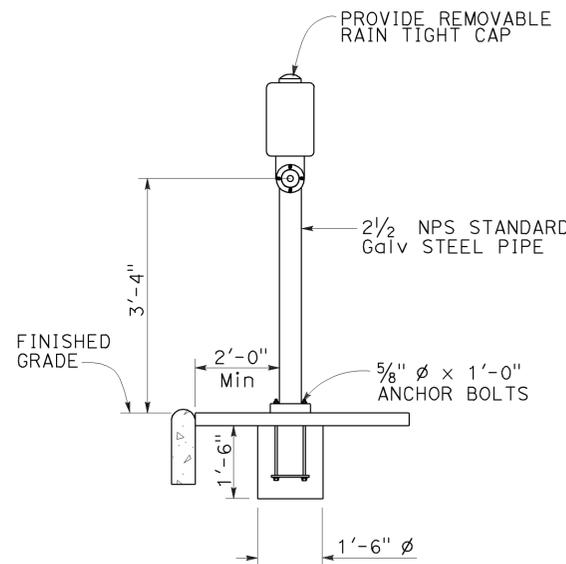

PUSH BUTTON ASSEMBLY POST
DETAIL B

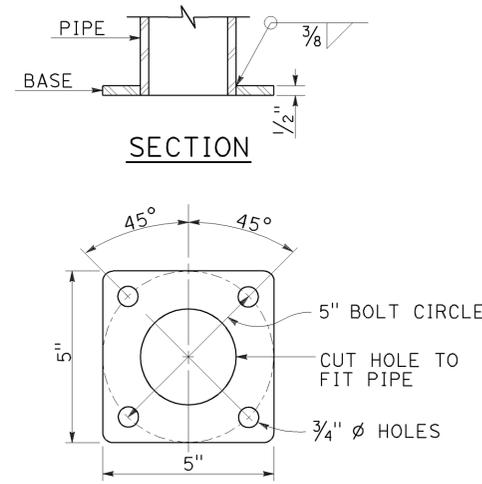

BASE PLATE
PBA POST

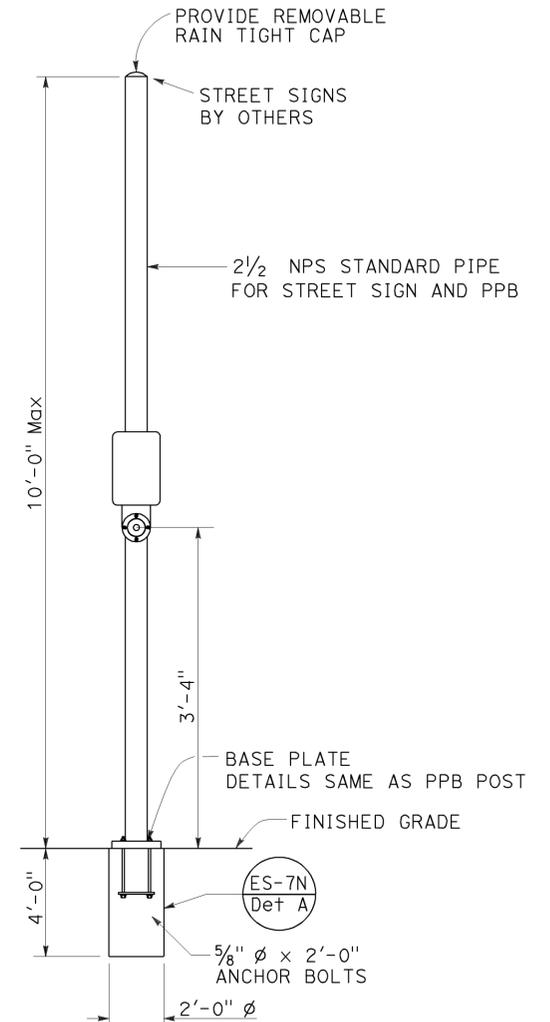

COMBINED STREET SIGN
PUSH BUTTON ASSEMBLY POST
DETAIL C

POLE TYPE	POLE DATA			WALL THICKNESS	BASE PLATE DATA			CIDH DEPTH
	A HEIGHT	Min OD			C	BC = BOLT CIRCLE	THICKNESS	
15TS	30'-0"	8"	3 1/16"	0.1793"	1'-1 1/2"	1'-0"	1 1/2" ϕ x 42"	7'-6"
21TS	35'-0"	9 3/8"	3 3/16"		1'-3"	1'-2"		2"

STATE OF CALIFORNIA
 DEPARTMENT OF TRANSPORTATION
ELECTRICAL SYSTEMS
(SIGNAL AND LIGHTING STANDARD, TYPE TS,
AND PUSH BUTTON ASSEMBLY POST)

NO SCALE

RSP ES-7A DATED JULY 19, 2013 SUPERSEDES STANDARD PLAN ES-7A DATED MAY 20, 2011 - PAGE 462 OF THE STANDARD PLANS BOOK DATED 2010.

REVISED STANDARD PLAN RSP ES-7A

2010 REVISED STANDARD PLAN RSP ES-7A